



RFP #21-2211 Intercom and Digital Signage Systems

Addendum #2: Questions and Answers

September 30, 2021

NOTE:

- The RFP due date has been extended to **October 14, 2021 at 2:00PM**.
- 5% bid bond must be submitted with the proposal.
- A 100% performance bond shall be required.
- The District has removed, from the scope of work, and will be procuring the entire digital signage as described in the scope of services to include the digital signage players, software, displays, mounts and associated electrical requirements. The Contractor shall be responsible for the CAP integration to send CAP alerts to the digital signage alert management software.
- Appendix C has been revised (page 7)
- The New Design Set with the equipment location is presented as Exhibit B (page 9)
- The pre-proposal sign in sheet is attached.

Questions and Answers:

1. Will NetPlanner, the consultant, be allowed to bid direct, subcontract, or cross-sell in any capacity to deliver goods and/or services on this bid?
ANSWER: NetPlanner is the consultant on the project and is excluded from bidding or performing any installation on the project. NetPlanner is already contracted to assist Rock Hill Schools in managing the project through its duration.
2. Will you accept a brand that is equal or greater than the referenced manufacturer?
ANSWER: No
3. Will the awarded contractor be allowed to drop ship product to the District for storage/staging during this project? Note: There will be thousands of boxes of hardware in total to complete this project.

ANSWER: The Contractor may ship items to a Rock Hill Schools district address pending coordination ahead of time and provided that the Contractor handles all receiving, handling and storage of equipment. Contractor is responsible for securing equipment until such time as it is installed.

4. Is there a staging area within the district that can be used in the event of a multiple school rollout? Or will there be space at each school to stage as we deliver to the site?

ANSWER: See response to question #3.

5. In an effort to provide the highest value of service and future services, will the awarded vendor be required to have staff in a brick and mortar office within a defined radius of the district office (i.e. 100 miles) as there will be needs to repair/replace/troubleshoot hardware at times that cannot be done remotely?

ANSWER: No

6. Will there be a preferential bid preference /advantages to vendors domiciled in South Carolina?

ANSWER: No

7. Will electrical power needs for flat panel displays and intercom hardware be the responsibility of the vendor?

ANSWER: Electrical requirements for Digital Signage scope of work shall be removed from this scope of work and will be performed by Rock Hill Schools. All other requirements outside of electrical outlets to be provided for digital signage needs are still included in this RFP.

8. Can extensions be made on the timeline of completion for unforeseen circumstances such as delays in product delivery as no substitutes are currently allowed and we are the mercy of the manufacturers?

ANSWER: Dates listed in the RFP are target dates. At this time the dates remain the same. The District realizes that world conditions and material availability may affect the timeline and will address in the future, if needed.

9. Can you extend the completion date?

ANSWER: See response to question #8.

10. Will any performance or payment bonds be required by the vendor?

ANSWER: Yes, a performance bond shall be required for 100% of the contract cost.

11. Please confirm testing procedures that will need to be adhered to by the vendor upon completion.

ANSWER: Refer to section I and J on pages 22 and 23 of RFP for intercom testing requirements. See below for Visix testing requirements.

- Testing of Digital Signage solution shall include functionality check of the following items:
 - Power on display.
 - Verify proper HDMI signal is received at the display from signage player.
 - Verify connection from signage player to the wireless network.
12. The Visix, NEC Display, Mount, and Installation scope can be fulfilled through the SC ITMO AV Contract at pre-negotiated State discounts and can be integrated seamlessly into the Valcom solution at a more competitive price than the RFP process. Will the School District consider making an award to (2) vendors (Valcom intercom scope & Visix Digital Signage scope)?
- ANSWER:** The District has removed, from the scope of work, and will be procuring the entire digital signage as described in the scope of services to include the digital signage players, software, displays, mounts and associated electrical requirements. The Contractor shall be responsible for the CAP integration to send CAP alerts to the digital signage alert management software.
13. How will we get rid of the speakers that are demoed? Do they go back to the owner, or are they to be disposed of?
- ANSWER:** All equipment shall be discarded in a dumpster supplied by the Contractor. The Contractor shall not re-sell any equipment that has been removed from a Rock Hill School District location.
14. RFP calls for removal of existing paging equipment. Will the district provide instructions as to what gear they will keep, and what gear they wish to dispose of?
- ANSWER:** See response to question #13.
15. With progress billing, if equipment is purchased upon receipt of PO, is it acceptable to invoice for the equipment in the 1st progress billing? Also what are the payment terms, 30, 60, etc.?
- ANSWER:** This project shall have milestone payments. Contractors will be allowed to bill for all staged materials that are stored on Rock Hill School's premises. Invoices for all materials must be provided showing receipt of materials being invoiced. Contractors must invoice all labor and materials separated by school/site. Each site will be allowed to be bill in 3 progress payments;
- 65% for material delivery
 - 25% for labor costs
 - 10% upon delivery of final closeout documentation per school/site.
- The District's payment terms are NET 30.
16. With the extent of this project, will the district allow progressive billing for equipment?
- ANSWER:** See response to question #15.

17. Will the awarded vendor be allowed to progressively bill for materials received/delivered and services rendered throughout the duration of this project?

ANSWER: See response to question #15.

18. What type of cable needs to be ran for 1 way speakers and how do they terminate?

Answer: Refer to manufacturer requirements and recommendations for cable types.

19. Please provide more detail regarding support of existing Atlas servers during the migration.

ANSWER: AtlasIED Support

Contractor shall perform all ongoing preventative maintenance, repair and support services including “Moves, Adds, and Changes” for the emergency alert and intercom systems and to ensure the systems are fully functional 24-hours per day, 7 days a week. Preventative maintenance shall include but not be limited to server, software, speakers, call stations, two-way communication devices, amplifiers, master panel, all other associated peripherals and equipment.

The Contractor shall be required to physically visit each location to provide preventative maintenance. The District will determine the dates. In addition to the physical visits, the Contractor will also provide remote check-ins on applicable systems. The Contractor will be required to provide a comprehensive service report after each visit and check-in. The report will detail all maintenance performed and provide a variety of information including, but not limited to:

- Equipment usage reports
- Equipment cleaning and preventative maintenance
- Firmware upgrades
- Software upgrades
- Tracking of serial numbers and warranty information by location
- Recommendations for equipment replacements, missing parts, etc.

It is the Contractor’s responsibility to provide all equipment, tools and labor to provide the necessary to provide the preventative maintenance. Contractor must maintain adequate hardware inventory to replace, repair and/or maintain each system at the time dispatched. Contractor must be prepared to provide an immediate replacement for defective equipment, to include hardware, and shall not remove a defective unit without an immediate replacement. The District will purchase a server if it is determined that the existing equipment cannot be repaired and is out of warranty.

EQUIPMENT LIST

1. AtlasIED School Intercom Equipment

Server:
AtlasIED 1200ACS. Announcement Control Module

Software:
GCK 3.0

Zone Control Module:
AtlasIED ZCM-V2+t. IP to Analog Zone Control Module

Amplifier:
QSC 108V. 70-volt line amplifier

IP Speakers:
AtlasIED IP Loudspeakers
AtlasIED I8SCM+. Ip Loudspeaker with LED display.

Strobe light:
Revere RV-RSTB

2. UPS Power supply: Smart Online UPS
3. Grandstream phone at front desk
4. Polycom VOIP phone system is connected as well.
5. S2 system is wired into the intercom system for activation of the lockdown alert.

*Some existing equipment from the previous intercom system (Rauland, Dukane, Telecor, and Bogan) may still be connected to the system.

REMOVAL OF EQUIPMENT

Any old or unusable equipment relating to the existing systems of the existing systems that is not being reused must be removed (speakers, phones, amps, switches, call buttons, etc...) and becomes the property of the Contractor and must be disposed of by them. Any equipment that is removed from the ceiling must have the ceiling tiles replaced by the Contractor to match existing if necessary. For example, if a ceiling mounted speaker is removed and a hole is created the Contractor. The Contractor must replace the ceiling tile with a matching tile. Any surfaced mounted equipment that is removed must be patched and painted to match existing wall color. The district will not provide any supplies for tile replacement or paint. Additionally, the district will not provide any equipment needed for disposal or installation such as a lift.

WORK ORDERS

All service calls will be entered into the District's work order system (School Dude). The awarded Contractor will have access to the system and receive notice of all work orders. All work orders and service requests shall be completed in the manner indicated below. It shall be the Contractor's responsibility to have any additional equipment on standby if necessary, to resolve any emergency system wide failure needs.

Issue	Response Time
-------	---------------

Server Issue	Four (4) hours
Speaker not working	Twelve (12) to Twenty-Four (24) hours
System wide intercom failure	Two (2) hours, Operational in eight (8)
Service Call	Twelve (12) to Twenty-Four (24) hours
Work Order	Twelve (12) to Twenty-Four (24) hours

The responding service technician will contact the facility and begin troubleshooting and gathering information/details from the District's representative to determine the appropriate response. Non-Emergency service shall be scheduled and coordinated with the facility during normal business hours.

Liquidated Damages

Work or work orders that are not completed according to the required time lines will follow the fine schedule below.

First Offense	Written warning
Second Offense	\$250
Third and Fourth Offense	\$500

20. What model speaker goes with the VL-520 in the classrooms marked. Does it wire back to the VL-520?

ANSWER: The New Set Design (Exhibit B) is provided to show the intended completed installation expectations. Typical classrooms do not have secondary speakers connected to VL520's. In the case of additional speakers being located with VL520's, these can be VE9022A type speakers and they can receive audio from the line out of the VL520. Power will still need to be provided to the VE9022A speaker for operation from the power supplies located in the nearest IDF.

21. Verifying the room layouts, is the intent to place the VL520BKs on the same wall that the clocks and buttons reside?

ANSWER: See response to question #20.

22. The RFP calls for the contractor to supply the power connections for the digital signage displays. Is there any detail available for the locations of the displays? Or, is it the intent of the school district to handle the power needs separate from this RFP?

ANSWER: See response to question #7.

23. Are the existing classroom clocks IP?

Yes

APPENDIX C – COST PROPOSAL (REVISED)- This form must be submitted back with your response.

Facility	Total Valcom System Cost and Installation	Allowance
Applied Technology Center		
Aquatic Center		\$10,000
Castle Heights Middle School		
Carroll School		\$10,000
Central Child Development Center		
Centralized Command and Control Center (C4)		
Central Office		
Cherry Park Elementary School		
District Three Stadium		\$10,000
District Three Stadium South		\$10,000
Dutchman Creek Middle School		
Ebenezer Elementary School		
Ebinport Elementary School		
Flexible Learning Center		
Independence Elementary School		
India Hook Elementary School		
Lesslie Elementary School		
Mt Gallant Elementary School		
Mt Holly Elementary School		
Northside Elementary School		
Northwestern High School		
Oakdale Elementary School		
Old Pointe Elementary School		
Operations Center		

Rawlinson Road Elementary School		
Richmond Drive Elementary School		
Rock Hill High School		
Saluda Trail Middle School		
South Pointe High School		
Sullivan Middle School		
Sunset Park Elementary School		
Transportation Services		
York Road Elementary School		
Sub-total		
Contingency - 2% of total IP Intercom System value		
Total *This amount will be evaluated.		\$40,000

Other Costs:

Please include other costs below and describe what costs are included below.

\$ _____

Price per single Category 6 drop to add or replace cables in support of the IP intercom system:

\$ _____

EXHIBIT B: New Design Set

A | B | C | D | E | F | G | H | J | K

ROCK HILL SCHOOLS

INTERCOM & NOTIFICATIONS - NEW DESIGN SET

EXHIBIT B



- PROJECT DISCIPLINES INCLUDED**
- COMMUNICATIONS
 - STRUCTURED CABLING
 - AUDIO/VISUAL
 - SECURITY
 - ACCESS CONTROL
 - INTRUSION

DRAWING PACKAGE RELEASES		
NUMBER	RELEASE DESCRIPTION	DATE
1	SUBMITTAL SET	07-29-2021

Sheet List Table	
Sheet Number	Sheet Title
NEW DESIGN SET	
T-0-000N	COVER SHEET
TA-0-001N	NOTES & LEGEND
NEW DESIGN SET: FLOOR PLANS: BLDG 1 - APPLIED TECH CENTER	
TA-1-1-101N	APPLIED TECH CENTER - NEW DEVICES
NEW DESIGN SET: FLOOR PLANS: BLDG 2 - BELLEVUE ELEMENTARY	
TA-1-2-101N	BELLEVUE ELEMENTARY - NEW DEVICES
NEW DESIGN SET: FLOOR PLANS: BLDG 3 - CENTRALIZED COMMAND & CONTROL CENTER	
TA-1-3-101N	CENTRALIZED COMMAND & CONTROL CENTER - NEW DEVICES
NEW DESIGN SET: FLOOR PLANS: BLDG 4 - CASTLE HEIGHTS MIDDLE	
TA-1-4-100N	CASTLE HEIGHTS MIDDLE - OVERALL - NEW DEVICES
TA-1-4-101N	CASTLE HEIGHTS MIDDLE - PART A - NEW DEVICES
TA-1-4-102N	CASTLE HEIGHTS MIDDLE - PART B - NEW DEVICES
TA-1-4-103N	CASTLE HEIGHTS MIDDLE - PART C - NEW DEVICES
NEW DESIGN SET: FLOOR PLANS: BLDG 5 - CENTRAL CHILD DEVELOPMENT	
TA-1-5-101N	CENTRAL CHILD DEVELOPMENT - NEW DEVICES
NEW DESIGN SET: FLOOR PLANS: BLDG 6 - CHERRY PARK ELEMENTARY: CHERRY PARK ELEMENTARY - 1ST FLOOR	
TA-1-6-100N	CHERRY PARK ELEMENTARY - 1ST FLR OVERALL - NEW DEVICES
TA-1-6-101N	CHERRY PARK ELEMENTARY - 1ST FLR - NEW DEVICES
NEW DESIGN SET: FLOOR PLANS: BLDG 6 - CHERRY PARK ELEMENTARY: CHERRY PARK ELEMENTARY - 2ND FLOOR	
TA-1-6-200N	CHERRY PARK ELEMENTARY - 2ND FLR OVERALL - NEW DEVICES
TA-1-6-201N	CHERRY PARK ELEMENTARY - 2ND FLR - NEW DEVICES
NEW DESIGN SET: FLOOR PLANS: BLDG 7 - DISTRICT OFFICE	
TA-1-7-101N	DISTRICT OFFICE - 1ST FLOOR - NEW DEVICES
TA-1-7-201N	DISTRICT OFFICE - 2ND FLOOR - NEW DEVICES
TA-1-7-301N	DISTRICT OFFICE - 3RD FLOOR - NEW DEVICES
NEW DESIGN SET: FLOOR PLANS: BLDG 8 - DISTRICT THREE SOUTH STADIUM	
TA-1-8-101N	DISTRICT THREE SOUTH STADIUM - NEW DEVICES
NEW DESIGN SET: FLOOR PLANS: BLDG 9 - DISTRICT THREE STADIUM	
TA-1-9-101N	DISTRICT THREE STADIUM - NEW DEVICES
NEW DESIGN SET: FLOOR PLANS: BLDG 10 - DUTCHMAN CREEK MIDDLE	
TA-1-10-100N	DUTCHMAN CREEK MS - OVERALL - NEW DEVICES
TA-1-10-101N	DUTCHMAN CREEK MS - PART A - NEW DEVICES
TA-1-10-102N	DUTCHMAN CREEK MS - PART B - NEW DEVICES
TA-1-10-103N	DUTCHMAN CREEK MS - PART C - NEW DEVICES
NEW DESIGN SET: FLOOR PLANS: BLDG 11 - EBENEZER ELEMENTARY	
TA-1-11-101N	EBENEZER ELEMENTARY - 1ST FLOOR - NEW DEVICES
TA-1-11-201N	EBENEZER ELEMENTARY - 2ND FLOOR - NEW DEVICES
NEW DESIGN SET: FLOOR PLANS: BLDG 12 - EBINPORT ELEMENTARY	
TA-1-12-101N	EBINPORT ELEMENTARY - NEW DEVICES
NEW DESIGN SET: FLOOR PLANS: BLDG 13 - FINLEY ROAD ELEMENTARY	
TA-1-13-101N	FINLEY ROAD ELEMENTARY - NEW DEVICES

NEW DESIGN SET: FLOOR PLANS: BLDG 14 - FLEXIBLE LEARNING CNTR	
TA-1-14-101N	FLEXIBLE LEARNING CENTER - 1ST FLOOR - NEW DEVICES
TA-1-14-201N	FLEXIBLE LEARNING CENTER - 2ND FLOOR - NEW DEVICES
NEW DESIGN SET: FLOOR PLANS: BLDG 15 - INDEPENDENCE ELEMENTARY	
TA-1-15-101N	INDEPENDENCE ELEMENTARY - NEW DEVICES
NEW DESIGN SET: FLOOR PLANS: BLDG 16 - INDIA HOOK ELEMENTARY	
TA-1-16-101N	INDIA HOOK ELEMENTARY - NEW DEVICES
NEW DESIGN SET: FLOOR PLANS: BLDG 17 - LESSLIE ELEMENTARY	
TA-1-17-101N	LESSLIE ELEMENTARY - NEW DEVICES
NEW DESIGN SET: FLOOR PLANS: BLDG 18 - MT. GALLANT ELEMENTARY	
TA-1-18-101N	MT. GALLANT ELEMENTARY - NEW DEVICES
NEW DESIGN SET: FLOOR PLANS: BLDG 19 - MT. HOLLY ELEMENTARY	
TA-1-19-101N	MT. HOLLY ELEMENTARY - NEW DEVICES
NEW DESIGN SET: FLOOR PLANS: BLDG 20 - NORTHSIDE ELEMENTARY	
TA-1-20-101N	NORTHSIDE ELEMENTARY - NEW DEVICES
NEW DESIGN SET: FLOOR PLANS: BLDG 21 - NORTHWESTERN HIGH SCHOOL: NORTHWESTERN HIGH SCHOOL - 1ST FLOOR	
TA-1-21-100N	NORTHWESTERN HS - 1ST FLOOR OVERALL - NEW DEVICES
TA-1-21-101N	NORTHWESTERN HS - 1ST FLOOR BLDG A & B - NEW DEVICES
TA-1-21-102N	NORTHWESTERN HS - 1ST FLOOR BLDG C & GYM - NEW DEVICES
TA-1-21-103N	NORTHWESTERN HS - 1ST FLOOR BLDG D & E - NEW DEVICES
NEW DESIGN SET: FLOOR PLANS: BLDG 21 - NORTHWESTERN HIGH SCHOOL: NORTHWESTERN HIGH SCHOOL - 2ND FLOOR	
TA-1-21-200N	NORTHWESTERN HS - 2ND FLOOR OVERALL - NEW DEVICES
TA-1-21-201N	NORTHWESTERN HS - 2ND FLOOR BLDG A - NEW DEVICES
TA-1-21-202N	NORTHWESTERN HS - 2ND FLOOR BLDG D & E - NEW DEVICES
NEW DESIGN SET: FLOOR PLANS: BLDG 22 - OAKDALE ELEMENTARY	
TA-1-22-101N	OAKDALE ELEMENTARY - NEW DEVICES
NEW DESIGN SET: FLOOR PLANS: BLDG 23 - OLD POINTE ELEMENTARY	
TA-1-23-101N	OLD POINTE ELEMENTARY - NEW DEVICES
NEW DESIGN SET: FLOOR PLANS: BLDG 24 - OPERATIONS (FACILITY SERVICES)	
TA-1-24-101N	OPERATIONS (FACILITY SERVICES) - NEW DEVICES
NEW DESIGN SET: FLOOR PLANS: BLDG 25 - RAWLINSON ROAD MIDDLE	
TA-1-25-101N	RAWLINSON ROAD MS - 1ST FLR - NEW DEVICES
TA-1-25-201N	RAWLINSON ROAD MS - 2ND FLR - NEW DEVICES
NEW DESIGN SET: FLOOR PLANS: BLDG 26 - RICHMOND DRIVE ELEMENTARY	
TA-1-26-101N	RICHMOND DRIVE ELEMENTARY - NEW DEVICES
NEW DESIGN SET: FLOOR PLANS: BLDG 27 - ROCK HILL HIGH SCHOOL: ROCK HILL HIGH SCHOOL - 1ST FLOOR	
TA-1-27-100N	ROCK HILL HS - 1ST FLR OVERALL - NEW DEVICES
TA-1-27-101N	ROCK HILL HS - 1ST FLR BLDG A & B - NEW DEVICES
TA-1-27-102N	ROCK HILL HS - 1ST FLR BLDG C & GYM - NEW DEVICES
TA-1-27-103N	ROCK HILL HS - 1ST FLR BLDG D & E - NEW DEVICES
TA-1-27-104N	ROCK HILL HS - BASEMENT - NEW DEVICES
NEW DESIGN SET: FLOOR PLANS: BLDG 27 - ROCK HILL HIGH SCHOOL: ROCK HILL HIGH SCHOOL - 2ND FLOOR	
TA-1-27-200N	ROCK HILL HS - 2ND FLR OVERALL - NEW DEVICES
TA-1-27-201N	ROCK HILL HS - 2ND FLR BLDG A - NEW DEVICES
TA-1-27-202N	ROCK HILL HS - 2ND FLR BLDG C & GYM - NEW DEVICES

TA-1-27-203N	ROCK HILL HS - 2ND FLR BLDG D & E - NEW DEVICES
NEW DESIGN SET: FLOOR PLANS: BLDG 28 - ROSEWOOD ELEMENTARY	
TA-1-28-101N	ROSEWOOD ELEMENTARY - NEW DEVICES
NEW DESIGN SET: FLOOR PLANS: BLDG 29 - SALUDA TRAIL MIDDLE SCHOOL	
TA-1-29-101N	SALUDA TRAIL MIDDLE - NEW DEVICES
NEW DESIGN SET: FLOOR PLANS: BLDG 30 - SOUTH POINT HIGH SCHOOL: SOUTH POINT HIGH SCHOOL - 1ST FLOOR	
TA-1-30-100N	SOUTH POINT HS - 1ST FLR OVERALL - NEW DEVICES
TA-1-30-101N	SOUTH POINT HS - 1ST FLR PART A - NEW DEVICES
TA-1-30-102N	SOUTH POINT HS - 1ST FLR PART B - NEW DEVICES
NEW DESIGN SET: FLOOR PLANS: BLDG 30 - SOUTH POINT HIGH SCHOOL: SOUTH POINT HIGH SCHOOL - 2ND FLOOR	
TA-1-30-200N	SOUTH POINT HS - 2ND FLR OVERALL - NEW DEVICES
TA-1-30-201N	SOUTH POINT HS - 2ND FLR PART A - NEW DEVICES
TA-1-30-202N	SOUTH POINT HS - 2ND FLR PART B - NEW DEVICES
NEW DESIGN SET: FLOOR PLANS: BLDG 31 - SULLIVAN MIDDLE SCHOOL: SULLIVAN MIDDLE SCHOOL - 1ST FLOOR	
TA-1-31-100N	SULLIVAN MS - 1ST FLR OVERALL - NEW DEVICES
TA-1-31-101N	SULLIVAN MS - 1ST FLR BLDG A & B - NEW DEVICES
TA-1-31-102N	SULLIVAN MS - 1ST FLR BLDG C & D - NEW DEVICES
TA-1-31-103N	SULLIVAN MS - 1ST FLR BLDG E & F - NEW DEVICES
TA-1-31-104N	SULLIVAN MS - 1ST FLR BLDG G - NEW DEVICES
TA-1-31-105N	SULLIVAN MS - 1ST FLR BLDG GYM - NEW DEVICES
TA-1-31-106N	SULLIVAN MS - 1ST FLR LIBRARY & CAFE - NEW DEVICES
NEW DESIGN SET: FLOOR PLANS: BLDG 31 - SULLIVAN MIDDLE SCHOOL: SULLIVAN MIDDLE SCHOOL - 2ND FLOOR	
TA-1-31-200N	SULLIVAN MS - 2ND FLR OVERALL - NEW DEVICES
TA-1-31-201N	SULLIVAN MS - 2ND FLR BLDG B - NEW DEVICES
TA-1-31-202N	SULLIVAN MS - 2ND FLR BLDG C & D - NEW DEVICES
TA-1-31-203N	SULLIVAN MS - 2ND FLR BLDG E & F - NEW DEVICES
NEW DESIGN SET: FLOOR PLANS: BLDG 32 - SUNSET PARK ELEMENTARY	
TA-1-32-100N	SUNSET PARK ELEMENTARY - 1ST FLOOR - NEW DEVICES
TA-1-32-101N	SUNSET PARK ELEMENTARY - 1ST FLR PART A - NEW DEVICES
TA-1-32-102N	SUNSET PARK ELEMENTARY - 1ST FLR PART B - NEW DEVICES
TA-2-32-201N	SUNSET PARK ELEMENTARY - 2ND FLR - NEW DEVICES
NEW DESIGN SET: FLOOR PLANS: BLDG 33 - SYLVIA ELEMENTARY	
TA-1-33-101N	SYLVIA ELEMENTARY - NEW DEVICES
NEW DESIGN SET: FLOOR PLANS: BLDG 34 - TRANSPORTATION BUILDING	
TA-1-34-101N	TRANSPORTATION - NEW DEVICES
NEW DESIGN SET: FLOOR PLANS: BLDG 35 - YORK ELEMENTARY	
TA-1-35-101N	YORK ELEMENTARY - NEW DEVICES


A | B | C | D | E | F | G | H | J | K

AV EQUIPMENT SYMBOLS
■ SPEAKER WALL MOUNTED
○ SPEAKER CEILING MOUNTED
◎ SPEAKER (VALCOM V-9880) CEILING MOUNTED
■ BUTTON (VALCOM V-2972) WALL MOUNTED
□ CLOCK (VALCOM VL520BK-F) WALL MOUNTED
○ SPEAKER / CLOCK (VALCOM VL520BK-F) CEILING MOUNTED
NOTE: WP = WEATHERPROOF


GENERAL NOTES
1. THIS DRAWING PACKAGE REFLECTS THE AV AND/OR SECURITY INSTALLATION AND THE REQUIREMENTS FOR THAT INSTALLATION. THOSE REQUIREMENTS WILL BE PROVIDED BY THE GENERAL CONTRACTOR (GC), ELECTRICAL CONTRACTOR (EC), THE END USER (OFE), AS NOTED ON DRAWINGS.
2. ALL POWER OUTLETS REQUESTED IN THIS DRAWING PACKAGE FOR THE AV AND/OR SECURITY SYSTEM NEED TO BE DEDICATED CIRCUITS WITH ISOLATED GROUNDS. THEY SHOULD NOT BE SHARED WITH NON-AV/SECURITY EQUIPMENT CIRCUITS. THE AMPERAGE WILL BE NOTED IN THE DRAWINGS.
3. ALL CONDUIT PROVIDED IS REQUIRED TO HAVE PULL STRINGS.

DRAWING NAME CONVENTION
T[X]-[NUMBER]-###
T[X] = SYSTEM TYPE TA = TELECOMMUNICATIONS AUDIO-VISUAL [AV] TN = TELECOMMUNICATIONS DATA NETWORKS [COM] TY = TELECOMMUNICATIONS SECURITY [SEC]
[NUMBER] = DRAWING TYPE 0 = GENERAL (INDEX, LEGENDS, NOTES) 1 = PLANS (FLOOR PLANS, RCPS) 2 = ELEVATIONS (VERTICAL VIEWS) 5 = DETAIL SHEETS 6 = WIRING DIAGRAMS
[NUMBER] = SCHOOL NUMBER
= UNIQUE SHEET IDENTIFIER [FOR ARCH DWGS] 1ST NUMBER IS THE FLOOR NUMBER 2ND & 3RD NUMBER IS A SEQUENTIAL NUMBERING (01,02, ETC)
= UNIQUE SHEET IDENTIFIER [FOR WIRING DWGS] ALL NUMBERS ARE A SEQUENTIAL NUMBERING (001,002, ETC)

WIRE NUMBER CONVENTION
XX-Y-abc
XX = SIGNAL TYPE DESIGNATOR, DESIGNATORS LISTED BELOW
AA - ANALOG AUDIO MA - MICROPHONE AUDIO SA - SPEAKER AUDIO DA - DIGITAL AUDIO V - ANALOG VIDEO DV - DIGITAL VIDEO (HDMI, DVI, HDBASET, DM, ETC) D - DATA-NETWORK C - CONTROL P - POWER RF - CABLE TV USB - USB
Y = GENERAL CABLE LOCATION, DESIGNATORS LISTED BELOW
I - INPUT ON A SWITCH/ROUTER IN A RACK O - OUTPUT ON A SWITCH ROUTER IN A RACK R - RACK CABLES NOT INCLUDED IN I & O F - FIELD CABLES (ALL OTHER CABLES NOT INCLUDED ABOVE)
a = CHASSIS NUMBER (DSP #1, DSP #2, ETC), USUALLY WILL BE 1
bc = INPUT OR OUTPUT NUMBER OF SWITCH/ROUTER, OR SEQUENTIAL NUMBER FOR OTHER TYPES (01, 02, ETC)
EXAMPLE NUMBER: DV-I-101 - DIGITAL VIDEO INPUT #1, SWITCHER #1

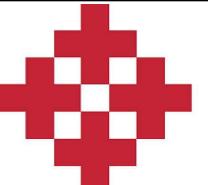NetPlanner SYSTEMS, INC. Your Pathway to Connectivity		CLIENT LOGO	PROJECT INFO	SHEET INFO	REVISIONS	ENGINEER APPROVAL	ENGINEER WM	DRAWING NAME
 NetPlanner SYSTEMS, INC. Your Pathway to Connectivity			ROCK HILL SCHOOLS ROCK HILL, SC	INTERCOM & NOTIFICATIONS NOTES & LEGEND	REV. DESCRIPTION DATE		CAD AK	TA-0-001N PROJECT NUMBER AR20245
Atlanta, GA Raleigh, NC Toll Free		770-662-5482 919-290-8010 800-795-1975 www.netplanner.com	Augusta, GA Columbus, GA Savannah, GA	706-364-4190 706-571-9090 912-748-8960			PROJECT MANAGER SD	APPROVED DRAWING DATE 07-23-2021 RELEASE NUMBER 1


A B C D E F G H J K

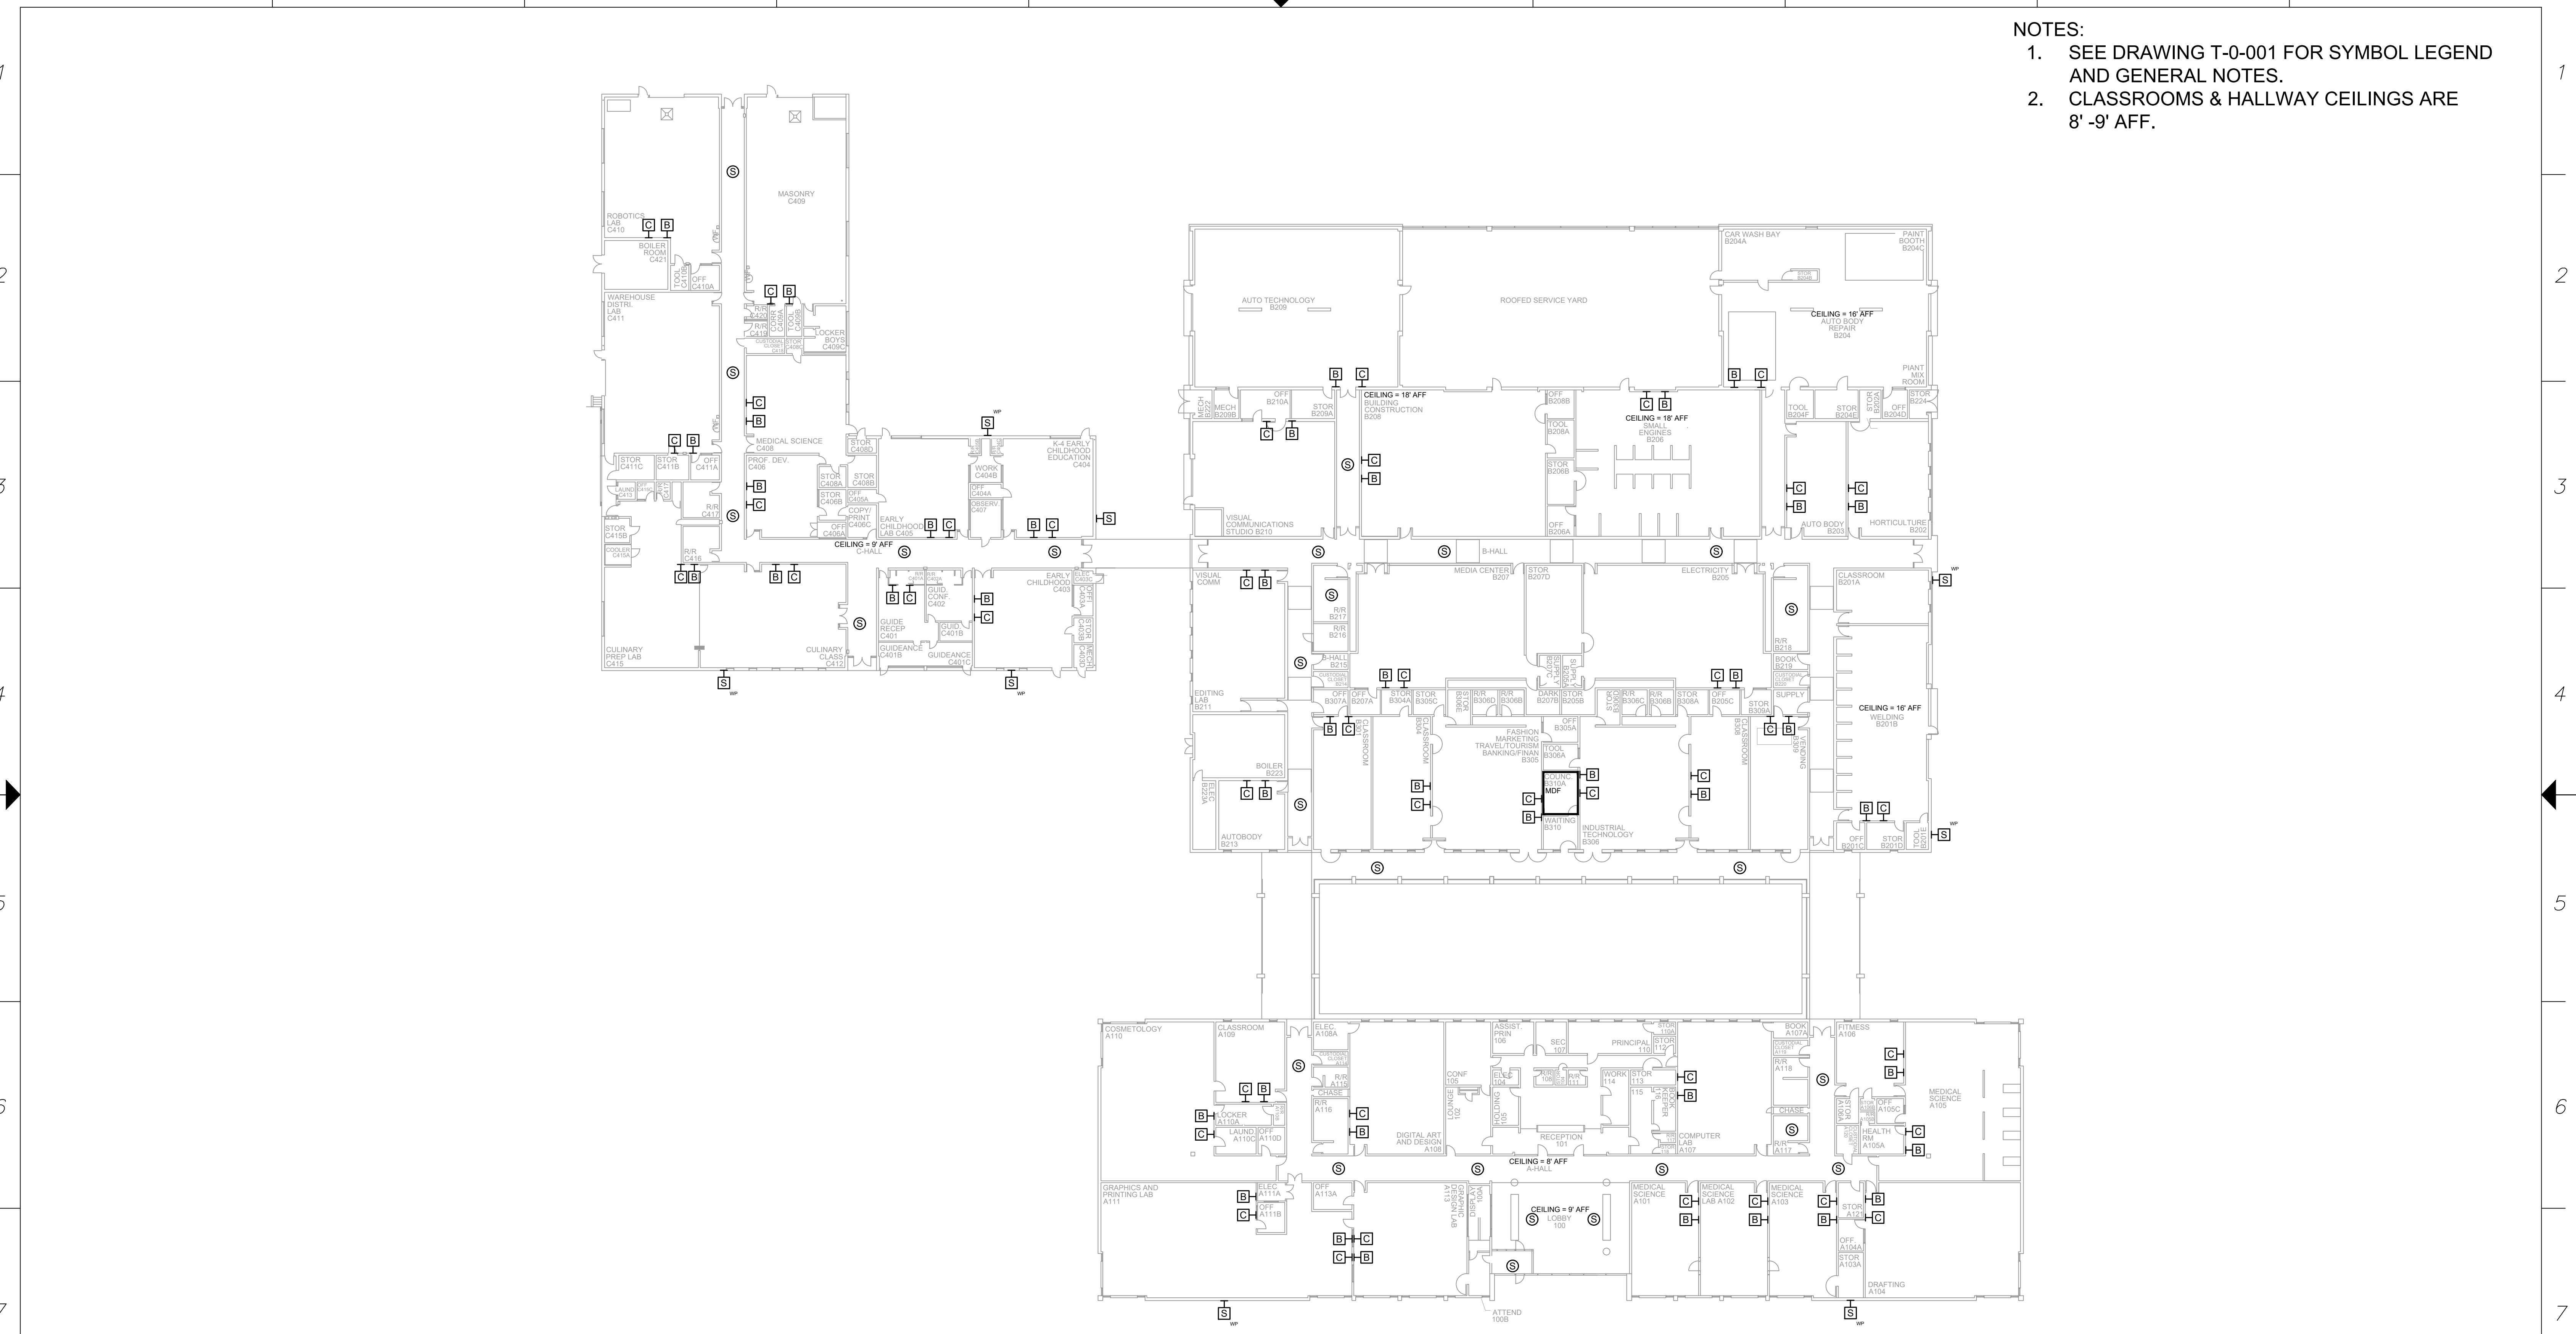

1 AV EQUIPMENT LAYOUT

SCALE: NTS

REV.	DESCRIPTION	DATE	REVISIONS	
			ENGINEER APPROVAL	DRAWING NAME
			WM	TA-1-1-101N
			AK	PROJECT NUMBER
				AR20245
			SD	PROJECT MANAGER
				APPROVED DRAWING DATE
				07-23-2021
				RELEASE NUMBER
				1

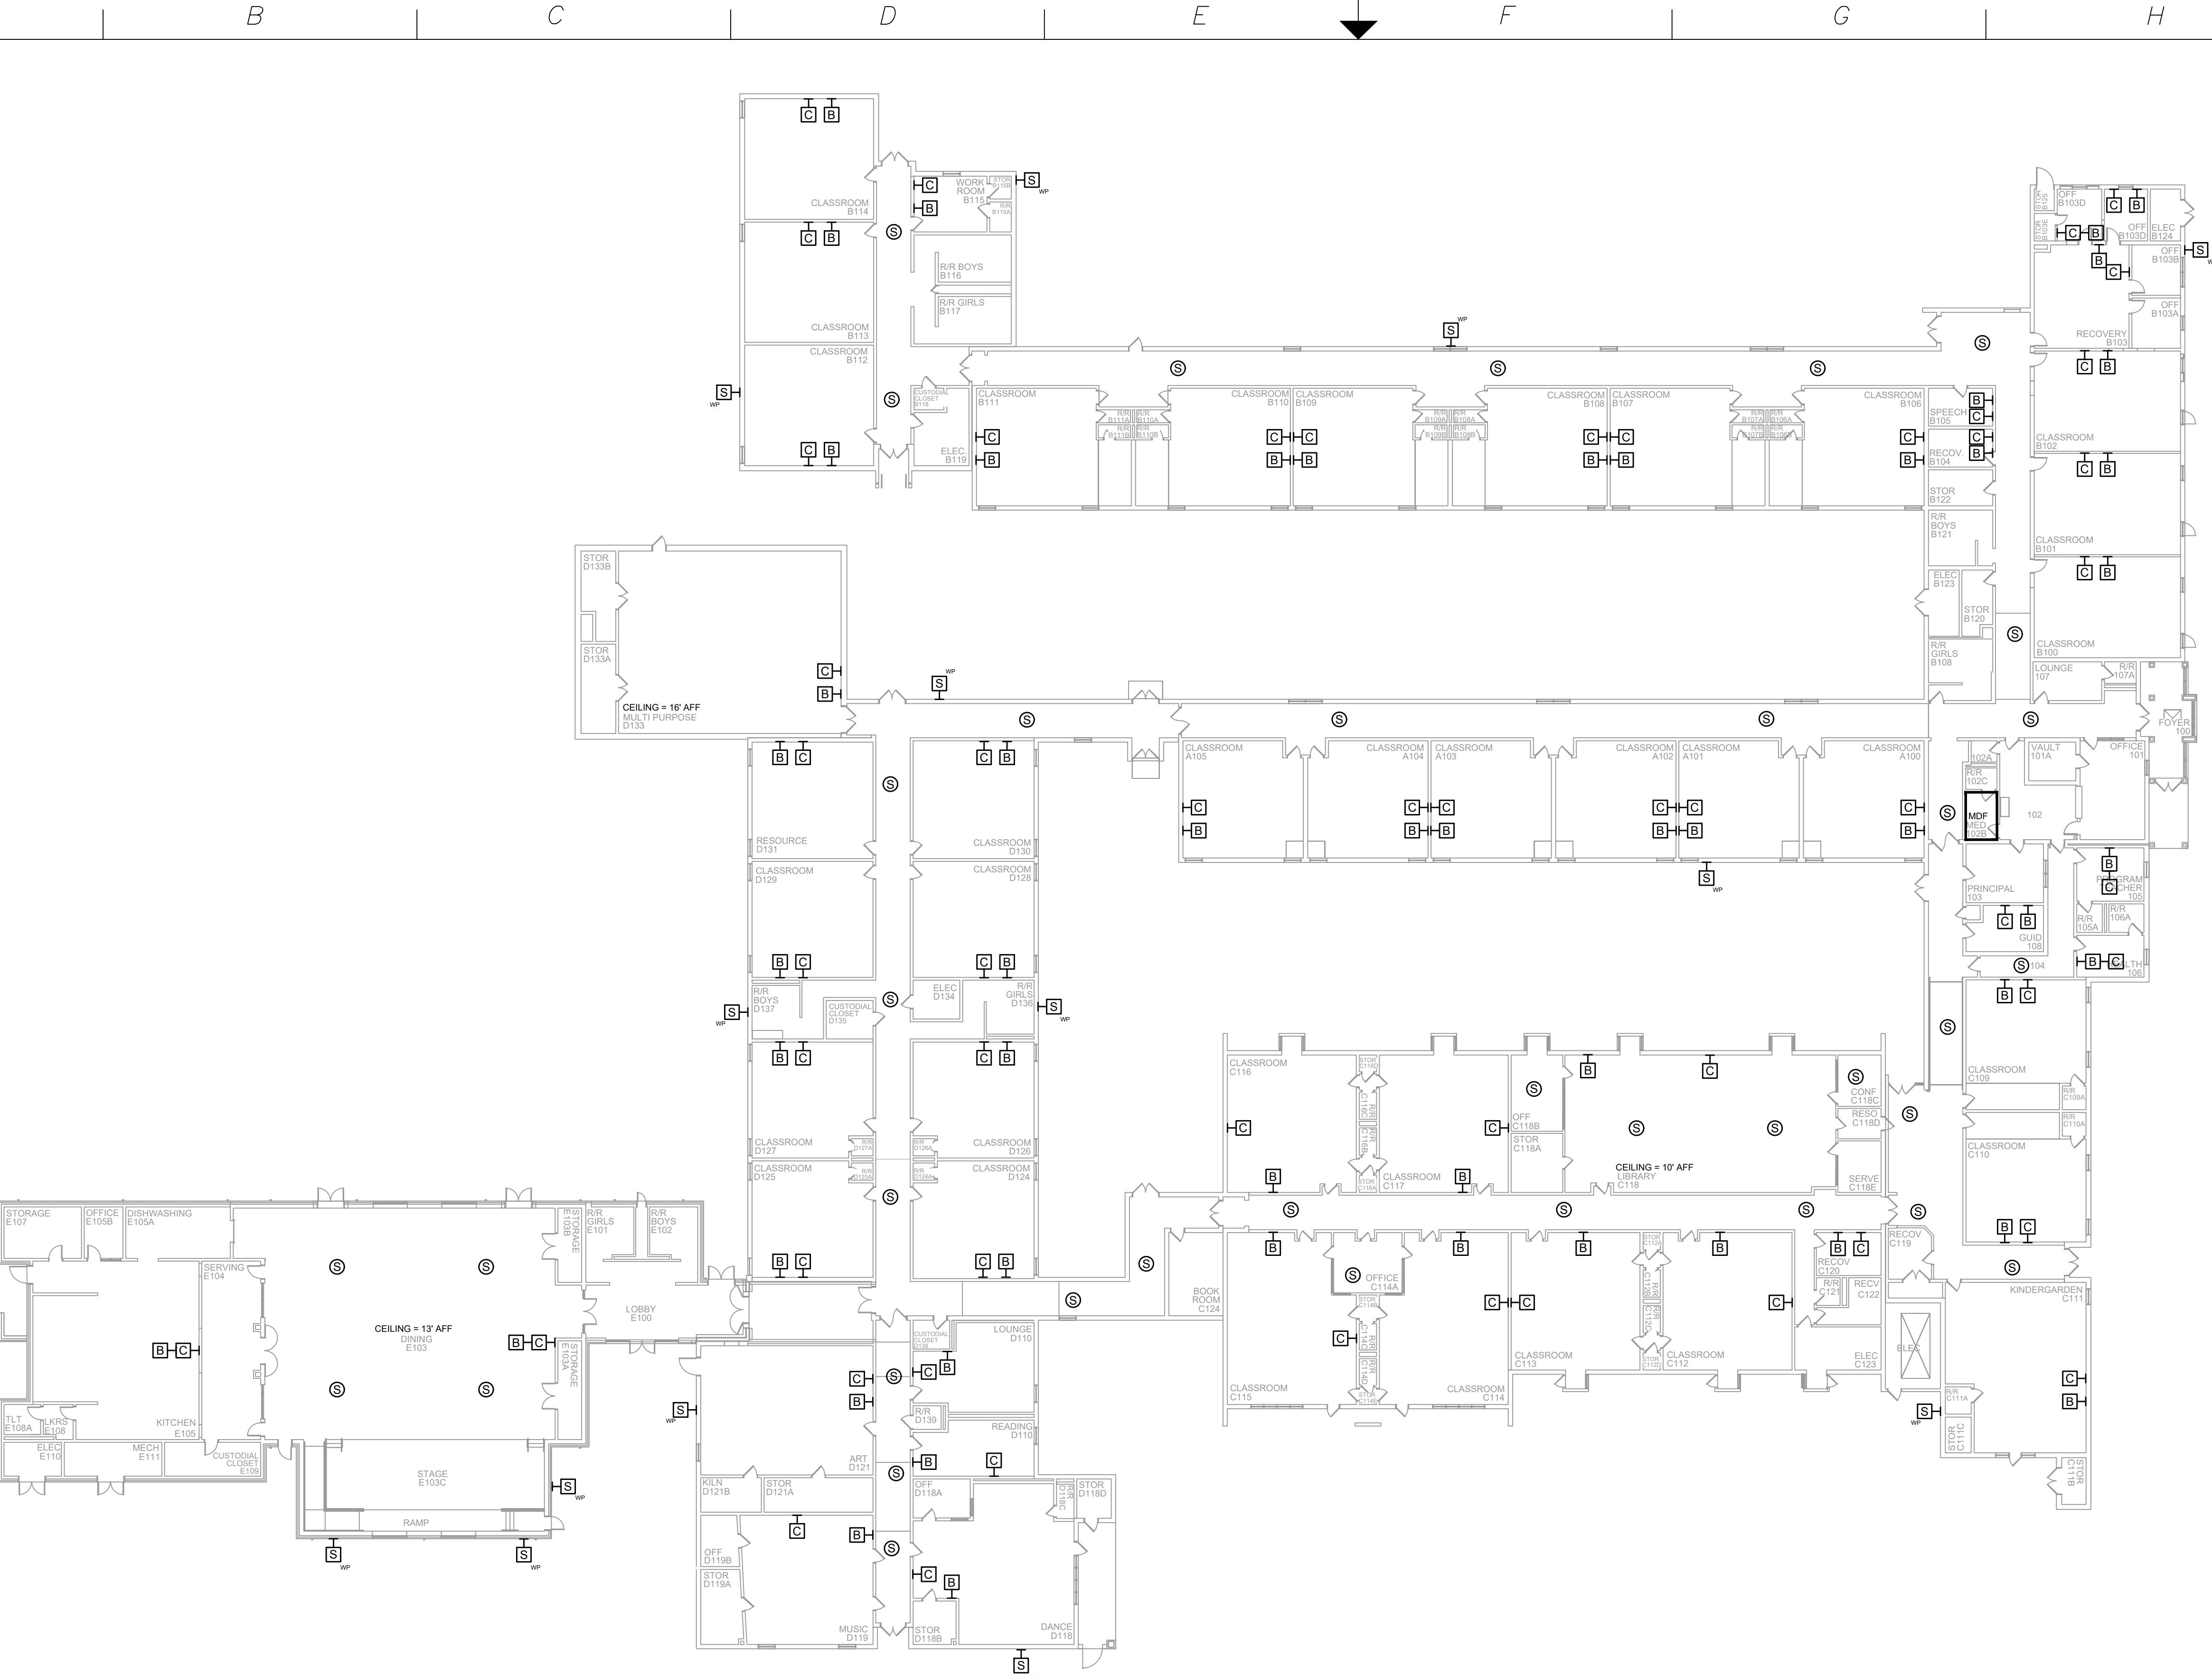


NOTES:

1. SEE DRAWING T-0-001 FOR SYMBOL LEGEND AND GENERAL NOTES.

1 AV EQUIPMENT LAYOUT

SCALE: NTS

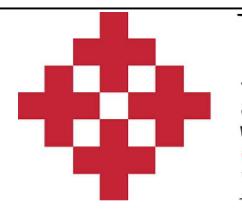

NetPlanner

S Y S T E M S, I N C.®

Your Pathway to Connectivity

CLIENT LOGO



PROJECT INFO

SHEET INFO

INTERCOM & NOTIFICATIONS

BELLEVIEVIEW ELEMENTARY - NEW DEVICES

**ENGINEERED
APPROVAL**

1

DRAWING NAME

TA 12

PROJECT NUMBER
P00045

PROVED DRAWING
7-23-2021

AWING NAME
TA-1-2-101N

PROJECT NUMBER
P20245

PROVED DRAWING DATE
17-23-2021

A

1

1

A B C D E F G H J K



Atlanta, GA
Raleigh, NC
Toll Free
770-662-5482
919-290-8010
800-795-1975
www.netplanner.com

Augusta, GA
Columbus, GA
Savannah, GA
706-364-4190
706-571-9090
912-748-8960



CLIENT LOGO

PROJECT INFO
ROCK HILL SCHOOLS
ROCK HILL, SC

SHEET INFO
INTERCOM & NOTIFICATIONS
CENTRALIZED COMMAND & CONTROL
CENTER - NEW DEVICES

REV.	DESCRIPTION	DATE


REVISIONS	ENGINEER APPROVAL	ENGINEER	DRAWING NAME
		WM	TA-1-3-101N
		CAD	PROJECT NUMBER
		AK	AR20245


PROJECT MANAGER	APPROVED DRAWING DATE	RELEASE NUMBER
SD	07-23-2021	1

A B C D E F G H J K

NOTES:

- SEE DRAWING T-0-001 FOR SYMBOL LEGEND AND GENERAL NOTES.
- CLASSROOMS & HALLWAY CEILINGS ARE 10' AFF.

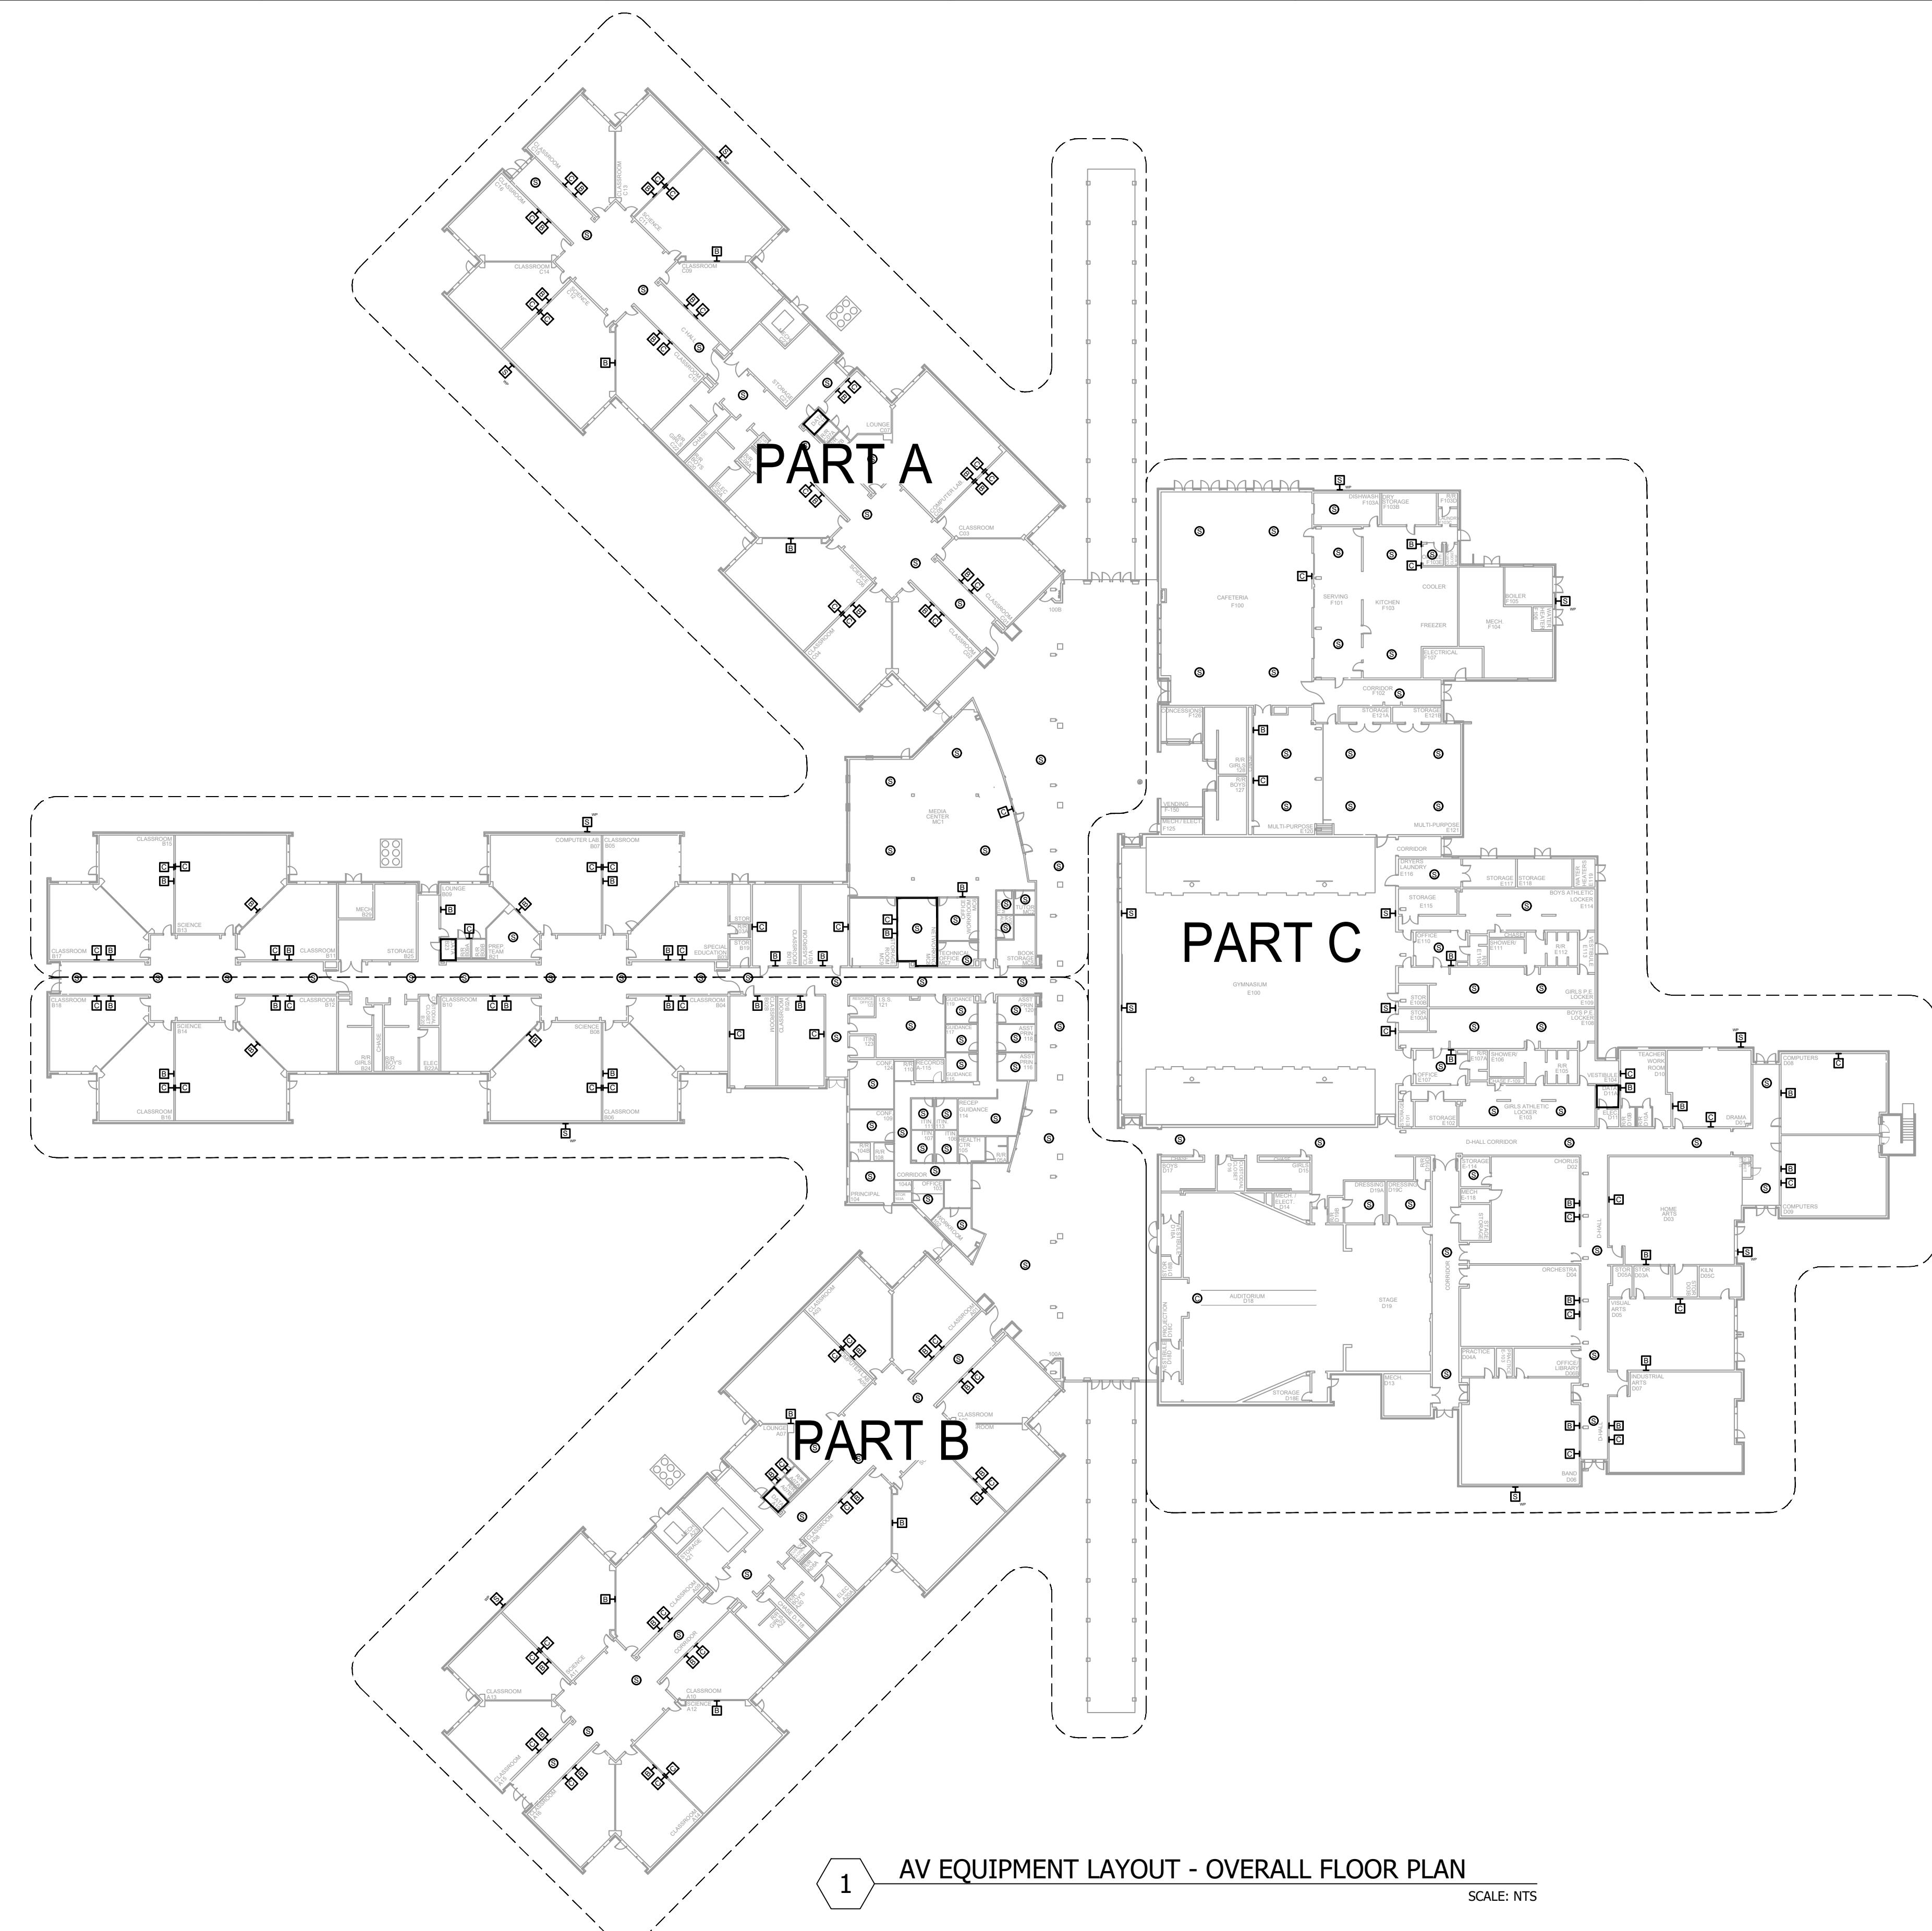

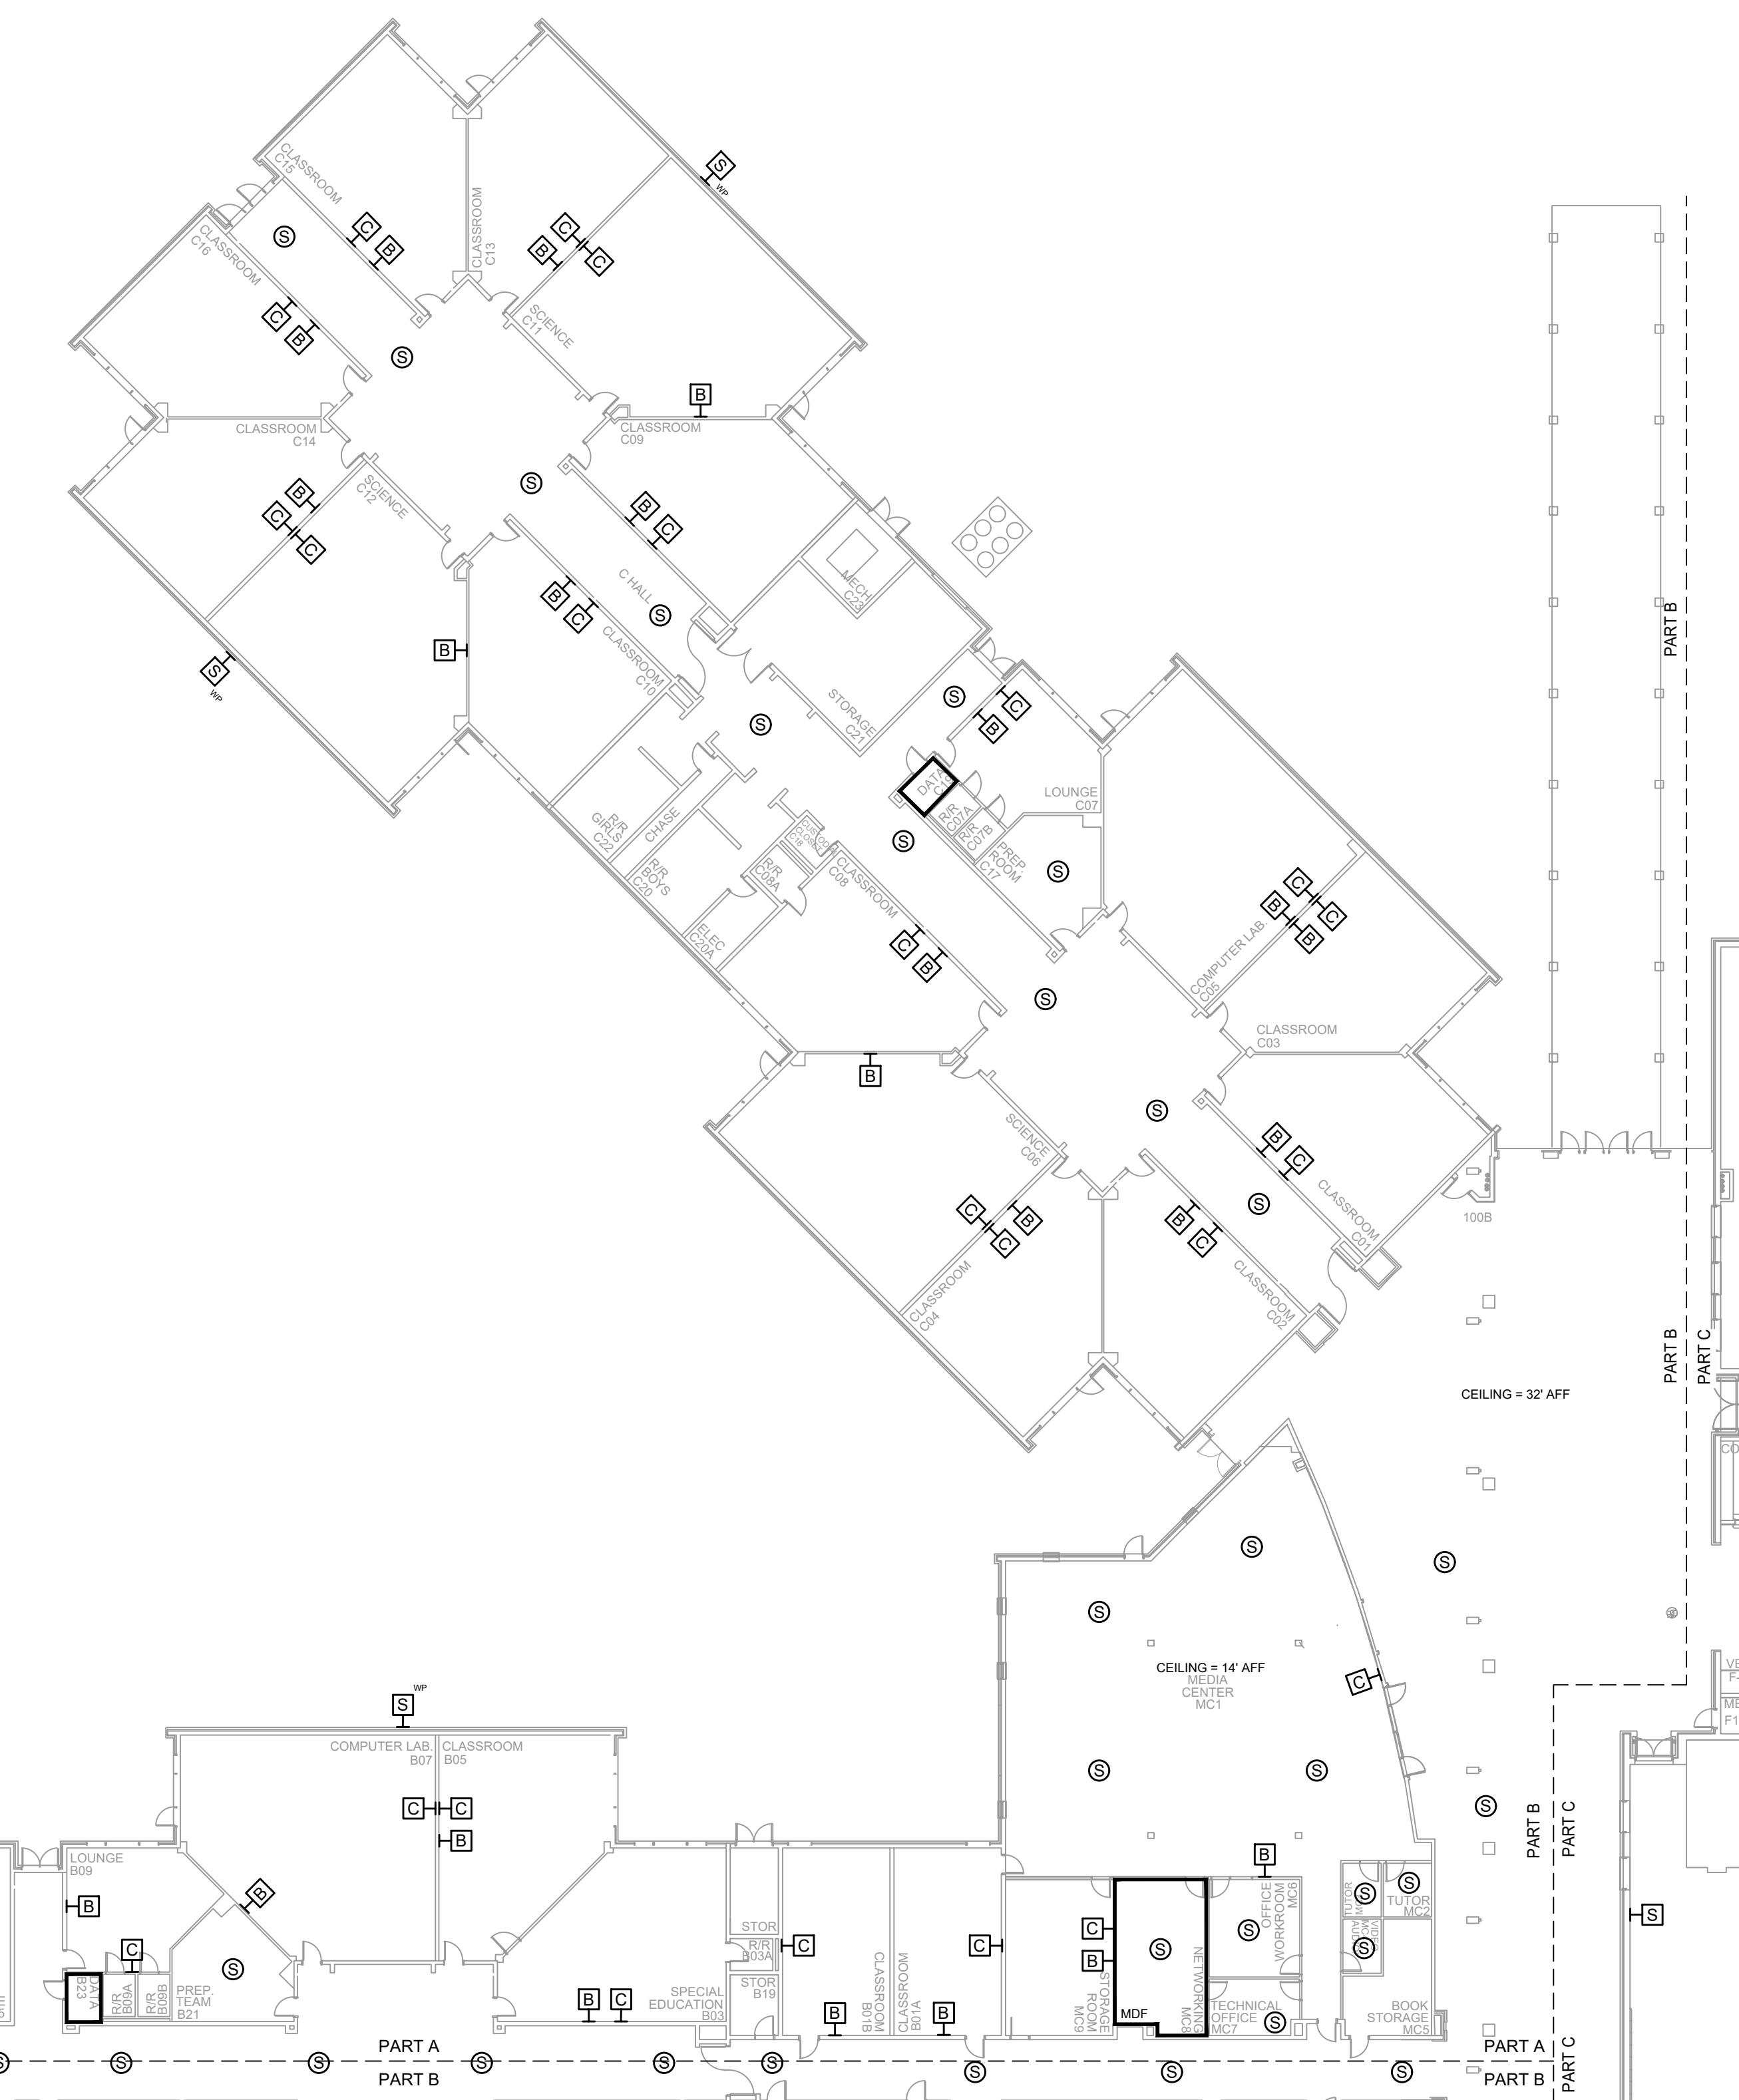


NOTES:

1. SEE DRAWING T-0-001 FOR SYMBOL LEGEND AND GENERAL NOTES.
2. CLASSROOMS & HALLWAY CEILINGS ARE 10' AFF.

AV EQUIPMENT LAYOUT - SECTION A

SCALE: NTS

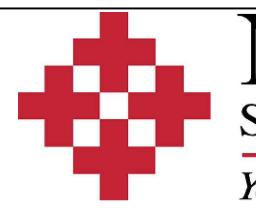

NetPlanner SYSTEMS, INC.[®]

Your Pathway to Connectivity

62-5482	Augusta, GA	706-364-
90-8010	Columbus, GA	706-571-
95-1975	Savannah, GA	912-748-

www.netplanner.com

CLIENT LOC



PROJECT INFO

ROCK HILL SCHOOLS ROCK HILL, SC

SHEET INFO
INTERCOM & NOTIFICATIONS
CASTLE HEIGHTS MIDDLE - PART A -
NEW DEVICES

**ENG
APPL**

**INEER
ROVAL**

ENGINEER	DRAWING NAME
WM	TA-1-4-101N
CAD	PROJECT NUMBER
AK	AR20245
PROJECT MANAGER	APPROVED DRAWING DATE
SD	07-23-2021

RELEASE NUMBER
1

1

1

1

1

1

1


1

1

1

1

1

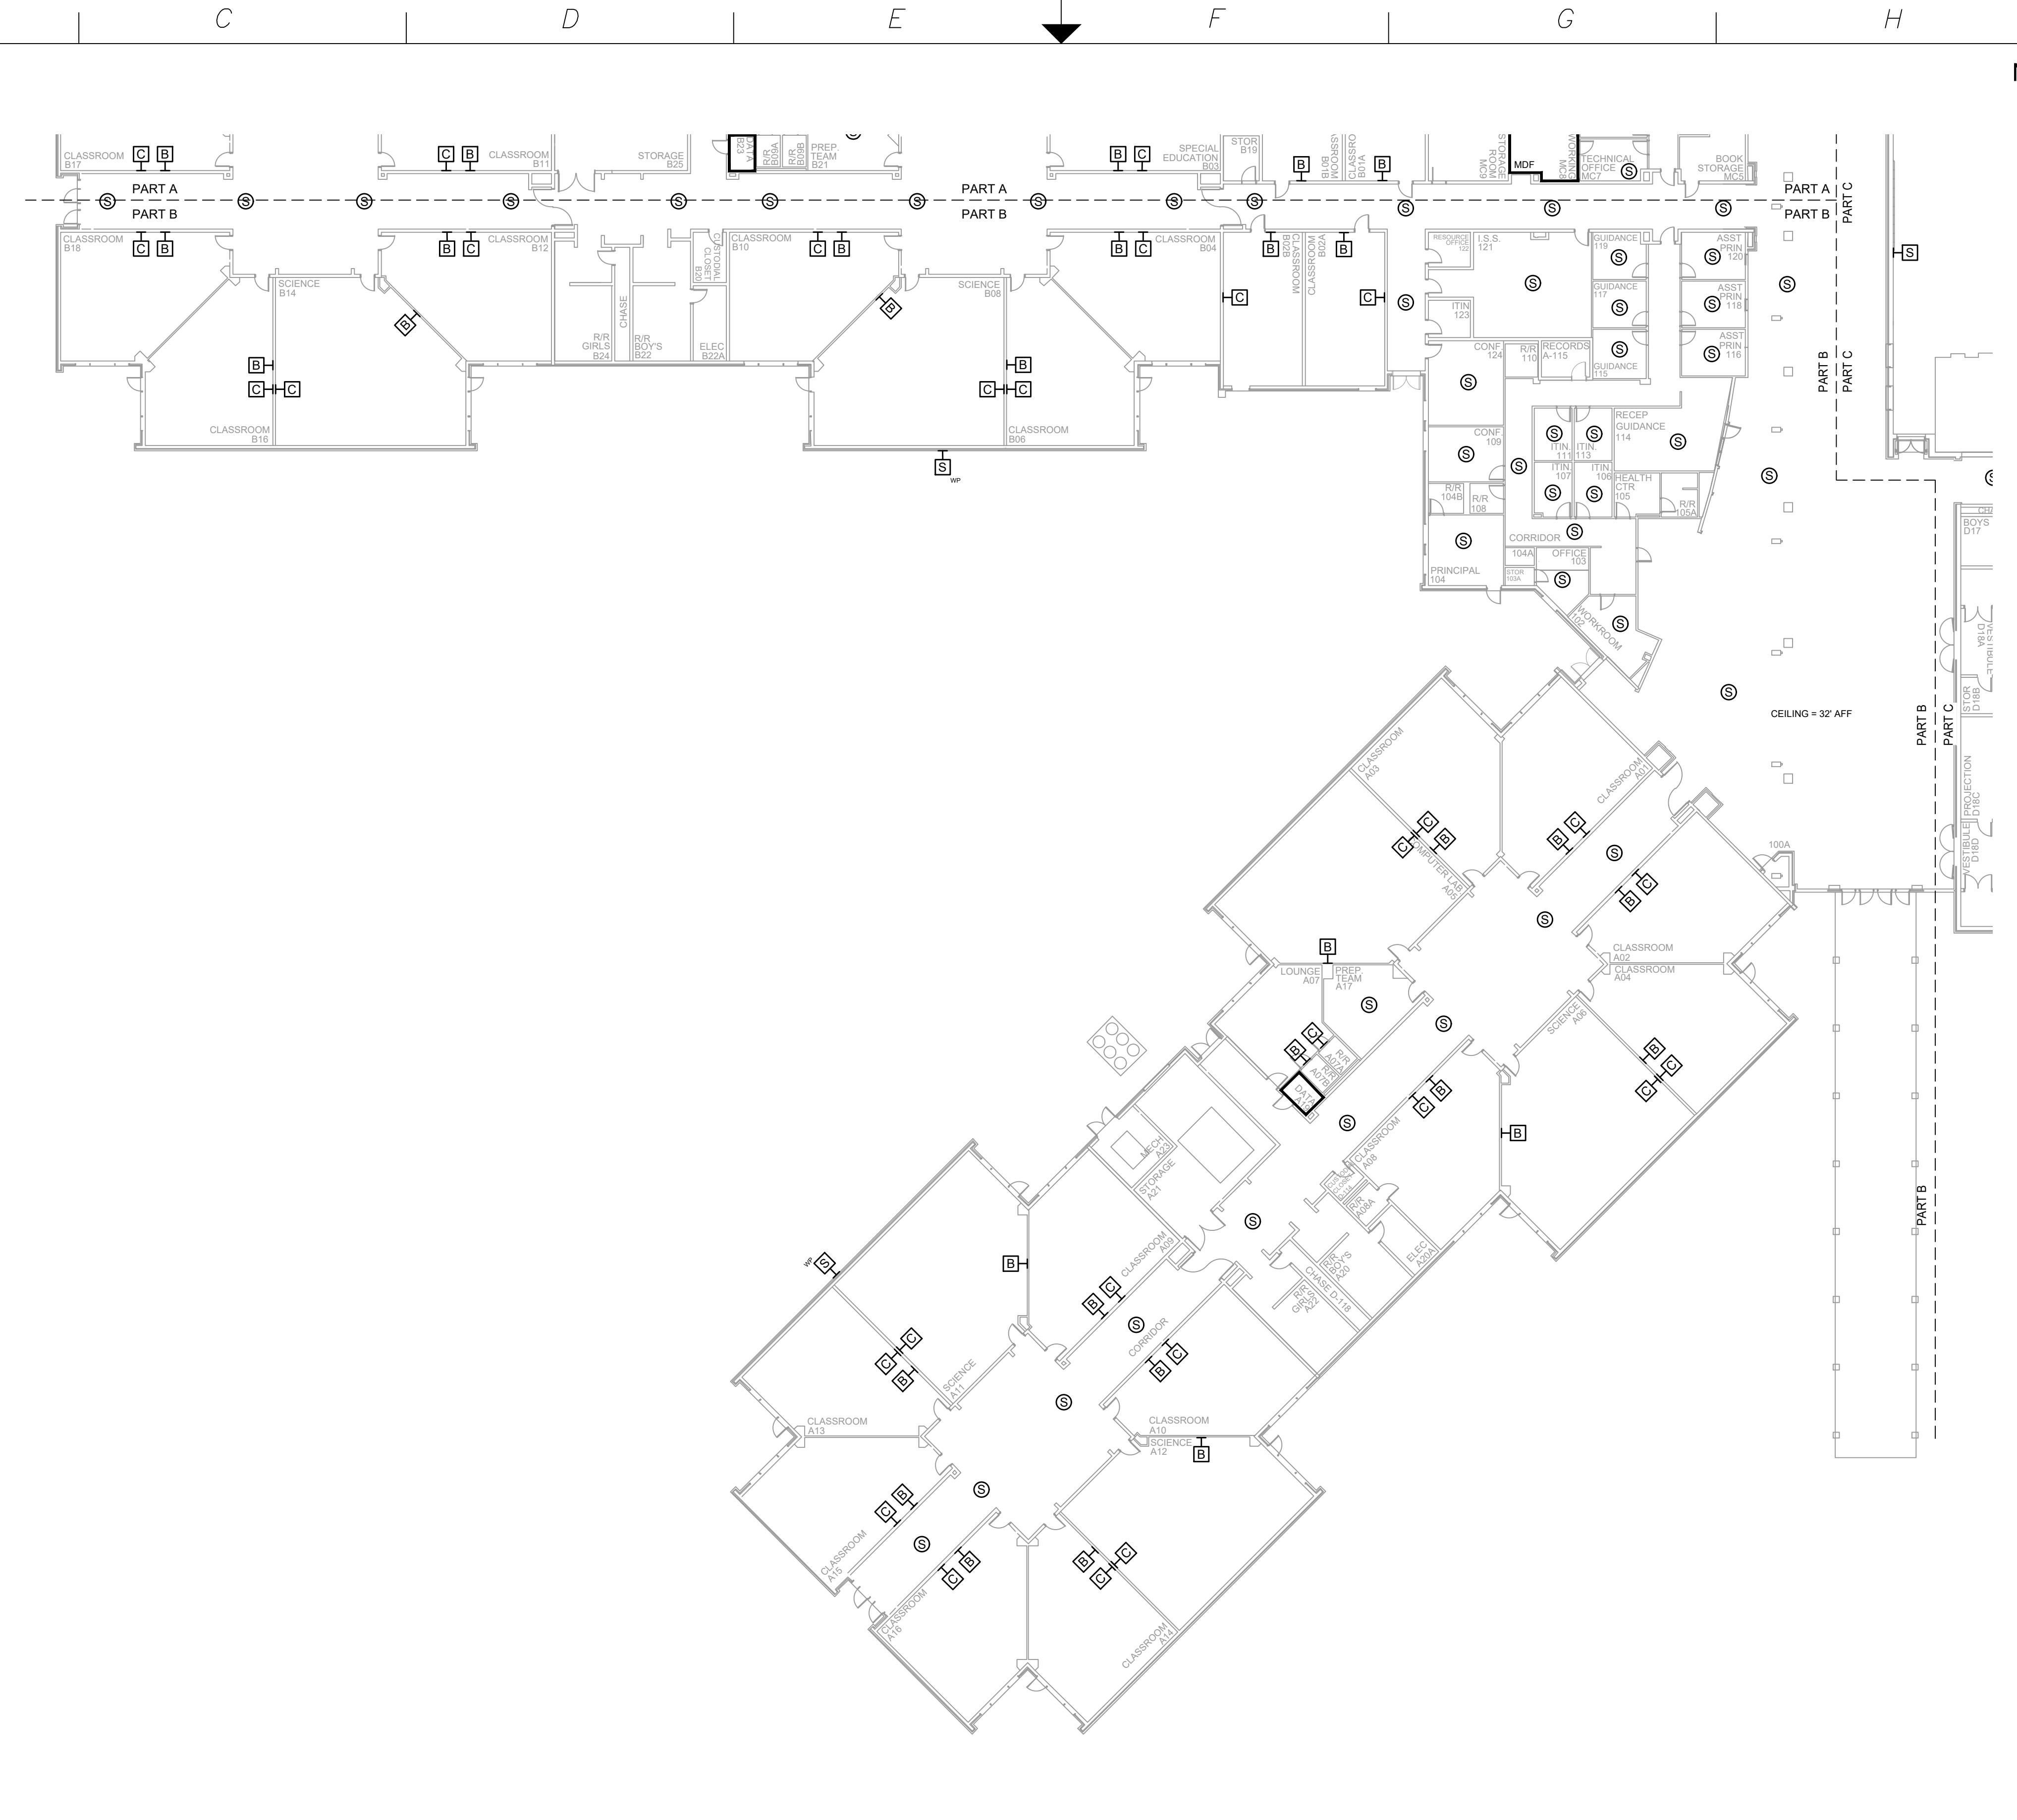

NOTES:

1. SEE DRAWING T-0-001 FOR SYMBOL LEGEND AND GENERAL NOTES.
2. CLASSROOMS & HALLWAY CEILINGS ARE 10' AFF.



Your Pathway to Connectivity

Atlanta, GA	770-662-5482	Augusta, GA	706-364-4190
Raleigh, NC	919-290-8010	Columbus, GA	706-571-9090
Toll Free	800-795-1975	Savannah, GA	912-748-8960

www.netplanner.com



CLIENT LOGO

PROJECT INFO

ROCK HILL SCHOOLS

ROCK HILL, SC

SHEET INFO

INTERCOM & NOTIFICATIONS

CASTLE HEIGHTS MIDDLE - PART B - NEW DEVICES

**ENGINE
APPRO**


ER
AL

GINEER
VM
D
K
PROJECT MANA
D

	DRAWING NAME
	TA-1-4-102N
	PROJECT NUMBER
ER	AR20245
	APPROVED DRAWING DATE
	07-23-2021


NOTES:

- SEE DRAWING T-0-001 FOR SYMBOL LEGEND AND GENERAL NOTES.
- CLASSROOMS & HALLWAY CEILINGS ARE 10' AFF.

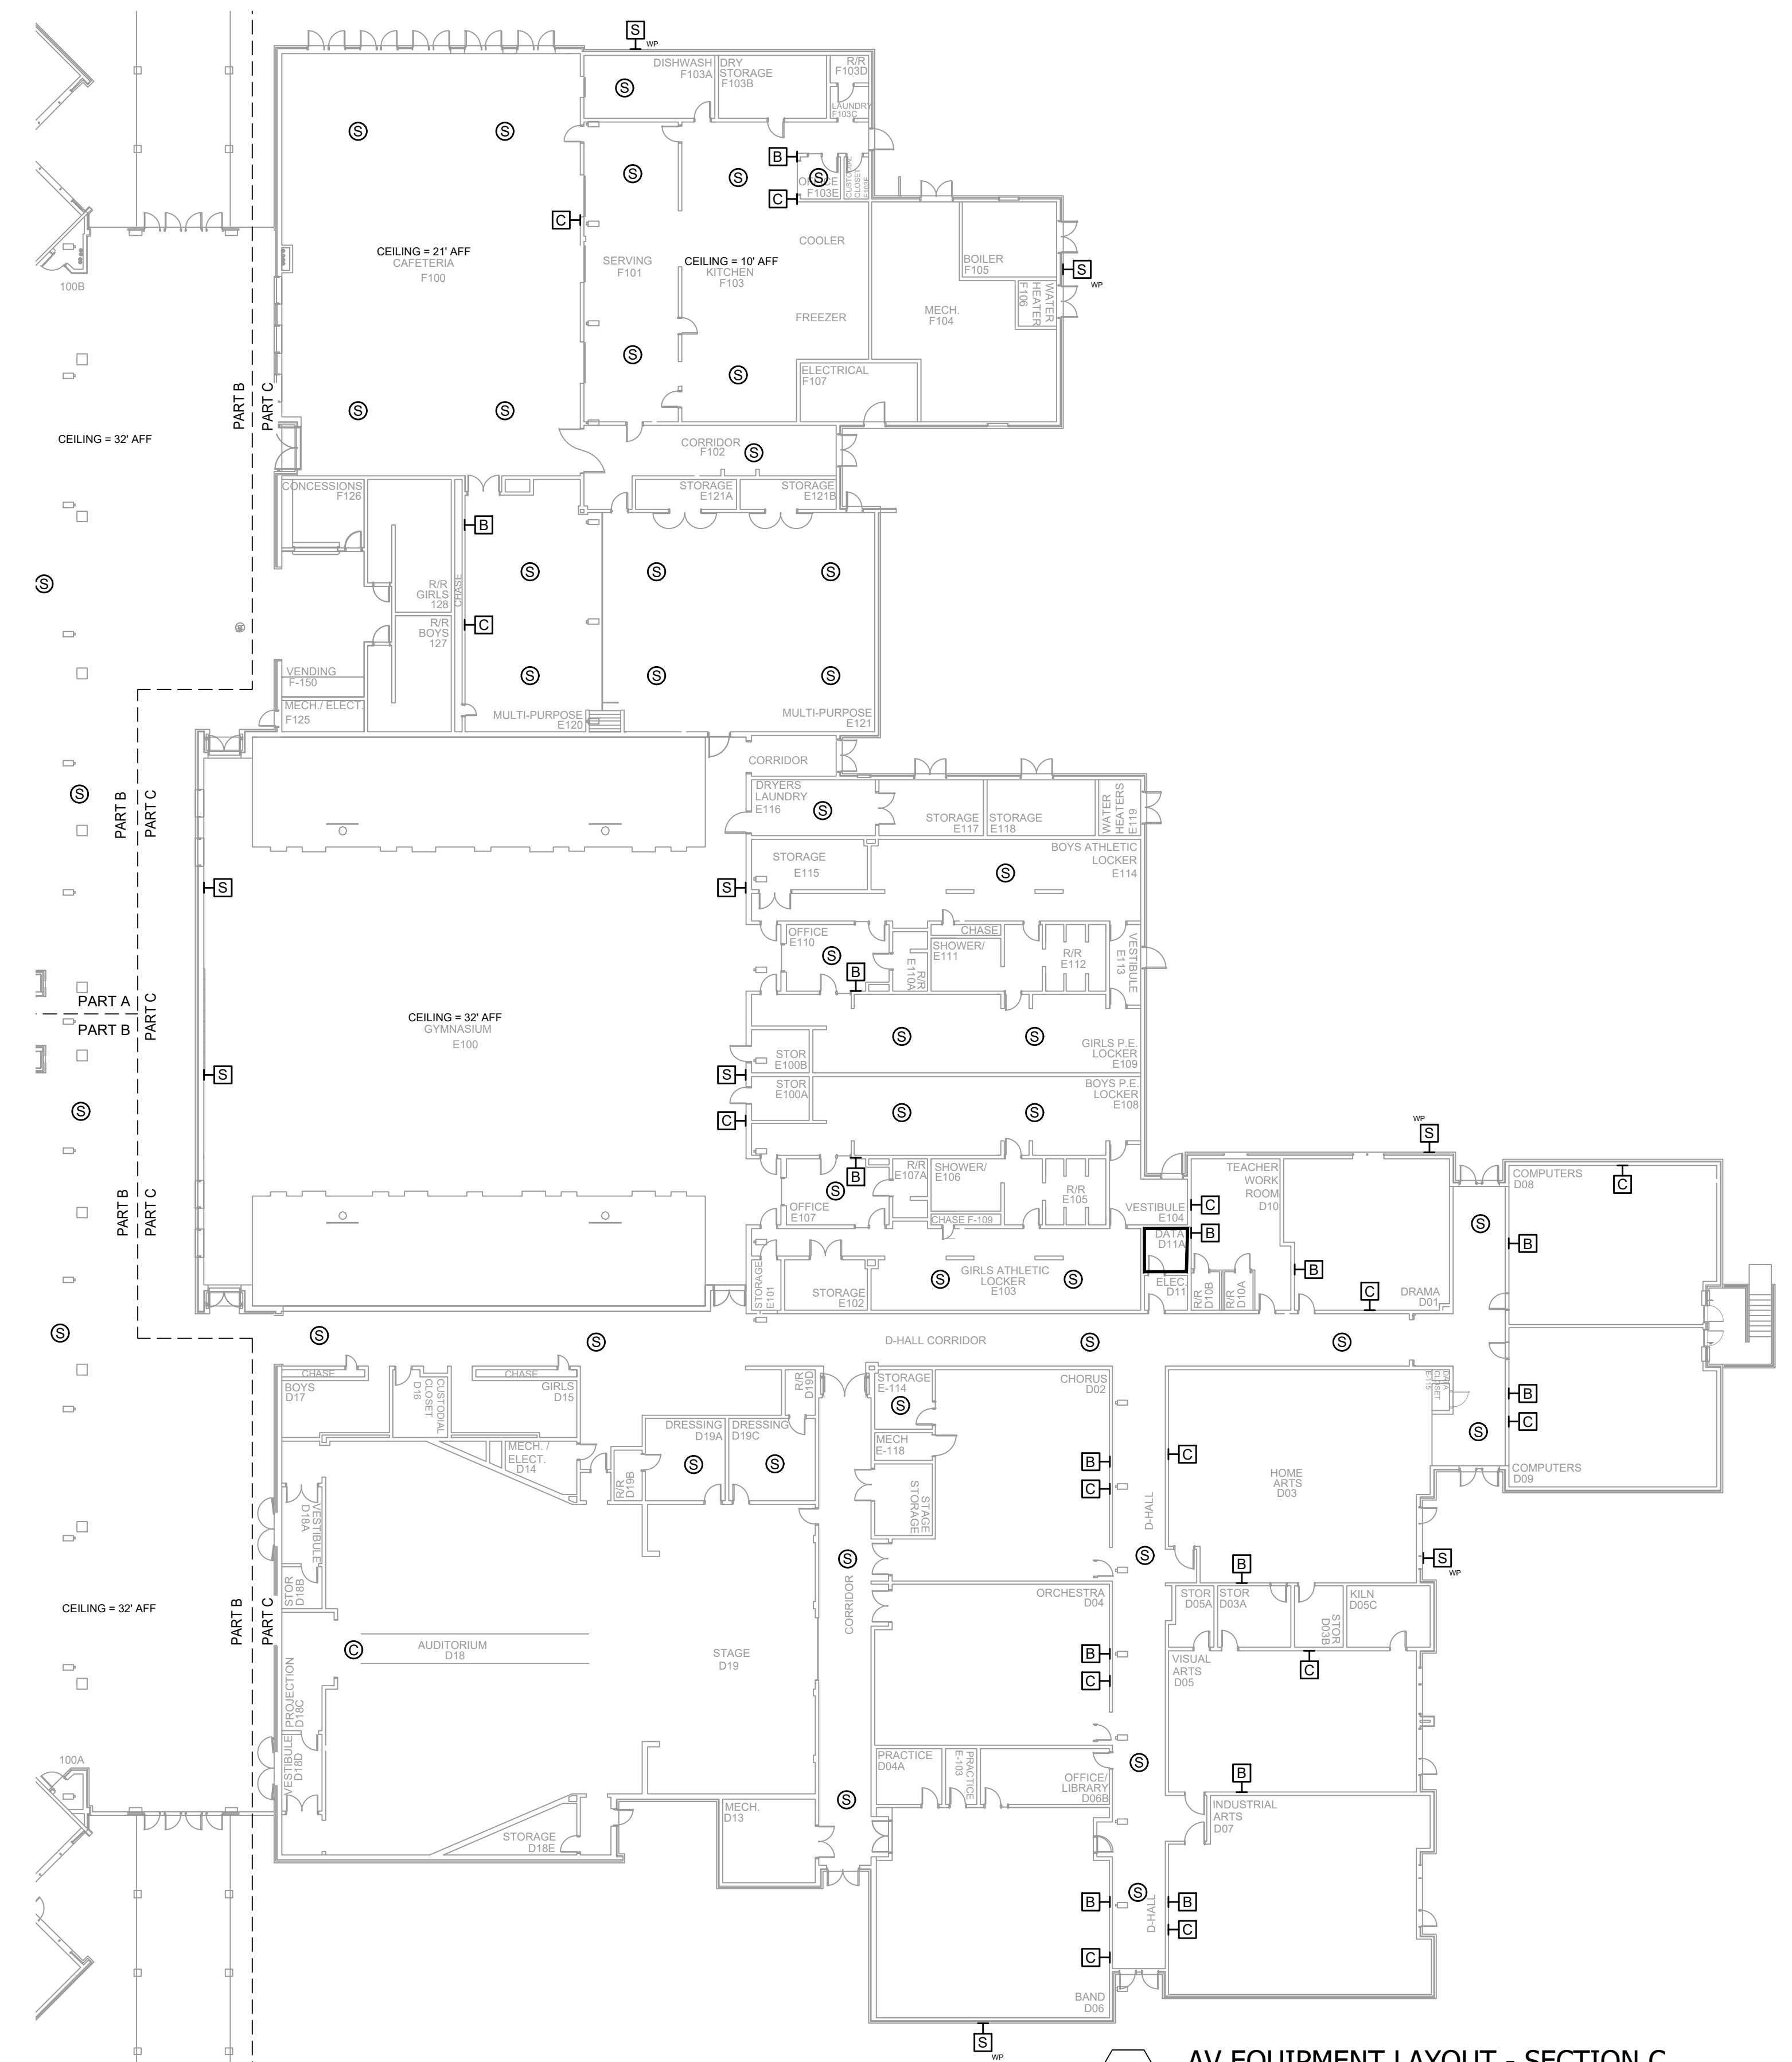

A B C D E F G H J K

NOTES:
1. SEE DRAWING T-0-001 FOR SYMBOL LEGEND AND GENERAL NOTES.

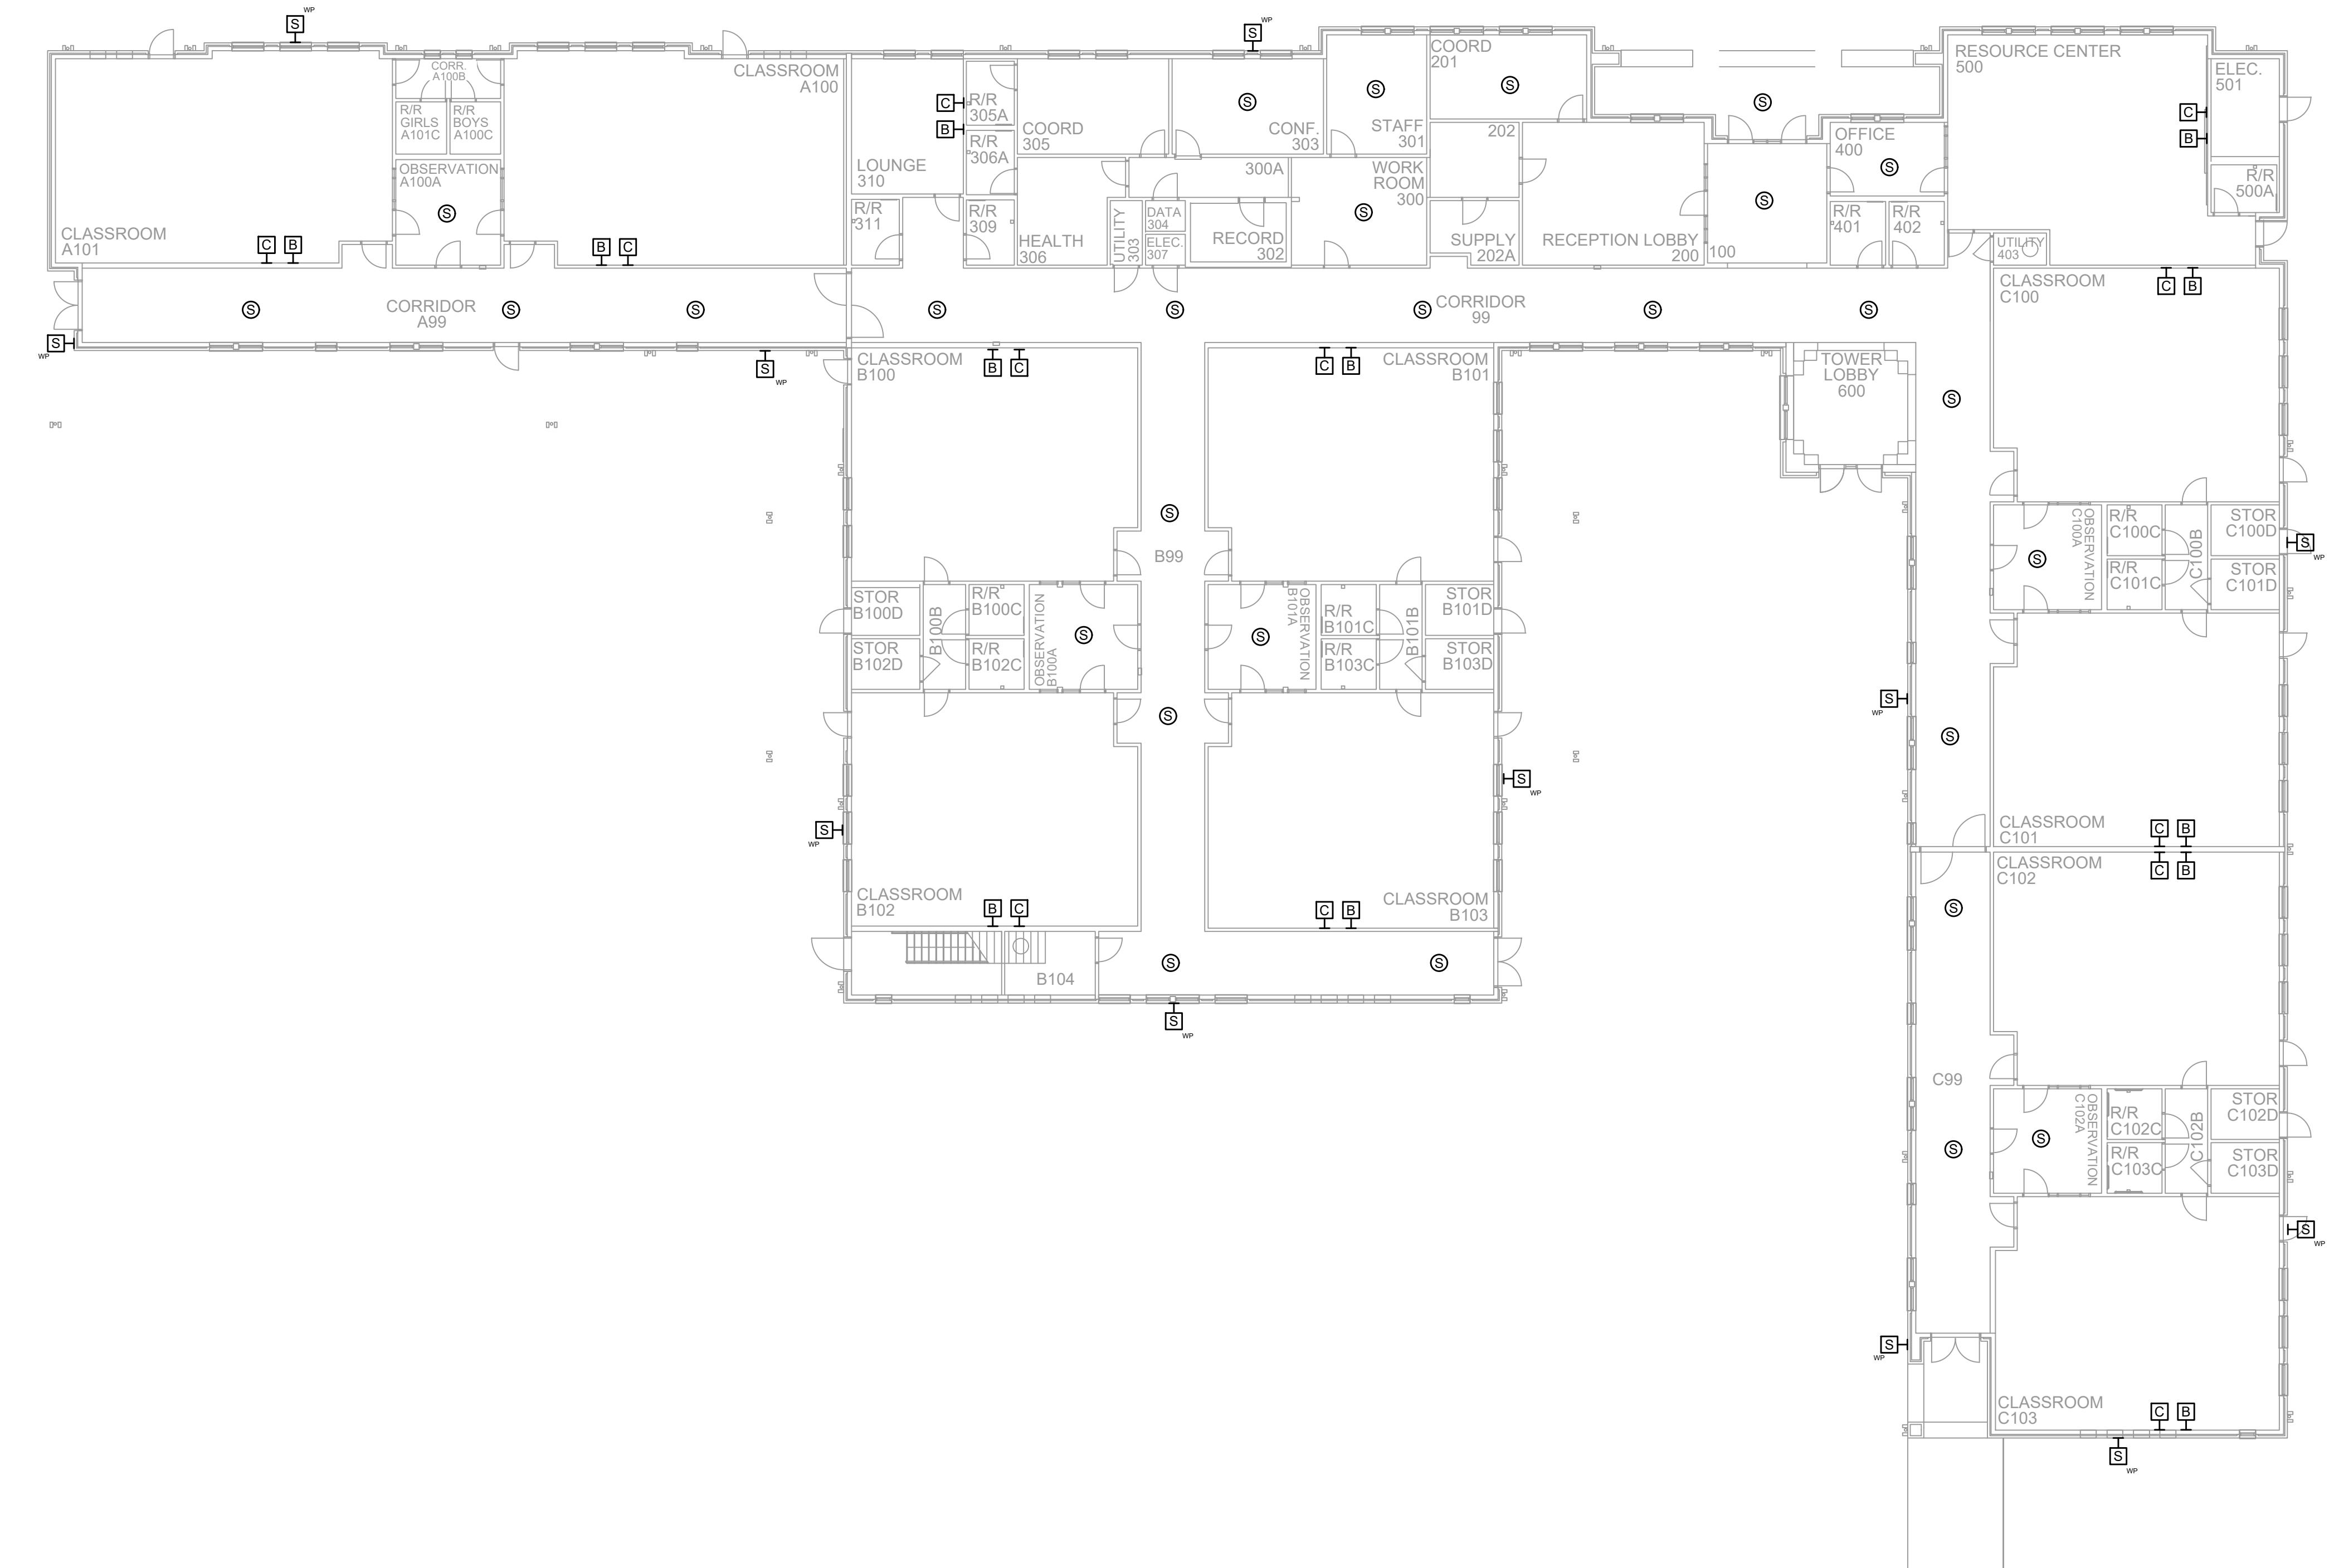

1 AV EQUIPMENT LAYOUT

SCALE: NTS



CLIENT LOGO

PROJECT INFO
ROCK HILL SCHOOLS
ROCK HILL, SC

SHEET INFO
INTERCOM & NOTIFICATIONS
CENTRAL CHILD DEVELOPMENT -
NEW DEVICES

REV.	DESCRIPTION	DATE	REVISIONS	
			ENGINEER APPROVAL	DRAWING NAME
			WM	TA-1-5-101N
			AK	PROJECT NUMBER
				AR20245
			SD	PROJECT MANAGER
				APPROVED DRAWING DATE
				07-23-2021
				RELEASE NUMBER
				1

A B C D E F G H J K

A B C D E F G H J K

NOTES:
1. SEE DRAWING T-0-001 FOR SYMBOL LEGEND
AND GENERAL NOTES.



REFER TO SULLIVAN
MIDDLE SCHOOL -
1ST FLOOR

1 AV EQUIPMENT LAYOUT - OVERALL

SCALE: NTS



A B C D E F G H J K



PROJECT INFO
ROCK HILL SCHOOLS
ROCK HILL, SC

SHEET INFO
INTERCOM & NOTIFICATIONS
CHERRY PARK ELEMENTARY - 1ST FLR
OVERALL - NEW DEVICES

REV.	DESCRIPTION	DATE	REVISIONS	
			ENGINEER APPROVAL	DRAWING NAME
			WM	TA-1-6-100N
			CAD	PROJECT NUMBER
			AK	AR20245
			SD	PROJECT MANAGER
				APPROVED DRAWING DATE
				07-23-2021
				RELEASE NUMBER
				1

A B C D E F G H J K

A B C D E F G H J K

NOTES:
1. SEE DRAWING T-0-001 FOR SYMBOL LEGEND
AND GENERAL NOTES.



REFER TO SULLIVAN MIDDLE SCHOOL DRAWINGS

1 AV EQUIPMENT LAYOUT
SCALE: NTS



PROJECT INFO
ROCK HILL SCHOOLS
ROCK HILL, SC


SHEET INFO
INTERCOM & NOTIFICATIONS
CHERRY PARK ELEMENTARY - 1ST FLR -
NEW DEVICES

REV.	DESCRIPTION	DATE	REVISIONS	
			ENGINEER APPROVAL	ENGINEER DRAWING NAME
			WM	TA-1-6-101N
			CAD	PROJECT NUMBER
			AK	AR20245
			SD	PROJECT MANAGER APPROVED DRAWING DATE RELEASE NUMBER
				07-23-2021 1

A B C D E F G H J K

A B C D E F G H J K

NOTES:
1. SEE DRAWING T-0-001 FOR SYMBOL LEGEND
AND GENERAL NOTES.

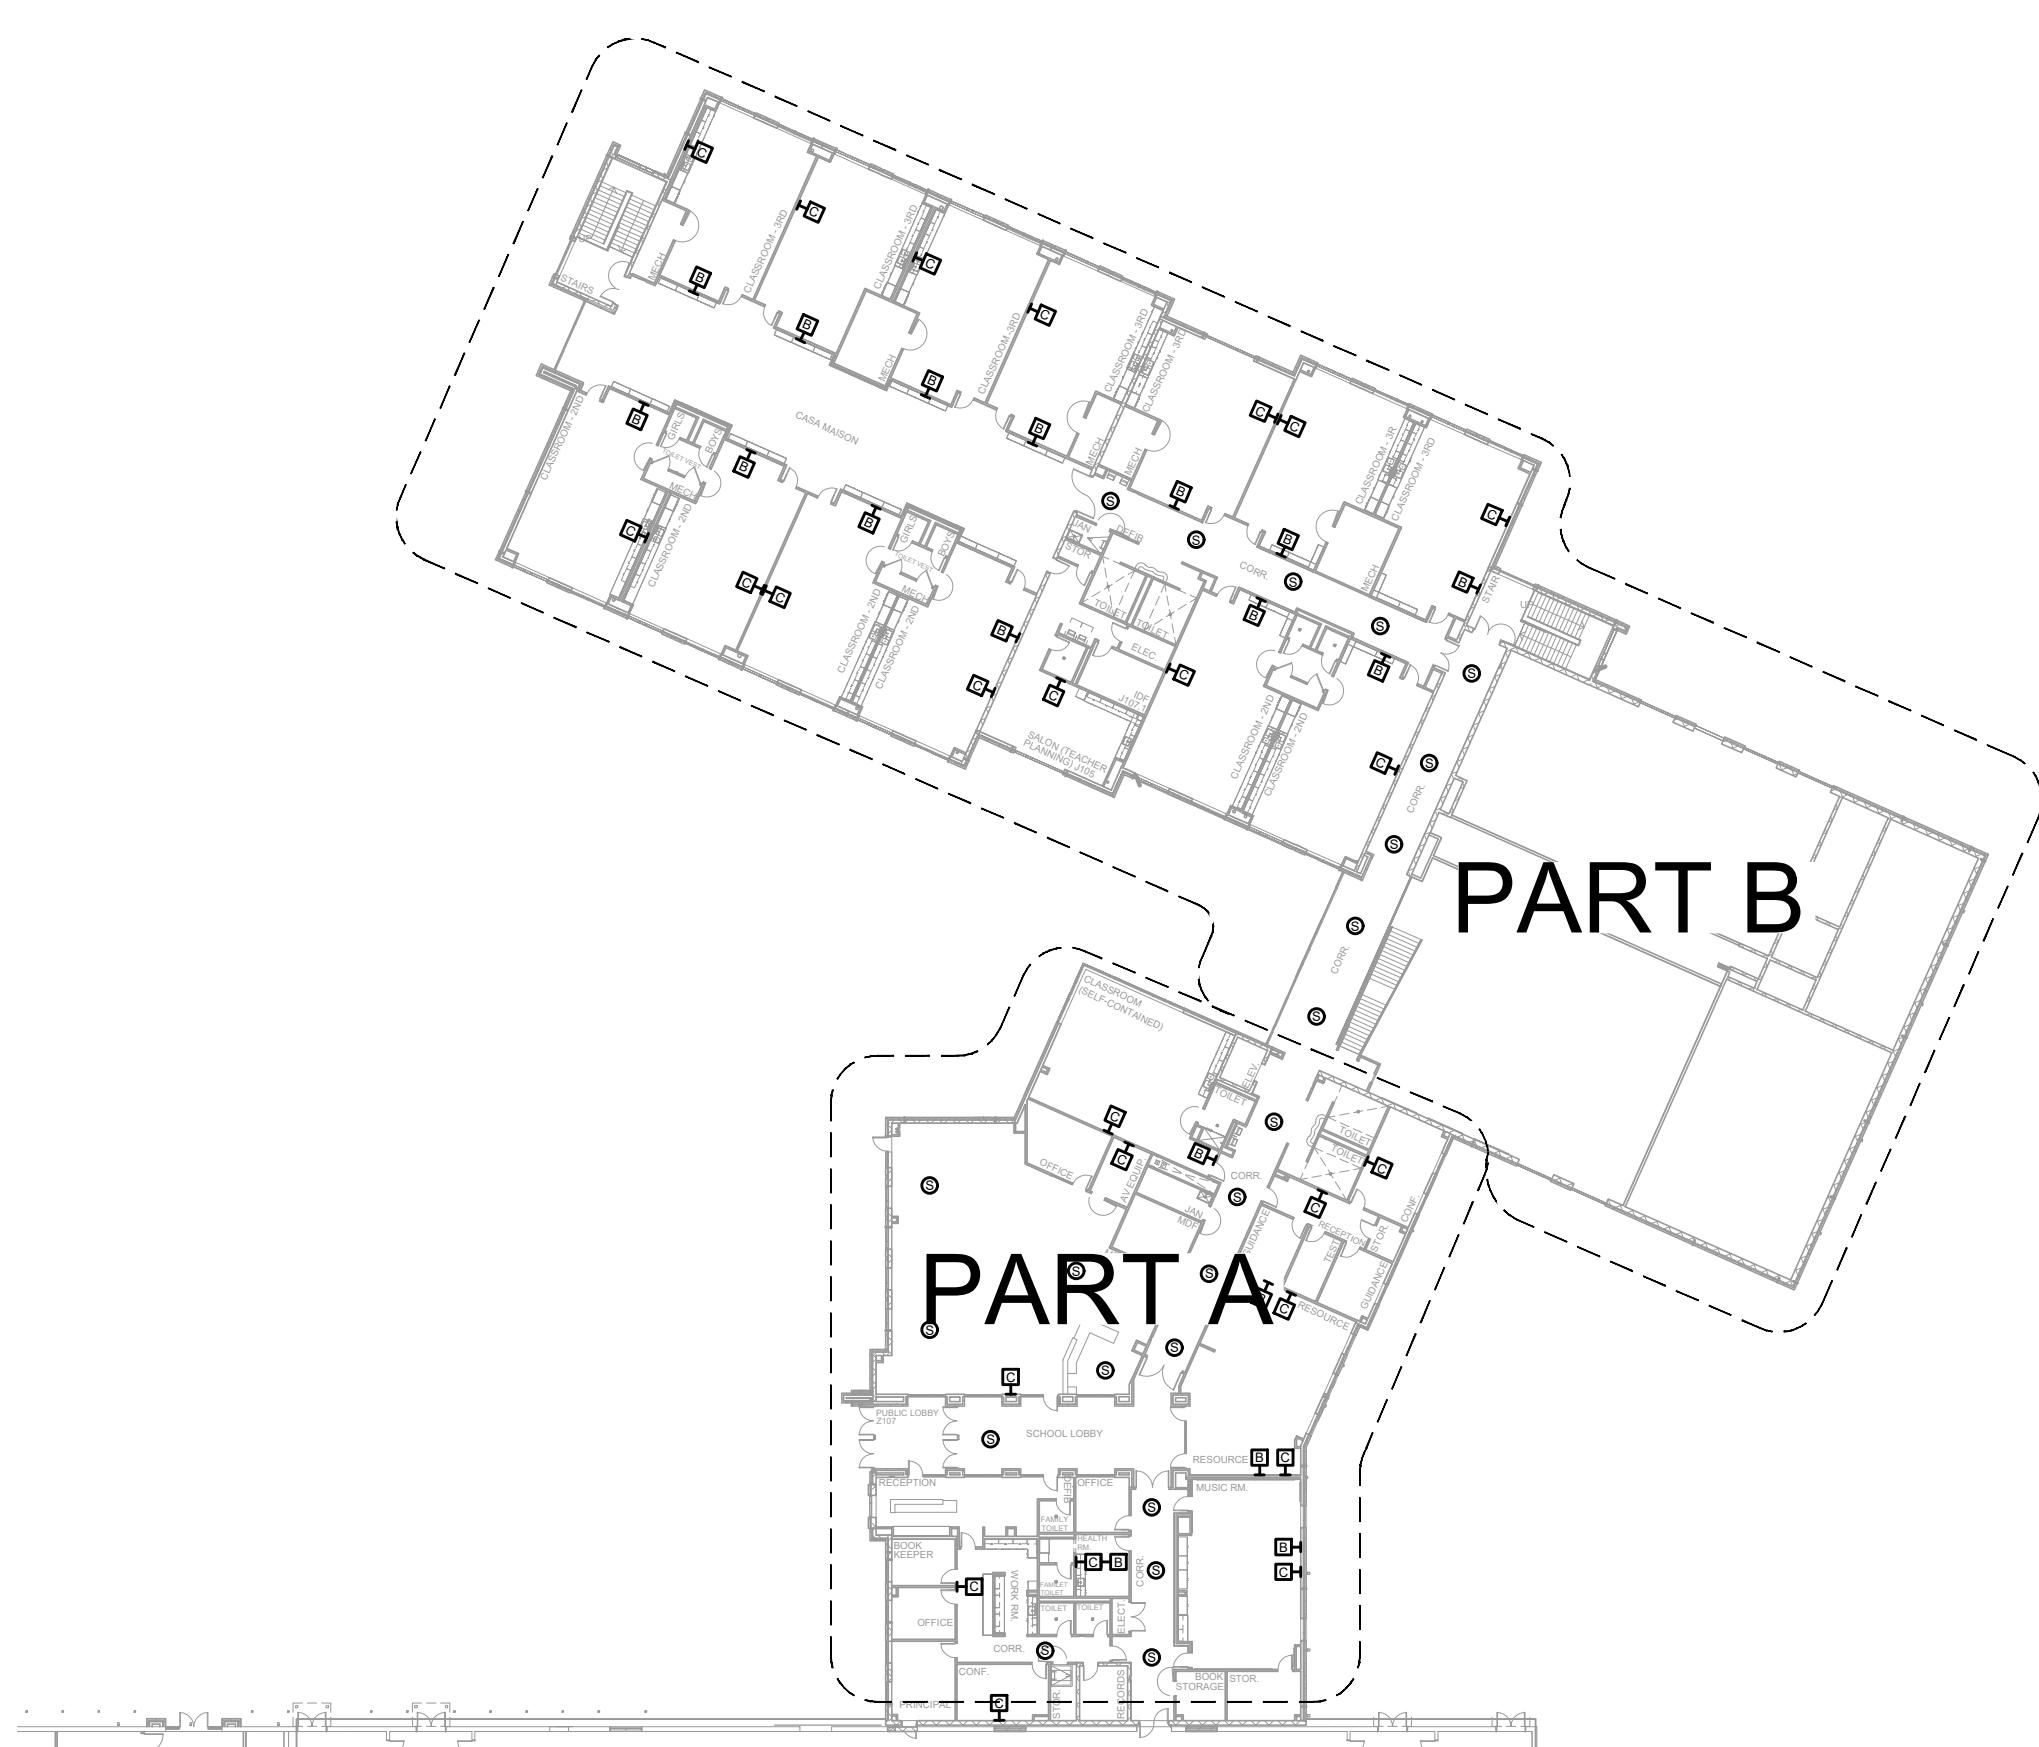

REFER TO SULLIVAN
MIDDLE SCHOOL -
2ND FLOOR

1 AV EQUIPMENT LAYOUT

SCALE: NTS



CLIENT LOGO

PROJECT INFO
ROCK HILL SCHOOLS
ROCK HILL, SC

SHEET INFO
INTERCOM & NOTIFICATIONS
CHERRY PARK ELEMENTARY - 2ND FLR
OVERALL - NEW DEVICES

REV.	DESCRIPTION	DATE	REVISIONS	
			ENGINEER APPROVAL	ENGINEER DRAWING NAME
			WM	TA-1-6-200N
			CAD	PROJECT NUMBER
			AK	AR20245
			SD	PROJECT MANAGER APPROVED DRAWING DATE RELEASE NUMBER
				07-23-2021 1

A	B	C	D	E	F	G	H	J	K
1	2	3	4	5	6	7	8	9	10

NOTES:
1. SEE DRAWING T-0-001 FOR SYMBOL LEGEND AND GENERAL NOTES.



1 AV EQUIPMENT LAYOUT
SCALE: NTS

REV.	DESCRIPTION	DATE	REVISIONS	
			ENGINEER APPROVAL	DRAWING NAME
				TA-1-6-201N
				PROJECT NUMBER
			AK	AR20245
			PROJECT MANAGER	APPROVED DRAWING DATE
				07-23-2021
			SD	RELEASE NUMBER
				1

A B C D E F G H J K

NOTES:
1. SEE DRAWING T-0-001 FOR SYMBOL LEGEND
AND GENERAL NOTES.



1 AV EQUIPMENT LAYOUT

SCALE: NTS



CLIENT LOGO

PROJECT INFO
ROCK HILL SCHOOLS
ROCK HILL, SC

SHEET INFO
INTERCOM & NOTIFICATIONS
DISTRICT OFFICE - 1ST FLOOR -
NEW DEVICES

REV.	DESCRIPTION	DATE	REVISIONS	
			ENGINEER APPROVAL	ENGINEER DRAWING NAME
			WM	TA-1-7-101N
			CAD	PROJECT NUMBER
			AK	AR20245
			PROJECT MANAGER	APPROVED DRAWING DATE
			SD	07-23-2021
				RELEASE NUMBER
				1

A

B

C

D

E

F

G


H

J

K

A B C D E F G H J K

NOTES:
1. SEE DRAWING T-0-001 FOR SYMBOL LEGEND
AND GENERAL NOTES.

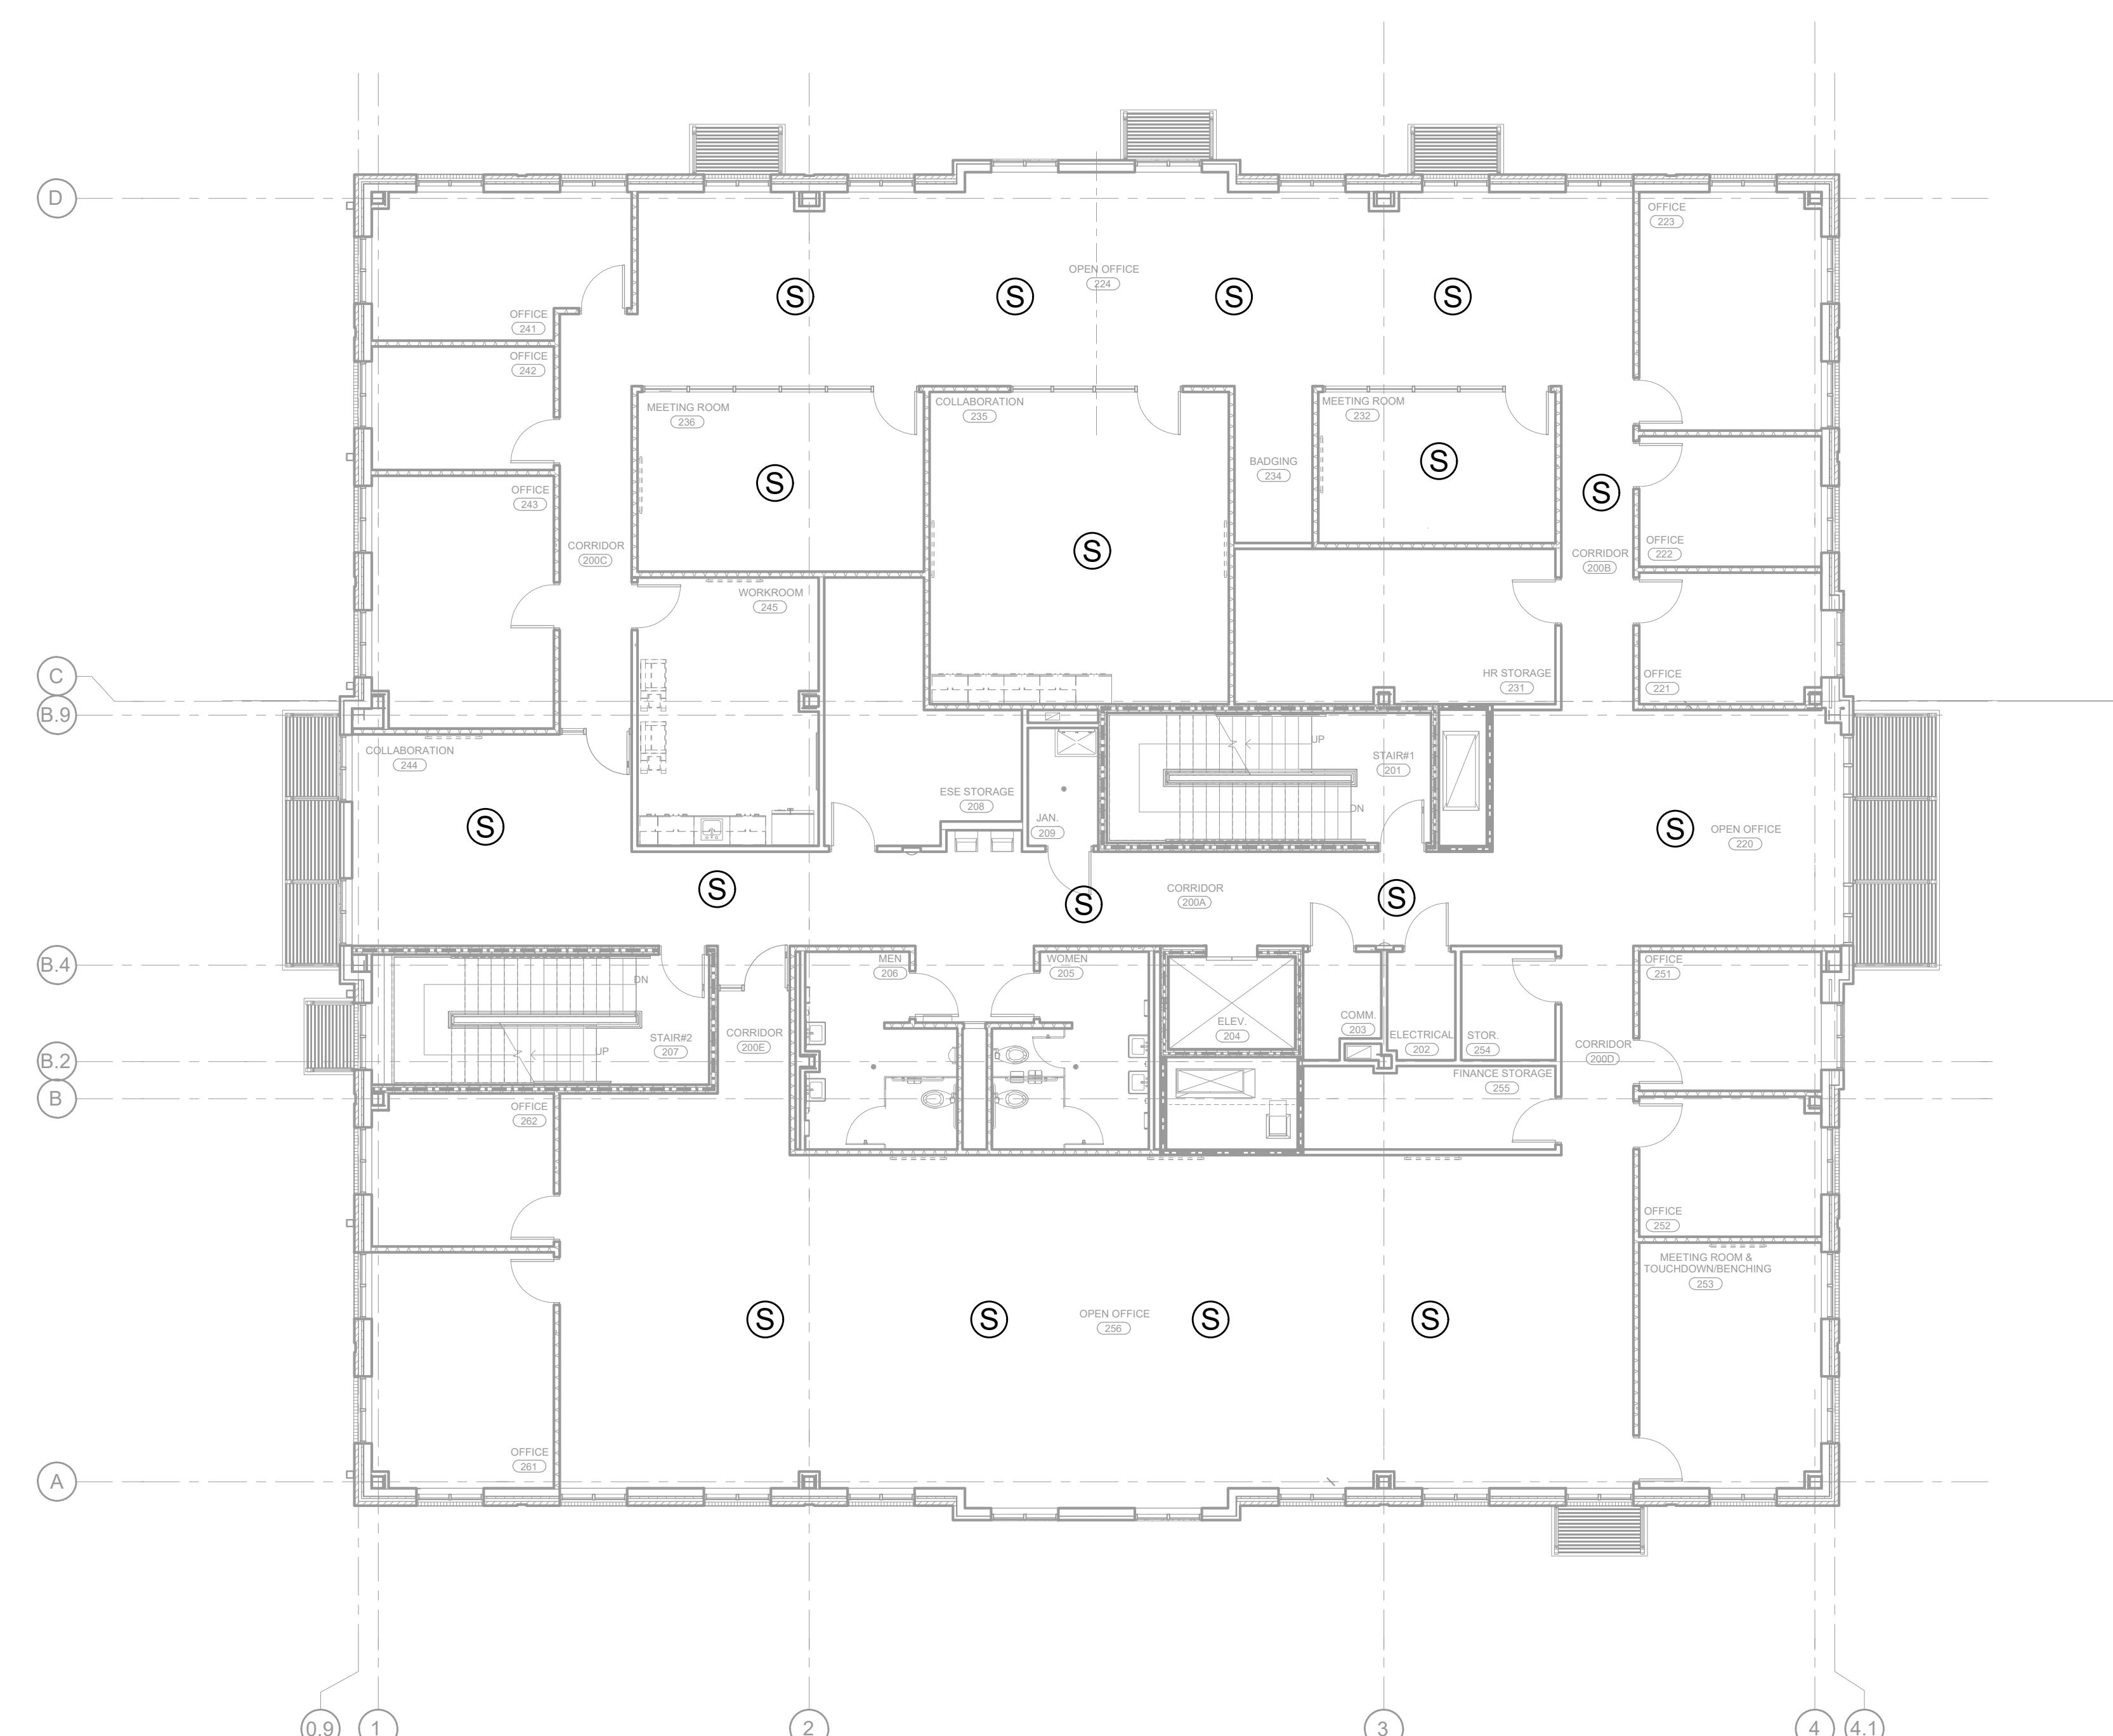

1 AV EQUIPMENT LAYOUT

SCALE: NTS

REVISIONS		
REV.	DESCRIPTION	DATE


ENGINEER APPROVAL	ENGINEER	DRAWING NAME
	WM	TA-1-7-201N
CAD	AK	PROJECT NUMBER
	AR20245	RELEASE NUMBER
PROJECT MANAGER	APPROVED DRAWING DATE	07-23-2021
SD	RELEASE NUMBER	1

A B C D E F G H J K

A | *B* | *C* | *D* | *E* | *F* | *G* | *H* | *J* | *K*


NOTES:

1. SEE DRAWING T-0-001 FOR SYMBOL LEGEND AND GENERAL NOTES.

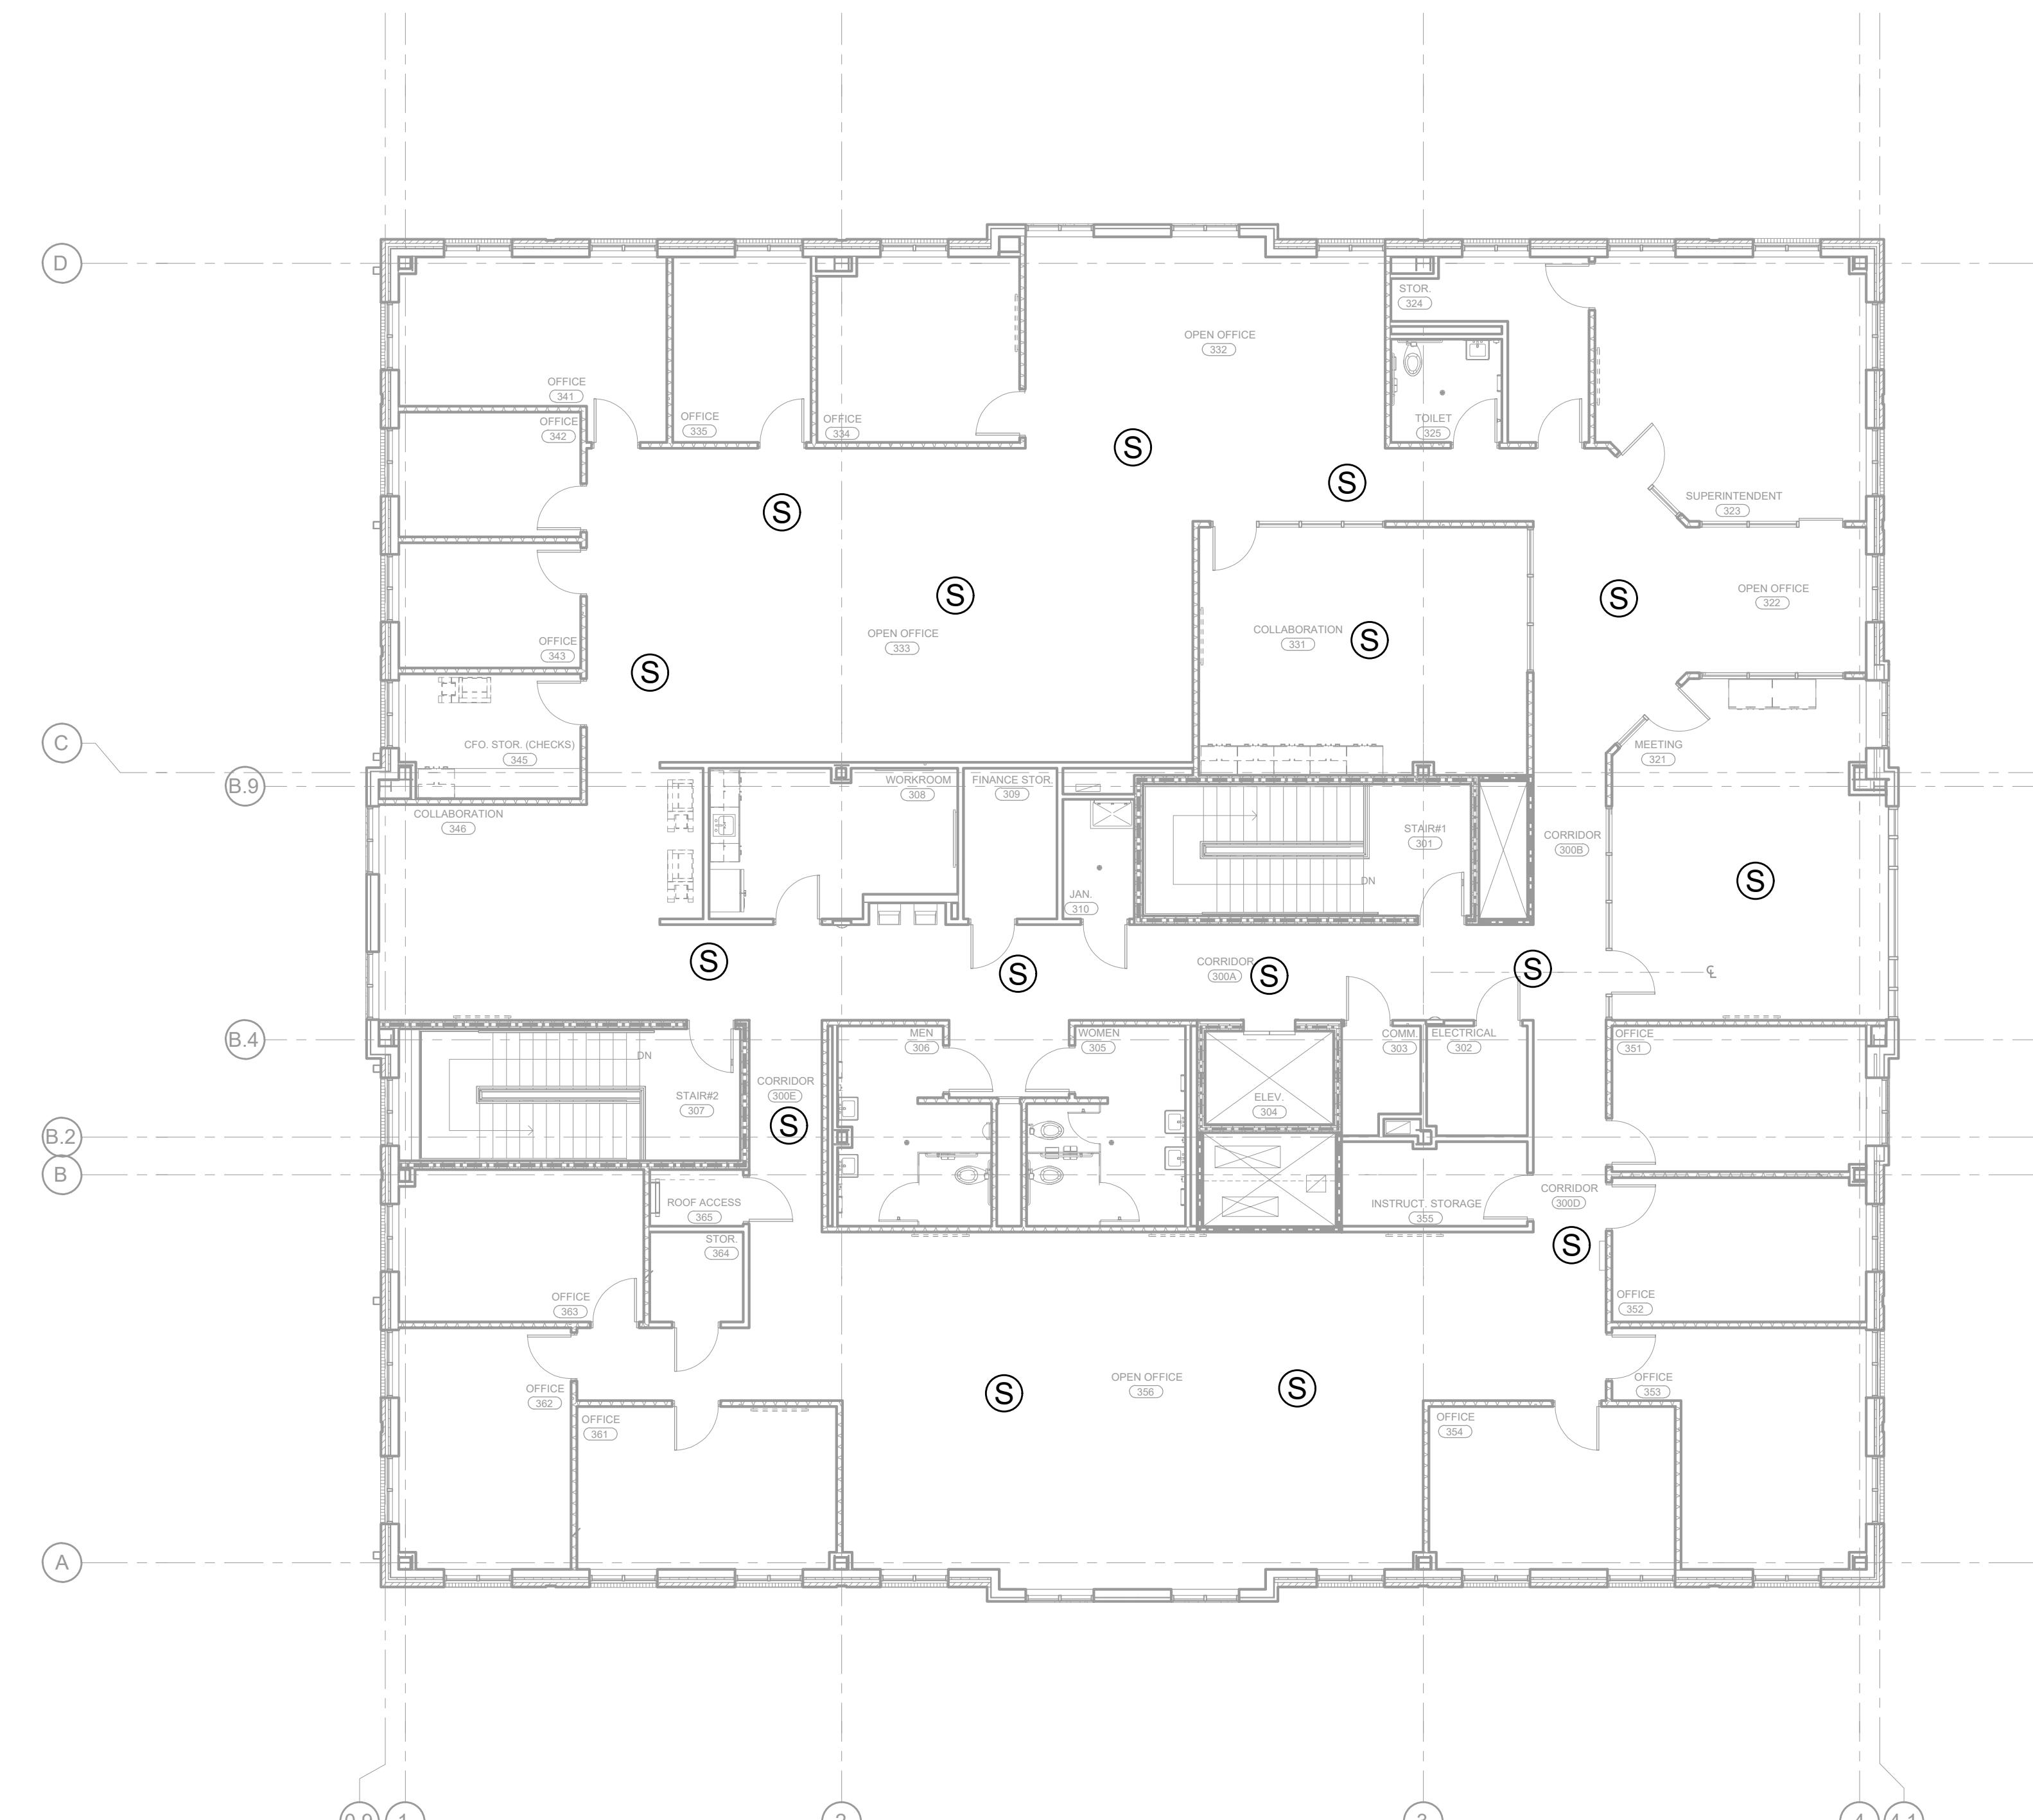

AV EQUIPMENT LAYOUT

 SCALE-NTC

 NetPlanner SYSTEMS, INC. [®] <i>Your Pathway to Connectivity</i> Atlanta, GA 770-662-5482 Augusta, GA 706-364-4190 Raleigh, NC 919-290-8010 Columbus, GA 706-571-9090 Toll Free 800-795-1975 Savannah, GA 912-748-8960 www.netplanner.com		CLIENT LOGO 	PROJECT INFO ROCK HILL SCHOOLS ROCK HILL, SC DISTRICT OFFICE - 3RD FLOOR - NEW DEVICES		REVISIONS REV. DESCRIPTION DATE	ENGINEER APPROVAL WM CAD AK PROJECT MANAGER SD	DRAWING NAME TA-1-7-301N PROJECT NUMBER AR20245 APPROVED DRAWING DATE 07-23-2021	RELEASE NUMBER 1

A

B

C

D

E

F

G


H

J


K

NOTES:

1. SEE DRAWING T-0-001 FOR SYMBOL LEGEND AND GENERAL NOTES.

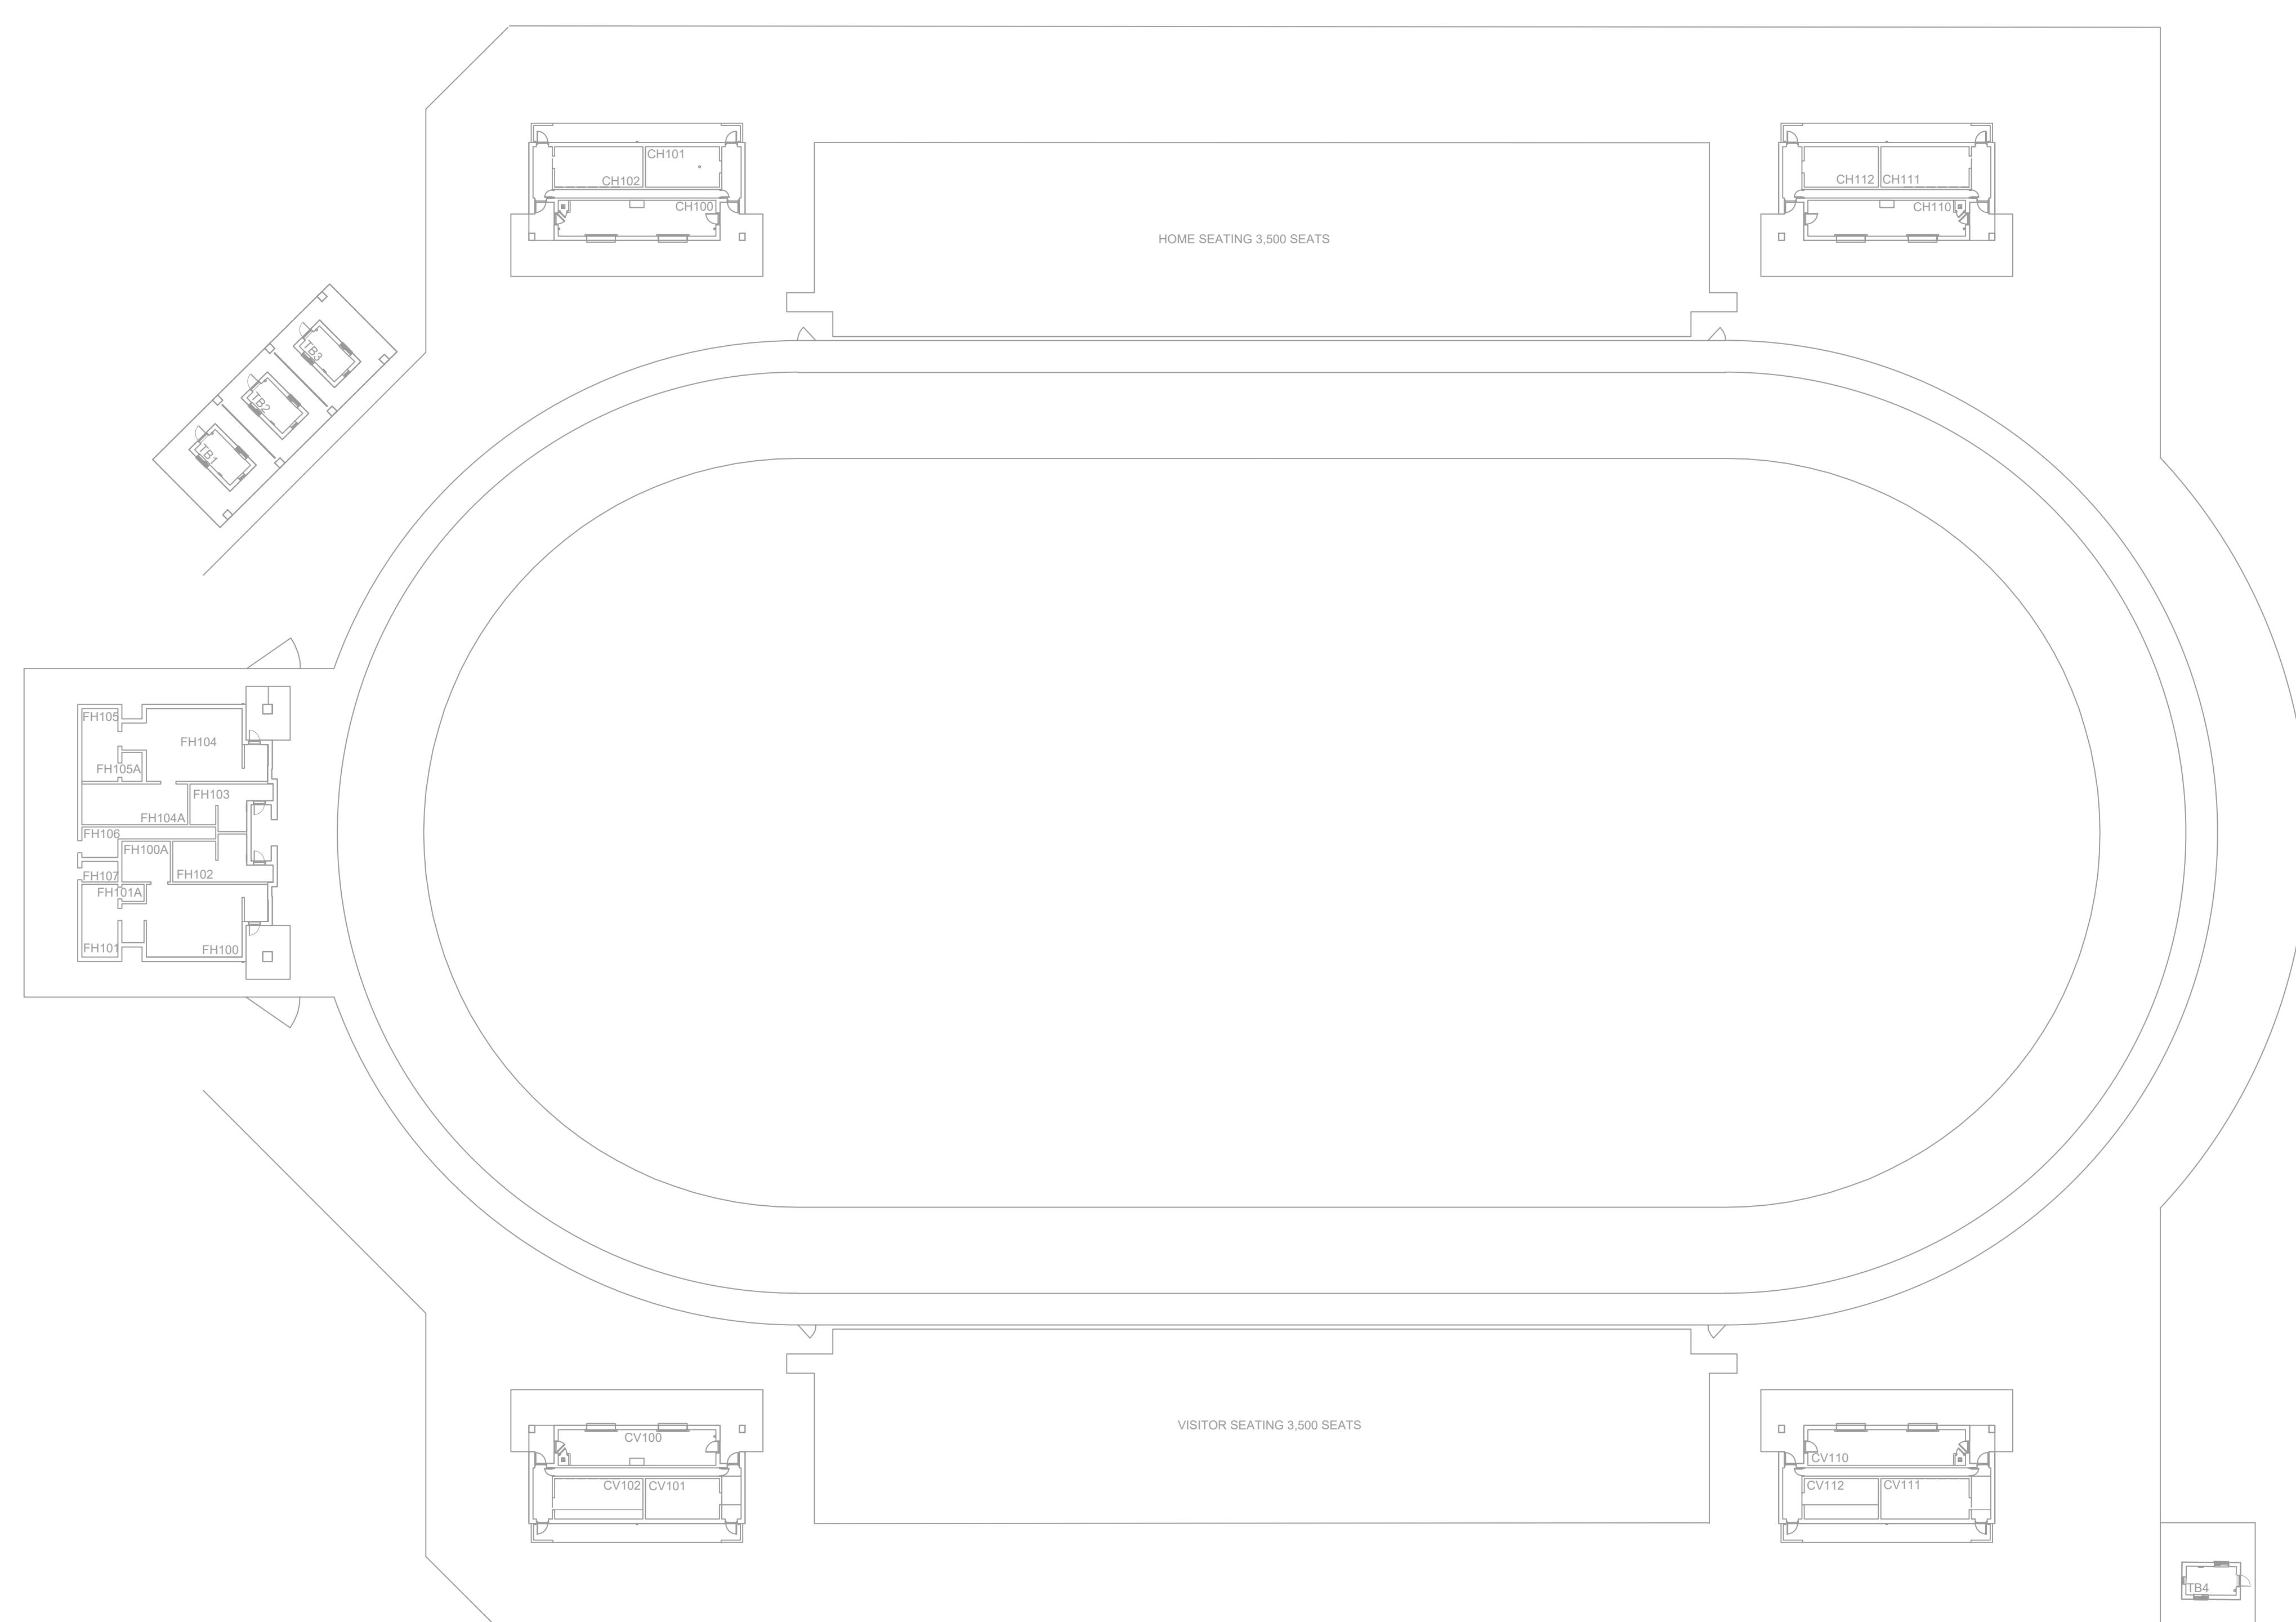

SCALE: NTS

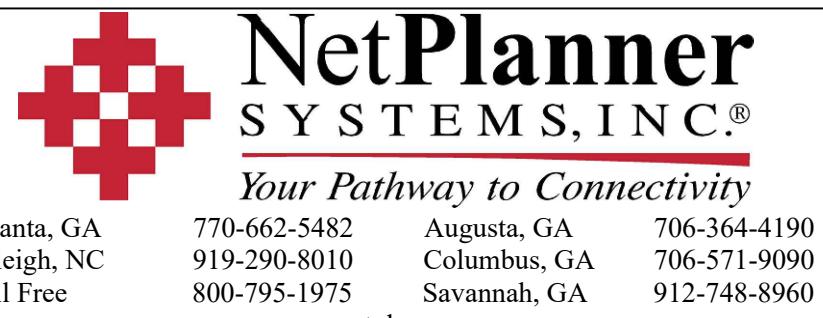

CLIENT LOGO

PROJECT INFO
ROCK HILL SCHOOLS
ROCK HILL, SC

SHEET INFO
INTERCOM & NOTIFICATIONS
DISTRICT THREE SOUTH STADIUM -
NEW DEVICES

REV.	DESCRIPTION	DATE	REVISIONS	
			ENGINEER APPROVAL	DRAWING NAME
			WM	TA-1-8-101N
			CAD	PROJECT NUMBER
			AK	AR20245
			PROJECT MANAGER	APPROVED DRAWING DATE
			SD	07-23-2021
				RELEASE NUMBER
				1

A

B

C

D

E

F

G


H

J

K

A B C D E F G H J K

NOTES:
1. SEE DRAWING T-0-001 FOR SYMBOL LEGEND AND GENERAL NOTES.

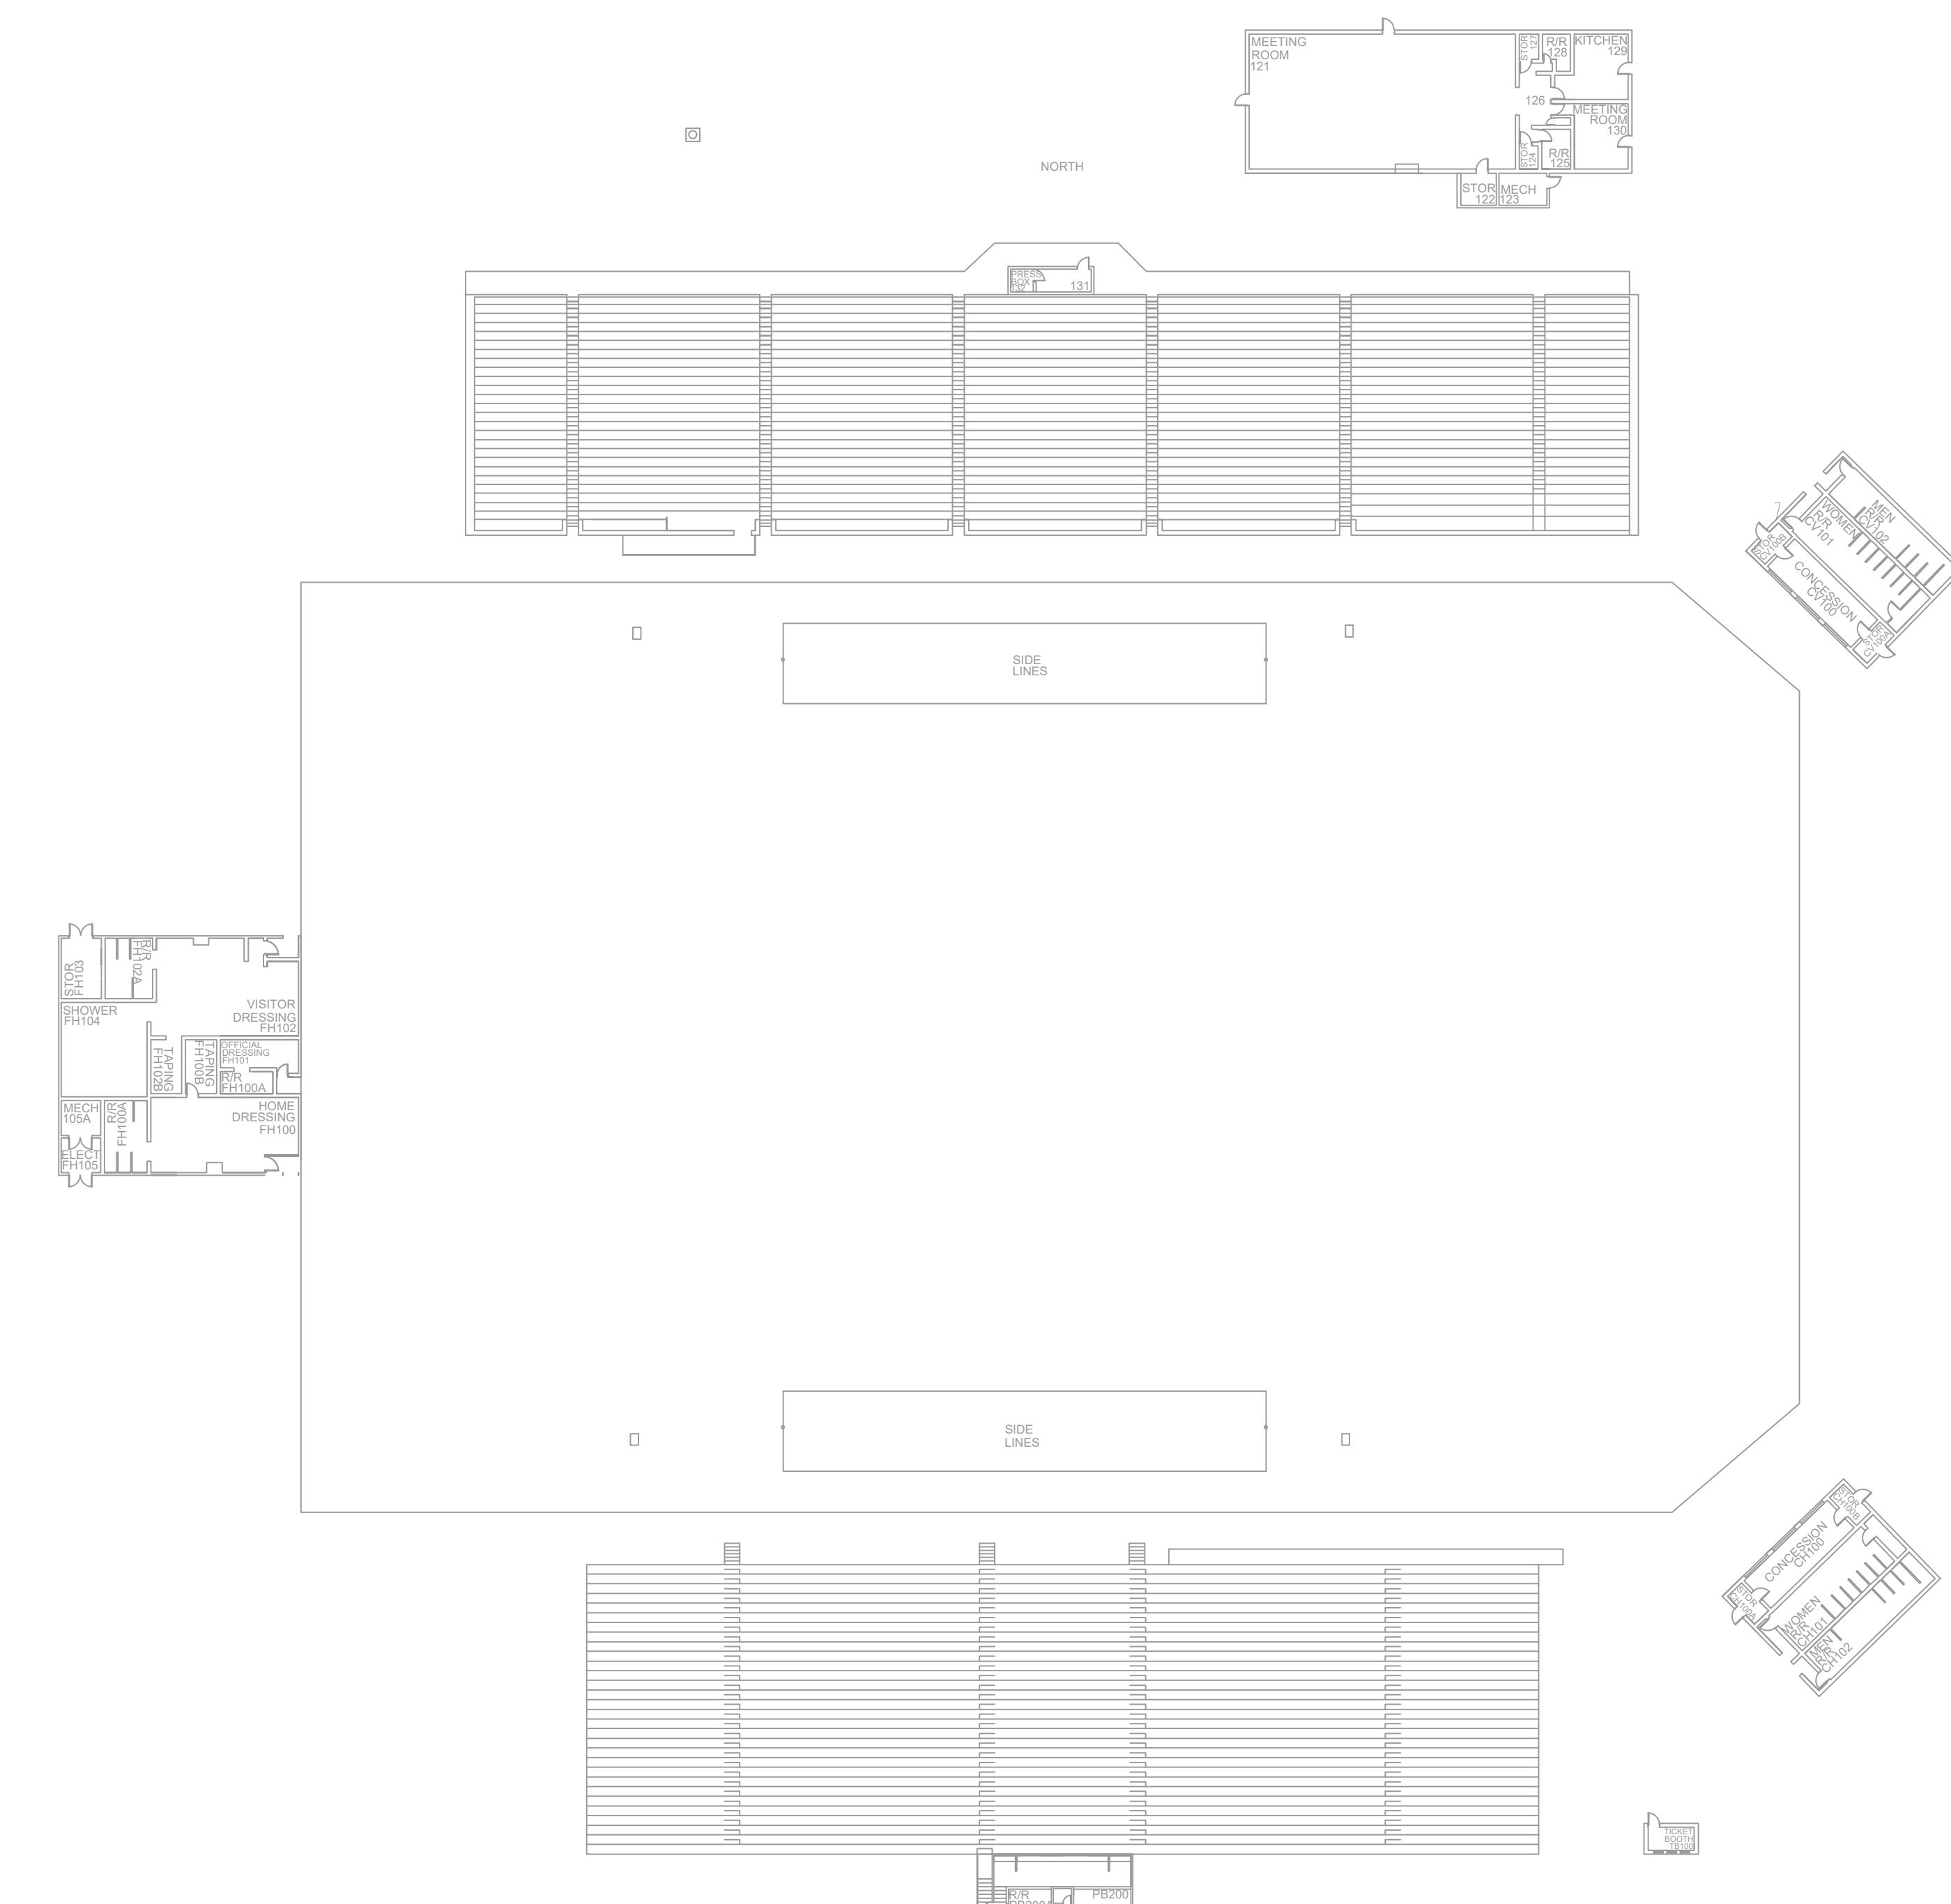

1 AV EQUIPMENT LAYOUT

SCALE: NTS



PROJECT INFO
ROCK HILL SCHOOLS
ROCK HILL, SC

INTERCOM & NOTIFICATIONS
DISTRICT THREE STADIUM - NEW
DEVICES

SHEET INFO

REVISIONS


REV.	DESCRIPTION	DATE

ENGINEER APPROVAL

WM	DRAWING NAME
CAD	PROJECT NUMBER
AK	AR20245
SD	APPROVED DRAWING DATE 07-23-2021


RELEASE NUMBER
1

A B C D E F G H J K

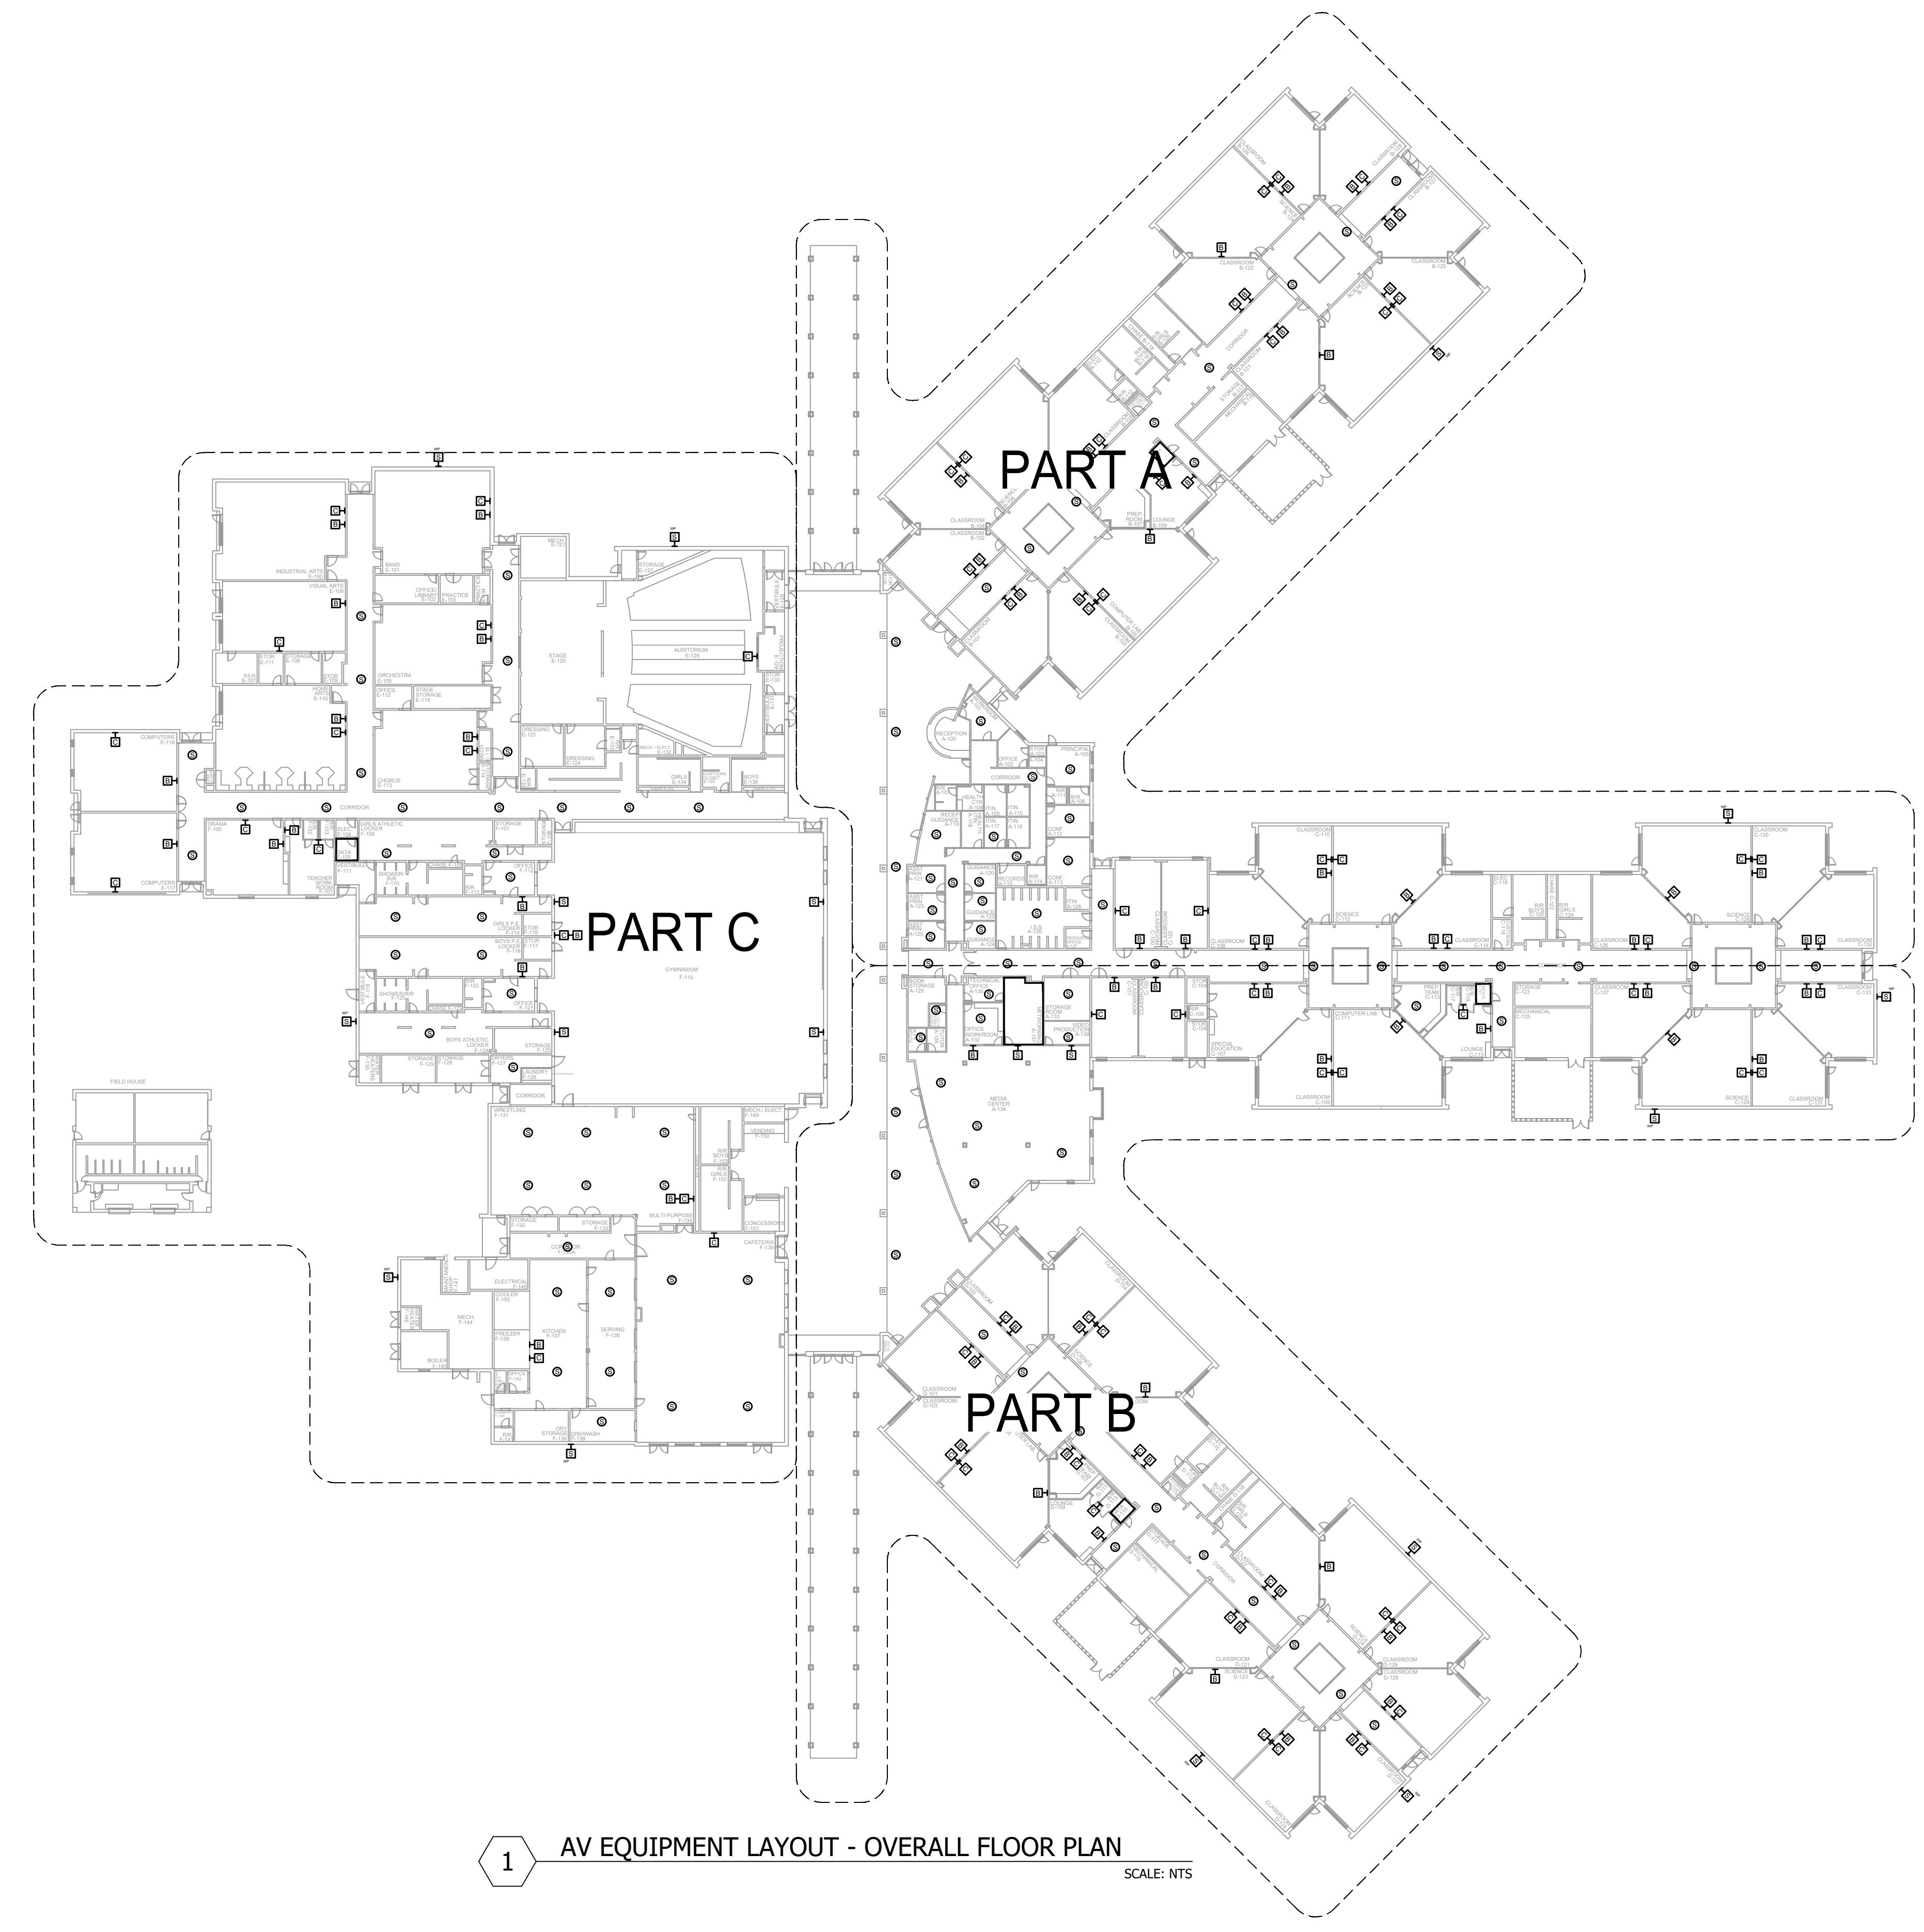

NOTES:

1. SEE DRAWING T-0-001 FOR SYMBOL LEGEND AND GENERAL NOTES.

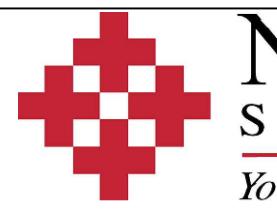

NetPlanner SYSTEMS, INC.[®]

Atlanta, GA 770-662-5482 Augusta, GA 706-364-4190
Raleigh, NC 919-290-8010 Columbus, GA 706-571-9090
Toll Free 800-795-1975 Savannah, GA 912-748-8960
www.netplanner.com

CLIENT LOGO

PROJECT INFO


ROCK HILL SCHOOLS ROCK HILL, SC

SHEET INFO

ENG
APP

**INEER
ROVAL**

ING NAME
A-1-10-100N
CT NUMBER
20245
VED DRAWING DATE
23-2021

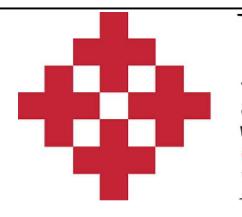

NetPlanner SYSTEMS, INC.[®]

Your Pathway to Connectivity

Atlanta, GA	770-662-5482	Augusta, GA	706-364-4191
Raleigh, NC	919-290-8010	Columbus, GA	706-571-9091
Toll Free	800-795-1975	Savannah, GA	912-748-8961

www.netplanner.com

CLIENT LOGO

CLIENT LOC

PROJECT INFO

ROCK HILL SCHOOLS ROCK HILL, SC

SHEET INFO
INTERCOM & NOTIFICATIONS
DUTCHMAN CREEK MS - PART A
NEW DEVICES

REVISIONS			ENGINEER APPROVAL	ENGINEER	DRAWING NAME
REV.	DESCRIPTION	DATE		WM	TA-1-10-101N
				CAD	PROJECT NUMBER
				AK	AR20245
			PROJECT MANAGER	APPROVED DRAWING DATE	
				SD	07-23-2021
					RELEASE NUMBER
					1




1 AV EQUIPMENT LAYOUT - PART B

SCALE: NTS

REVISIONS		
REV.	DESCRIPTION	DATE

ENGINEER APPROVAL	ENGINEER	DRAWING NAME
	WM	TA-1-10-102N
CAD	AK	PROJECT NUMBER
PROJECT MANAGER	SD	AR20245
		APPROVED DRAWING DATE
		07-23-2021
		RELEASE NUMBER
		1

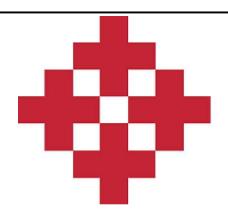

NetPlanner SYSTEMS, INC.[®]

Your Pathway to Connectivity

Atlanta, GA	770-662-5482	Augusta, GA	706-364-4190
Raleigh, NC	919-290-8010	Columbus, GA	706-571-9090
Toll Free	800-795-1975	Savannah, GA	912-748-8960

www.netplanner.com

CLIENT LOGO

PROJECT INFO

ROCK HILL SCHOOL

ROCK HILL, SC

SHEET INFO


INTERCOM & NOTIFICATIONS

DUTCHMAN CREEK MS - PART C - NEW DEVICES

REVISIONS			ENGINEER APPROVAL	ENGINEER	DRAWING NAME
REV.	DESCRIPTION	DATE		WM	TA-1-10-103N
			CAD AK	CAD	PROJECT NUMBER
				AK	AR20245
			PROJECT MANAGER	APPROVED DRAWING DATE	
			SD	07-23-2021	RELEASE NUMBER 1

A B C D E F G H J K

NOTES:
1. SEE DRAWING T-0-001 FOR SYMBOL LEGEND
AND GENERAL NOTES.

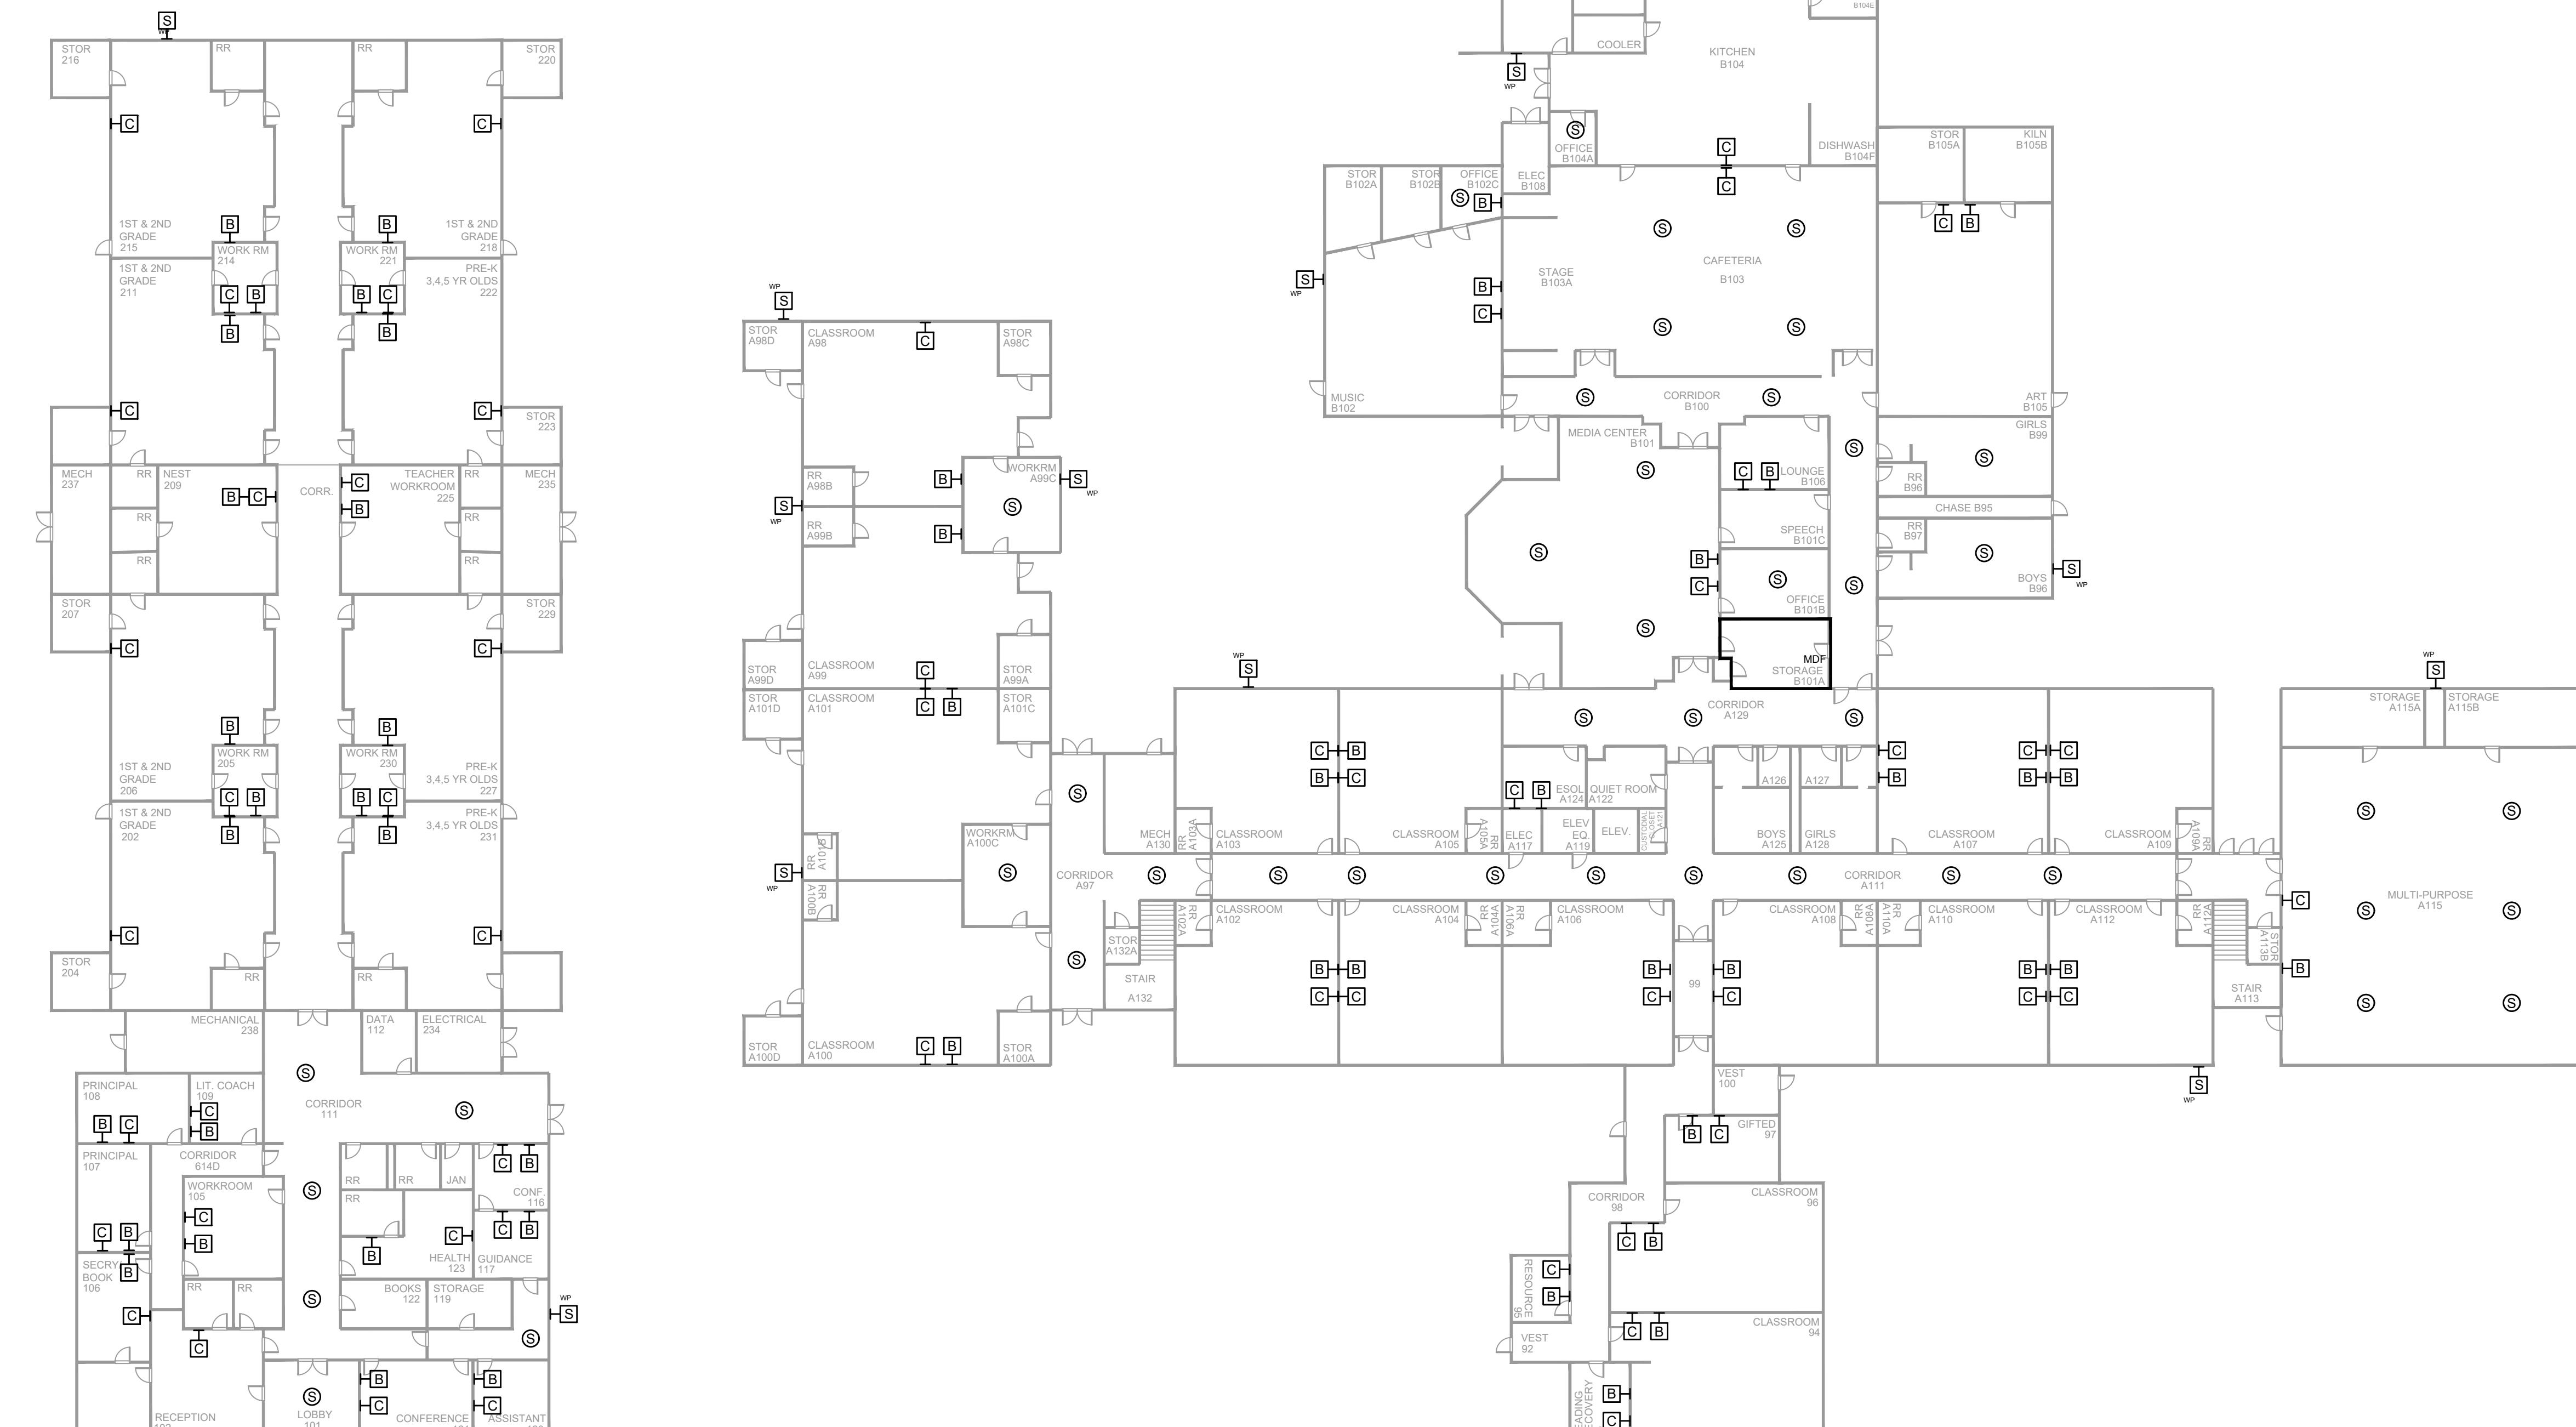

AV EQUIPMENT LAYOUT

SCALE: NTS


REVISIONS			ENGINEER APPROVAL	ENGINEER WM	DRAWING NAME TA-1-11-101N
REV.	DESCRIPTION	DATE			
				CAD AK	PROJECT NUMBER AR20245
				PROJECT MANAGER SD	APPROVED DRAWING DATE 07-23-2021
					RELEASE NUMBER 1

A B C D E F G H J K

A | B | C | D | E | F | G | H | J | K

NOTES:

1. SEE DRAWING T-0-001 FOR SYMBOL LEGEND AND GENERAL NOTES.

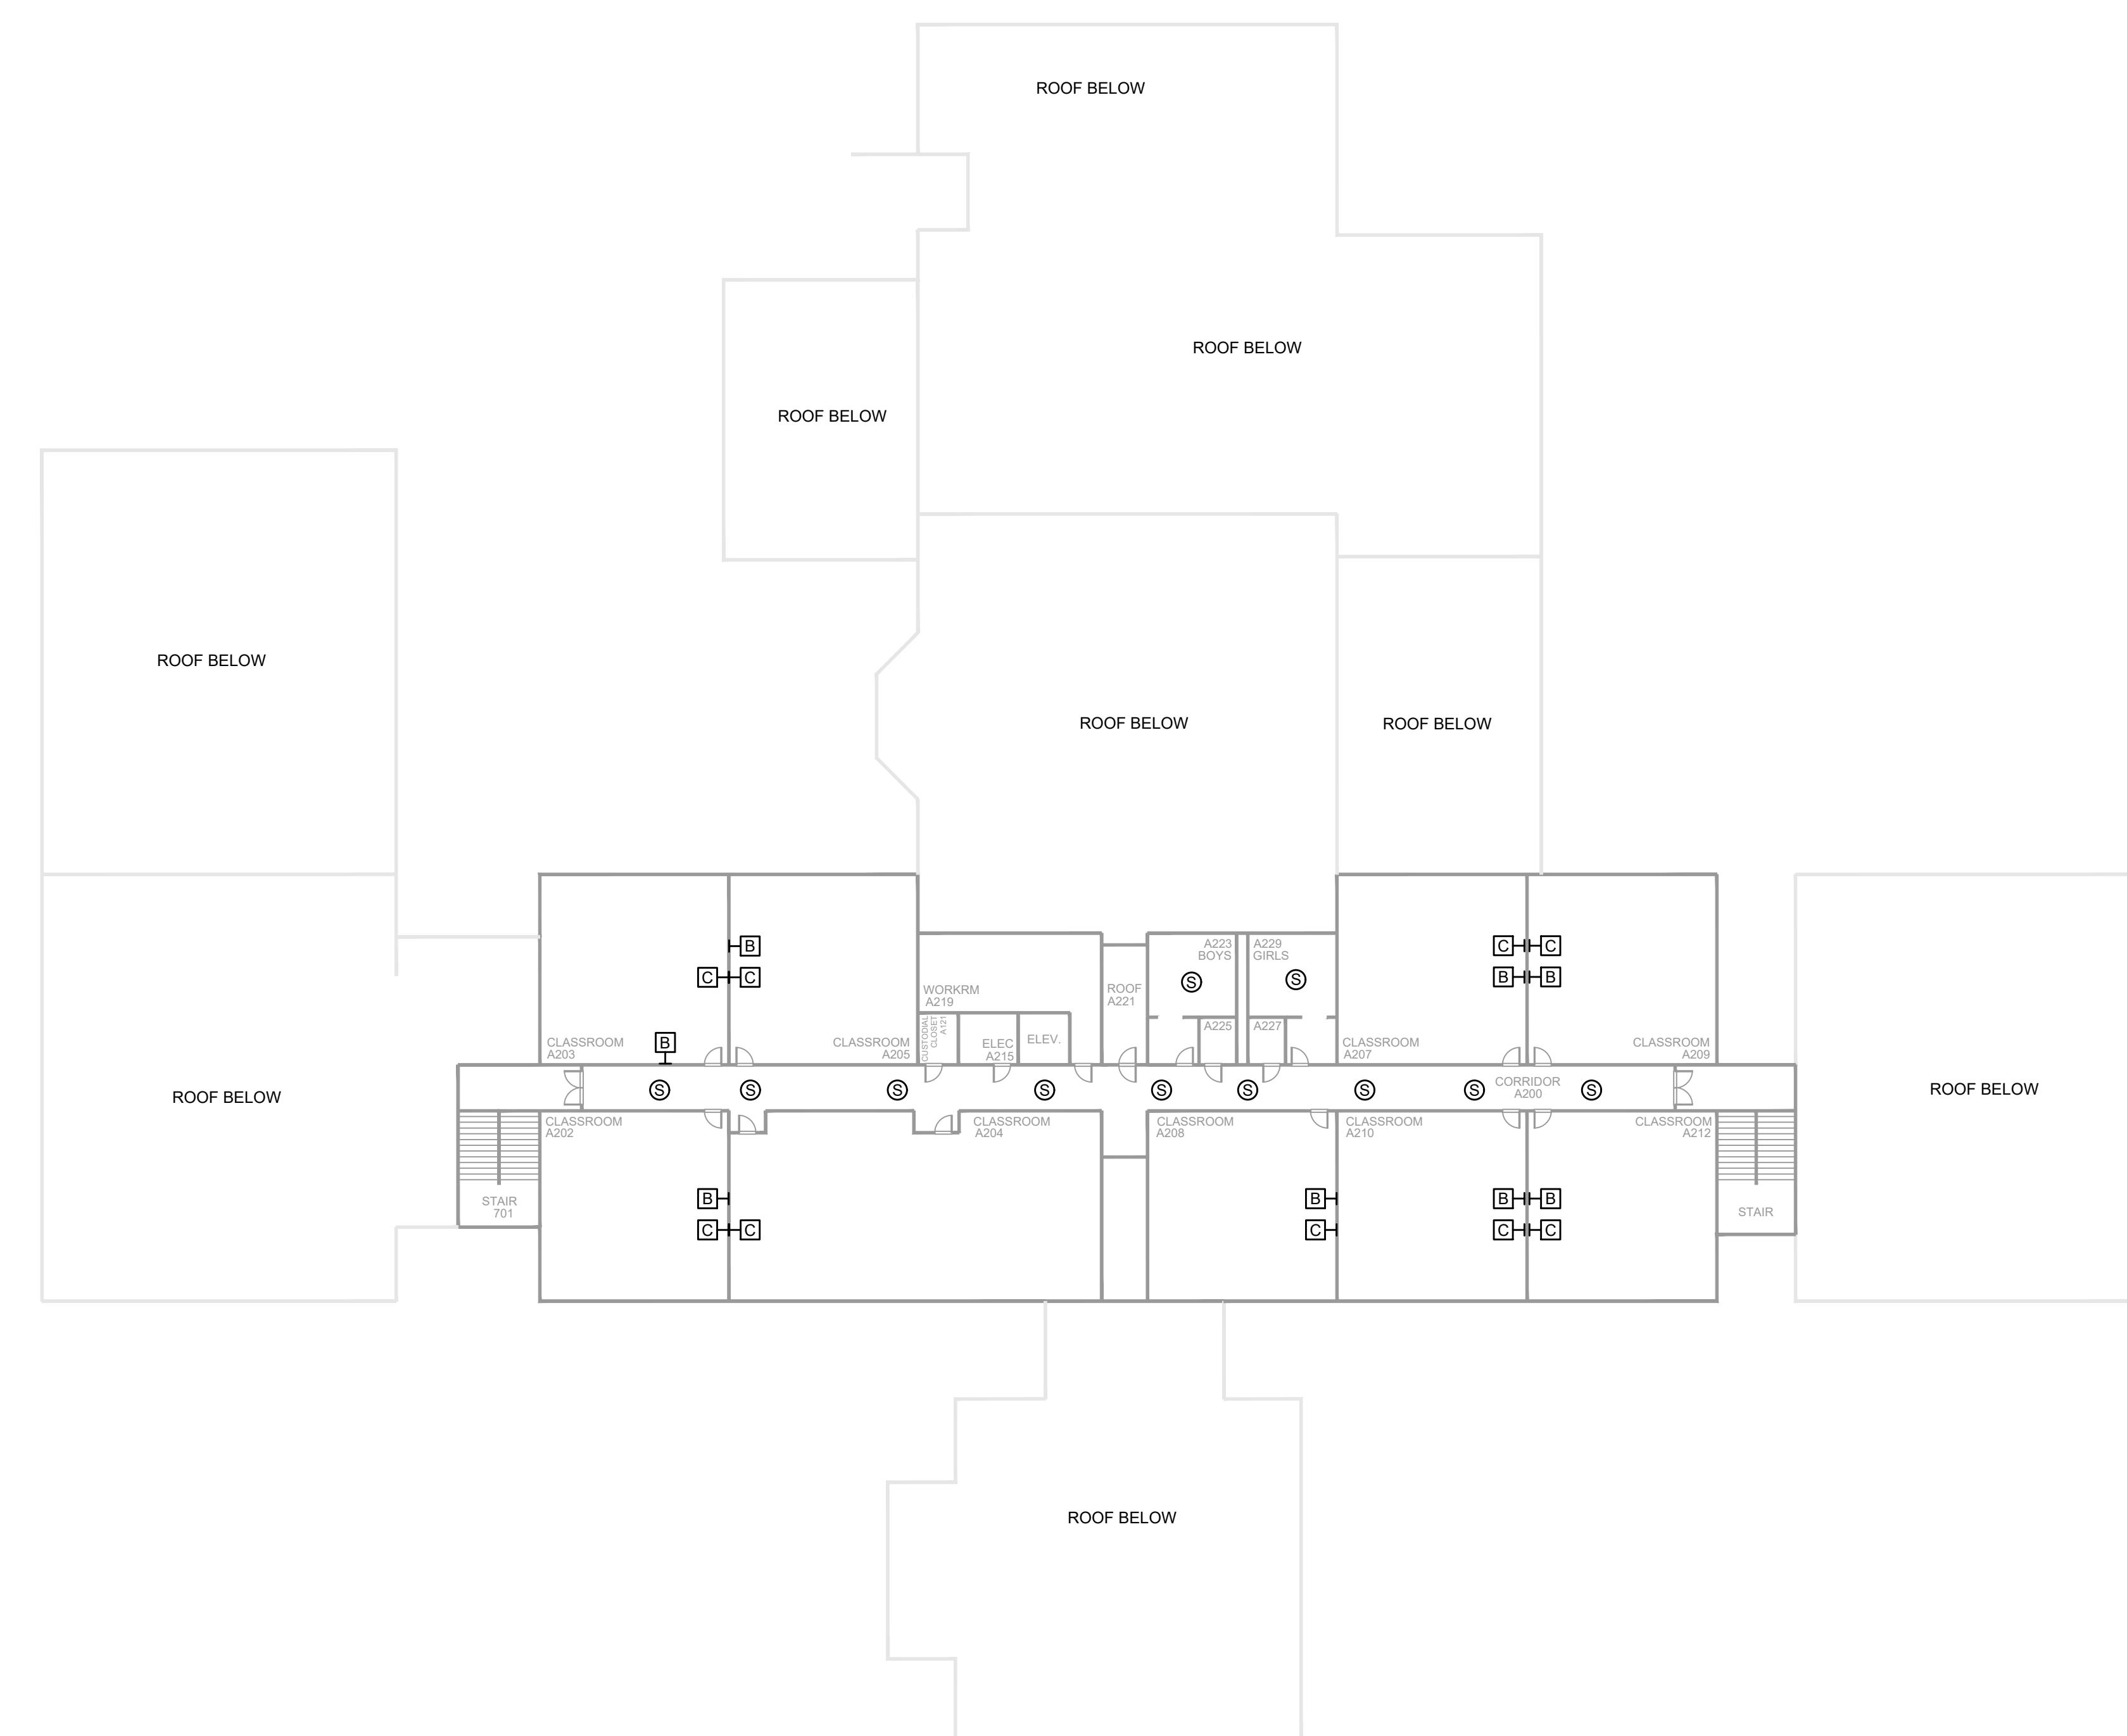

AV EQUIPMENT LAYOUT

SCALE: NTS



T *Your Pathway to Connectivity*

Atlanta, GA	770-662-5482	Augusta, GA	706-364-4199
Raleigh, NC	919-290-8010	Columbus, GA	706-571-9099
Toll Free	800-795-1975	Savannah, GA	912-748-8966

www.netplanner.com

CLIENT LOGO

PROJECT INFO

ROCK HILL SCHOOLS


ROCK HILL, SC

SHEET INFO

INTERCOM & NOTIFICATIONS

EBENEZER ELEMENTARY - 2ND FLOOR - NEW DEVICES

REVISIONS			ENGINEER APPROVAL	ENGINEER WM	DRAWING NAME
REV.	DESCRIPTION	DATE			TA-1-11-201N
				CAD AK	PROJECT NUMBER AR20245
				PROJECT MANAGER SD	APPROVED DRAWING DATE 07-23-2021
					RELEASE NUMBER 1

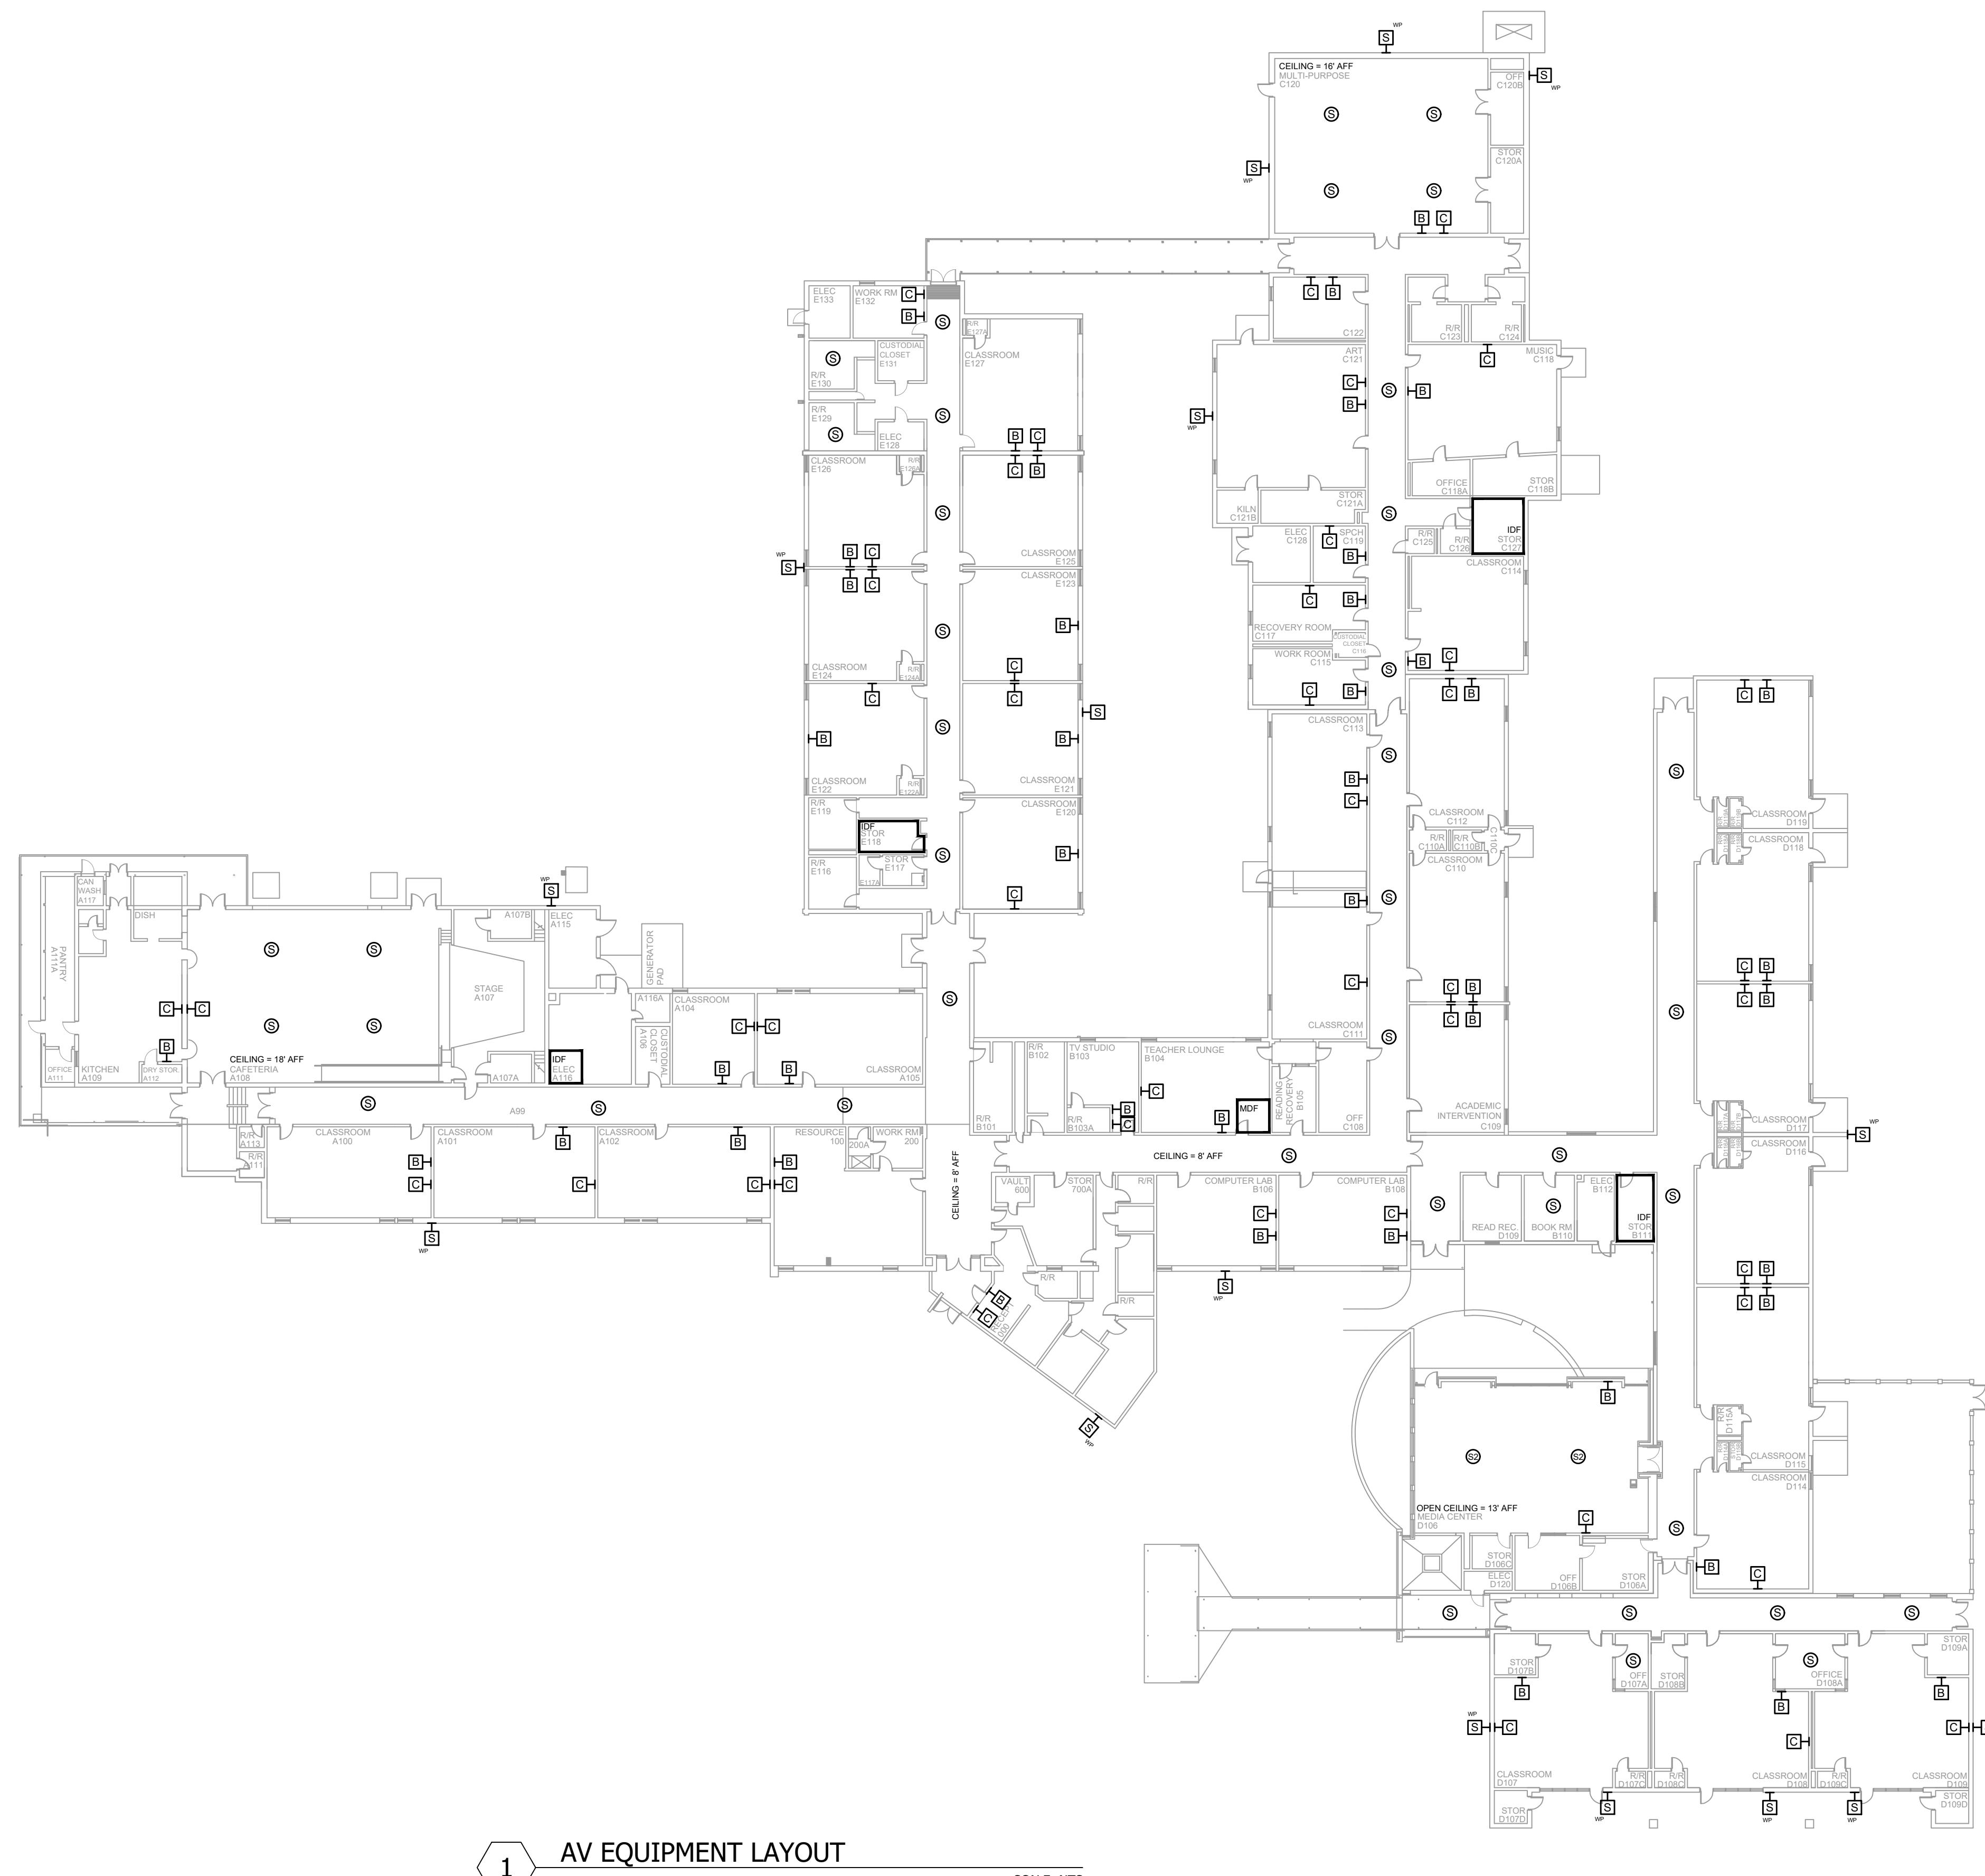

NOTES:

1. SEE DRAWING T-0-001 FOR SYMBOL LEGEND AND GENERAL NOTES.



NetPlanner SYSTEMS, INC.[®]

Your Pathway to Connectivity

Atlanta, GA	770-662-5482	Augusta, GA	706-364-4190
Raleigh, NC	919-290-8010	Columbus, GA	706-571-9090
Toll Free	800-795-1975	Savannah, GA	912-748-8960

www.netplanner.com

CLIENT LOGO

PROJECT INFO

ROCK HILL SCHOOLS ROCK HILL, SC

SHEET INFO


INTERCOM & NOTIFICATIONS

EBIMPORT ELEMENTARY - NEW DEVICES

REVISIONS			ENGINEER APPROVAL	ENGINEER WM	DRAWING NAME
REV.	DESCRIPTION	DATE			TA-1-12-101N
				CAD AK	PROJECT NUMBER AR20245
				PROJECT MANAGER SD	APPROVED DRAWING DATE 07-23-2021
					RELEASE NUMBER 1

A B C D E F G H J K



- NOTES:
- SEE DRAWING T-0-001 FOR SYMBOL LEGEND AND GENERAL NOTES.
 - HALLWAY CEILINGS ARE 8' - 10' AFF.

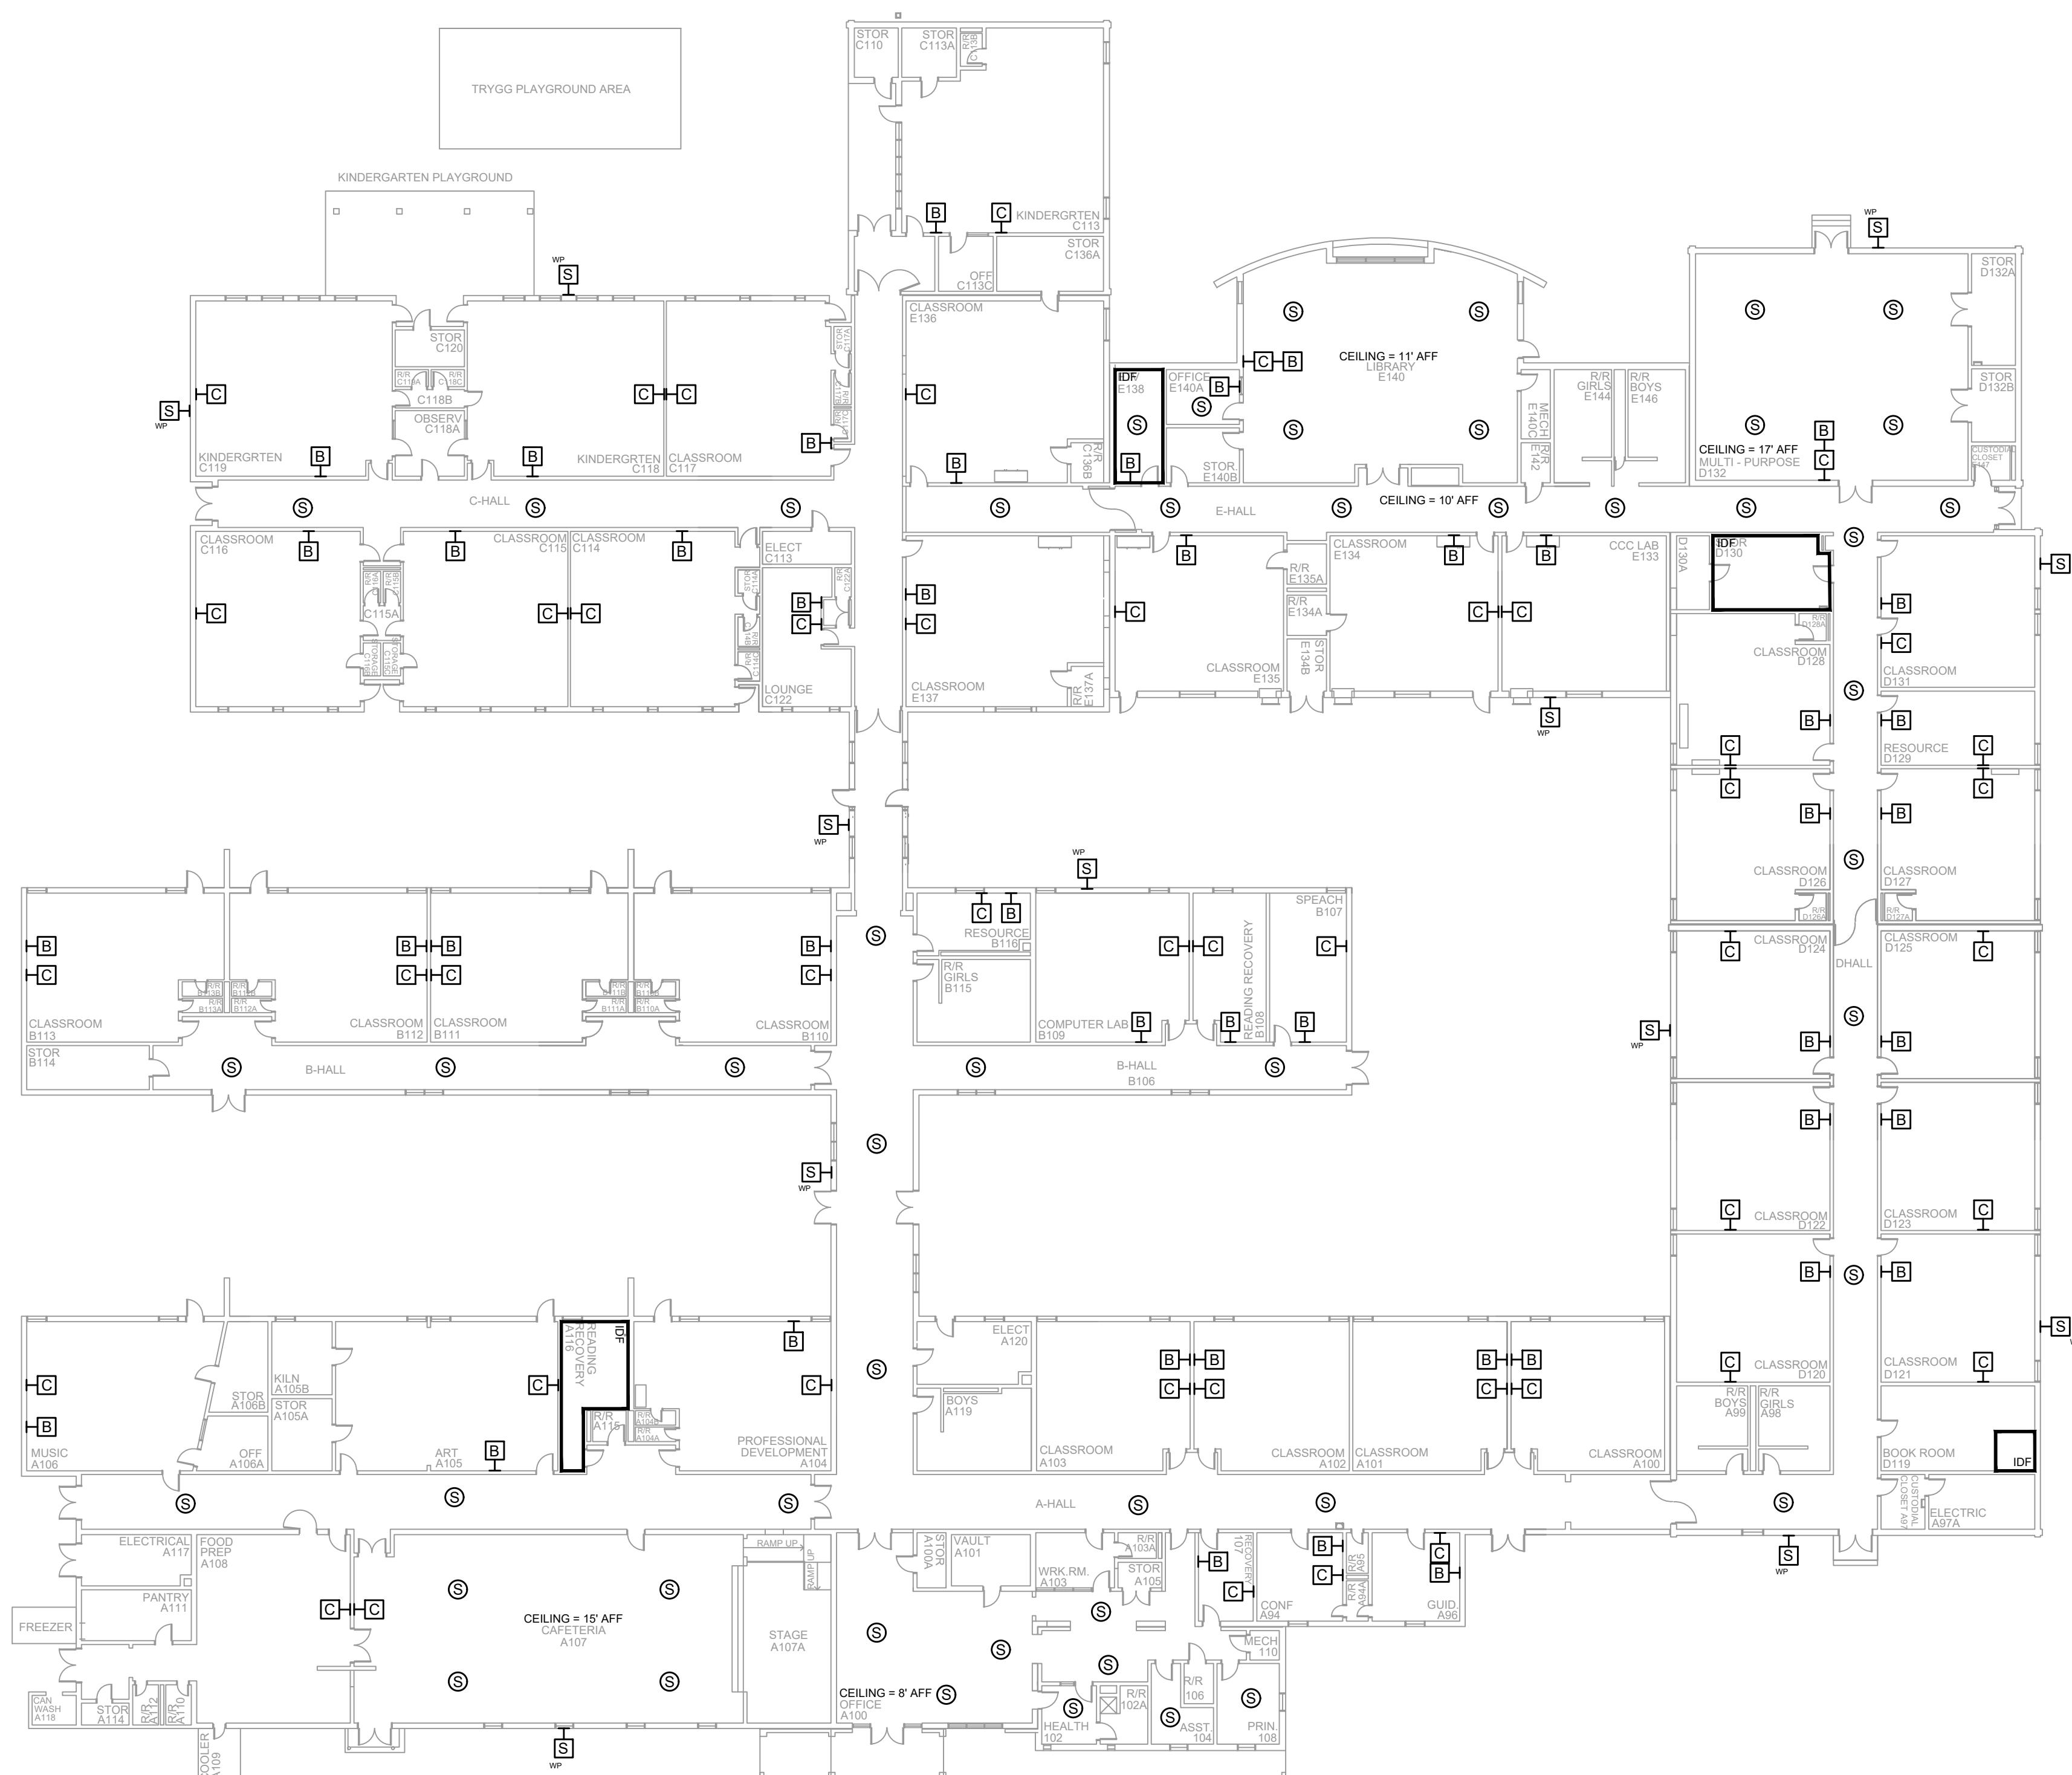

1 AV EQUIPMENT LAYOUT

SCALE: NTS

REV.	DESCRIPTION	DATE	REVISIONS	
			ENGINEER APPROVAL	ENGINEER DRAWING NAME
			WM	TA-1-13-101N
			CAD AK	PROJECT NUMBER AR20245
			SD	PROJECT MANAGER APPROVED DRAWING DATE 07-23-2021 RELEASE NUMBER 1

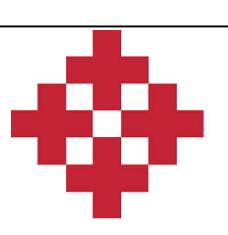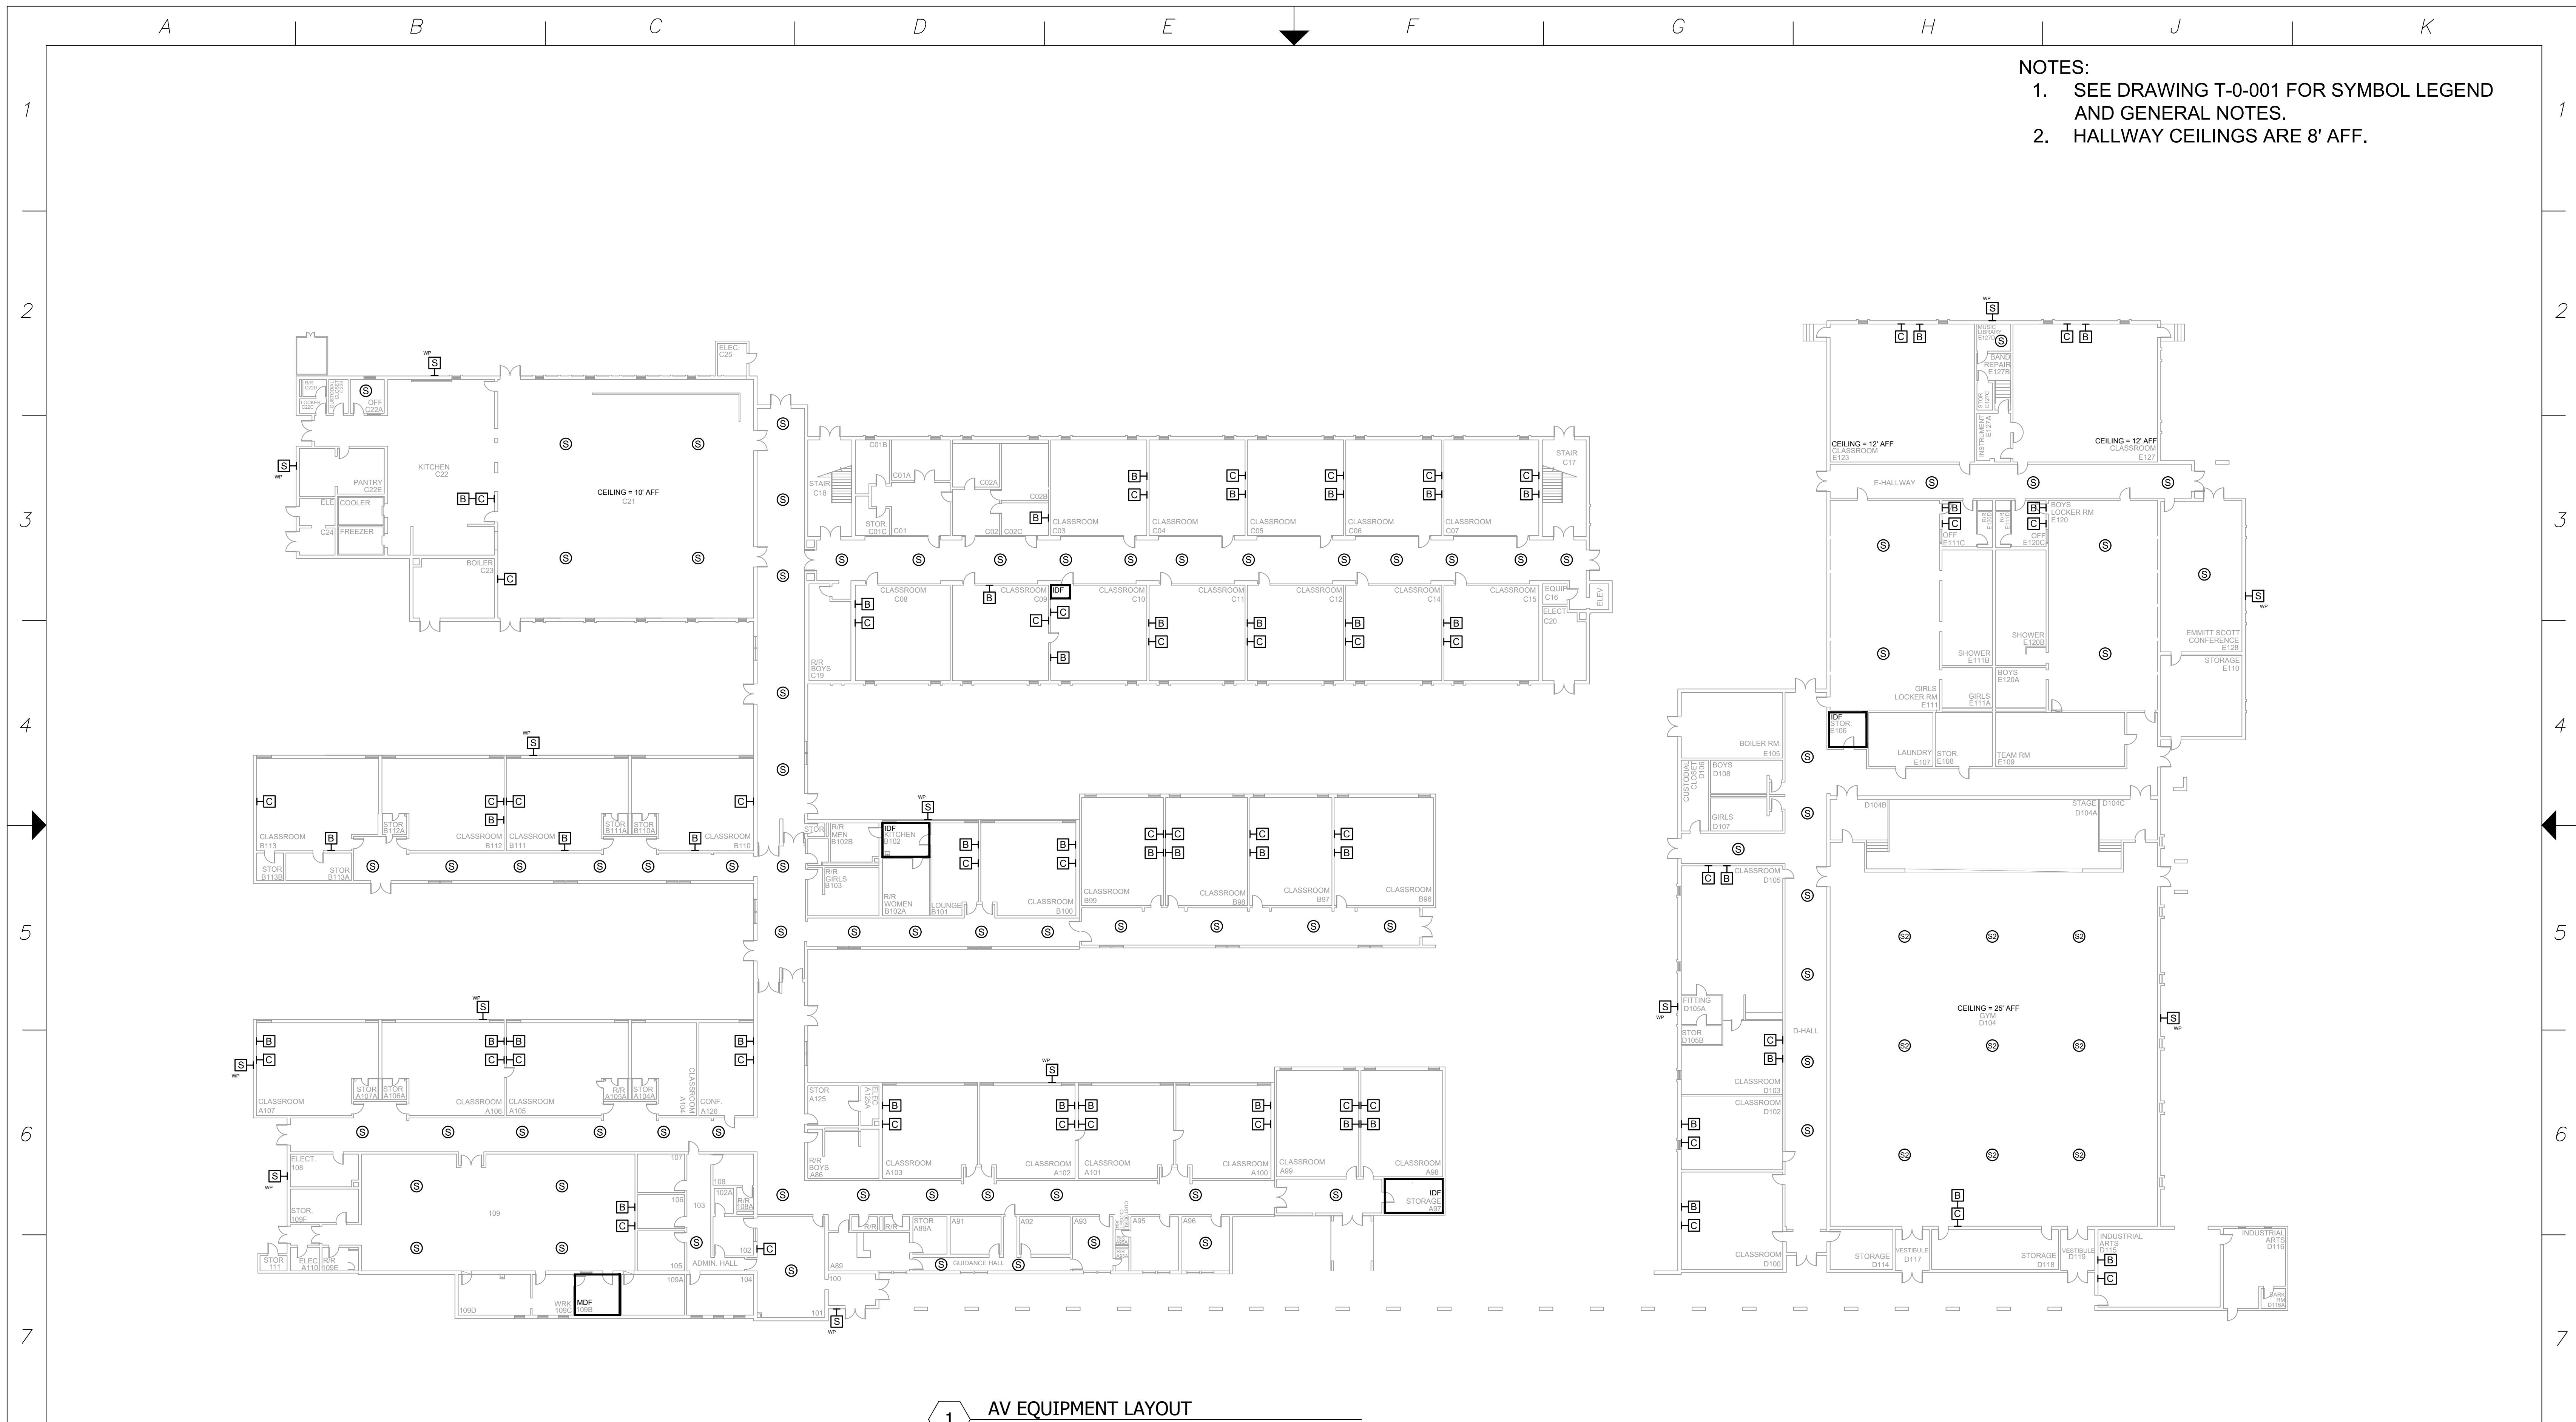

NetPlanner SYSTEMS, INC.[®]

Your Pathway to Connectivity

Atlanta, GA	770-662-5482	Augusta, GA	706-364-4191
Raleigh, NC	919-290-8010	Columbus, GA	706-571-9091
Toll Free	800-795-1975	Savannah, GA	912-748-8961

www.netplanner.com

CLIENT LOGO

PROJECT INFO

ROCK HILL SCHOOLS ROCK HILL, SC

SHEET INFO

INTERCOM & NOTIFICATIONS


FLEXIBLE LEARNING CENTER - 1ST FLOOR -

NEW DEVICES

REVISIONS			ENGINEER APPROVAL	ENGINEER WM	DRAWING NAME
REV.	DESCRIPTION	DATE			TA-1-14-101N
				CAD AK	PROJECT NUMBER AR20245
				PROJECT MANAGER SD	APPROVED DRAWING DATE 07-23-2021
					RELEASE NUMBER 1

A B C D E F G H J K

 - NOTES:
- SEE DRAWING T-0-001 FOR SYMBOL LEGEND AND GENERAL NOTES.
 - HALLWAY CEILINGS ARE 8' AFF.



CLIENT LOGO


PROJECT INFO
ROCK HILL SCHOOLS
ROCK HILL, SC

SHEET INFO
INTERCOM & NOTIFICATIONS
FLEXIBLE LEARNING CENTER - 2ND FLOOR -
NEW DEVICES

REV.	DESCRIPTION	DATE	REVISIONS	
			ENGINEER APPROVAL	DRAWING NAME
			WM	TA-1-14-201N
			CAD	PROJECT NUMBER
			AK	AR20245
			PROJECT MANAGER	APPROVED DRAWING DATE
			SD	RELEASE NUMBER


ENGINEER APPROVAL	DRAWING NAME
WM	TA-1-14-201N

A B C D E F G H J K

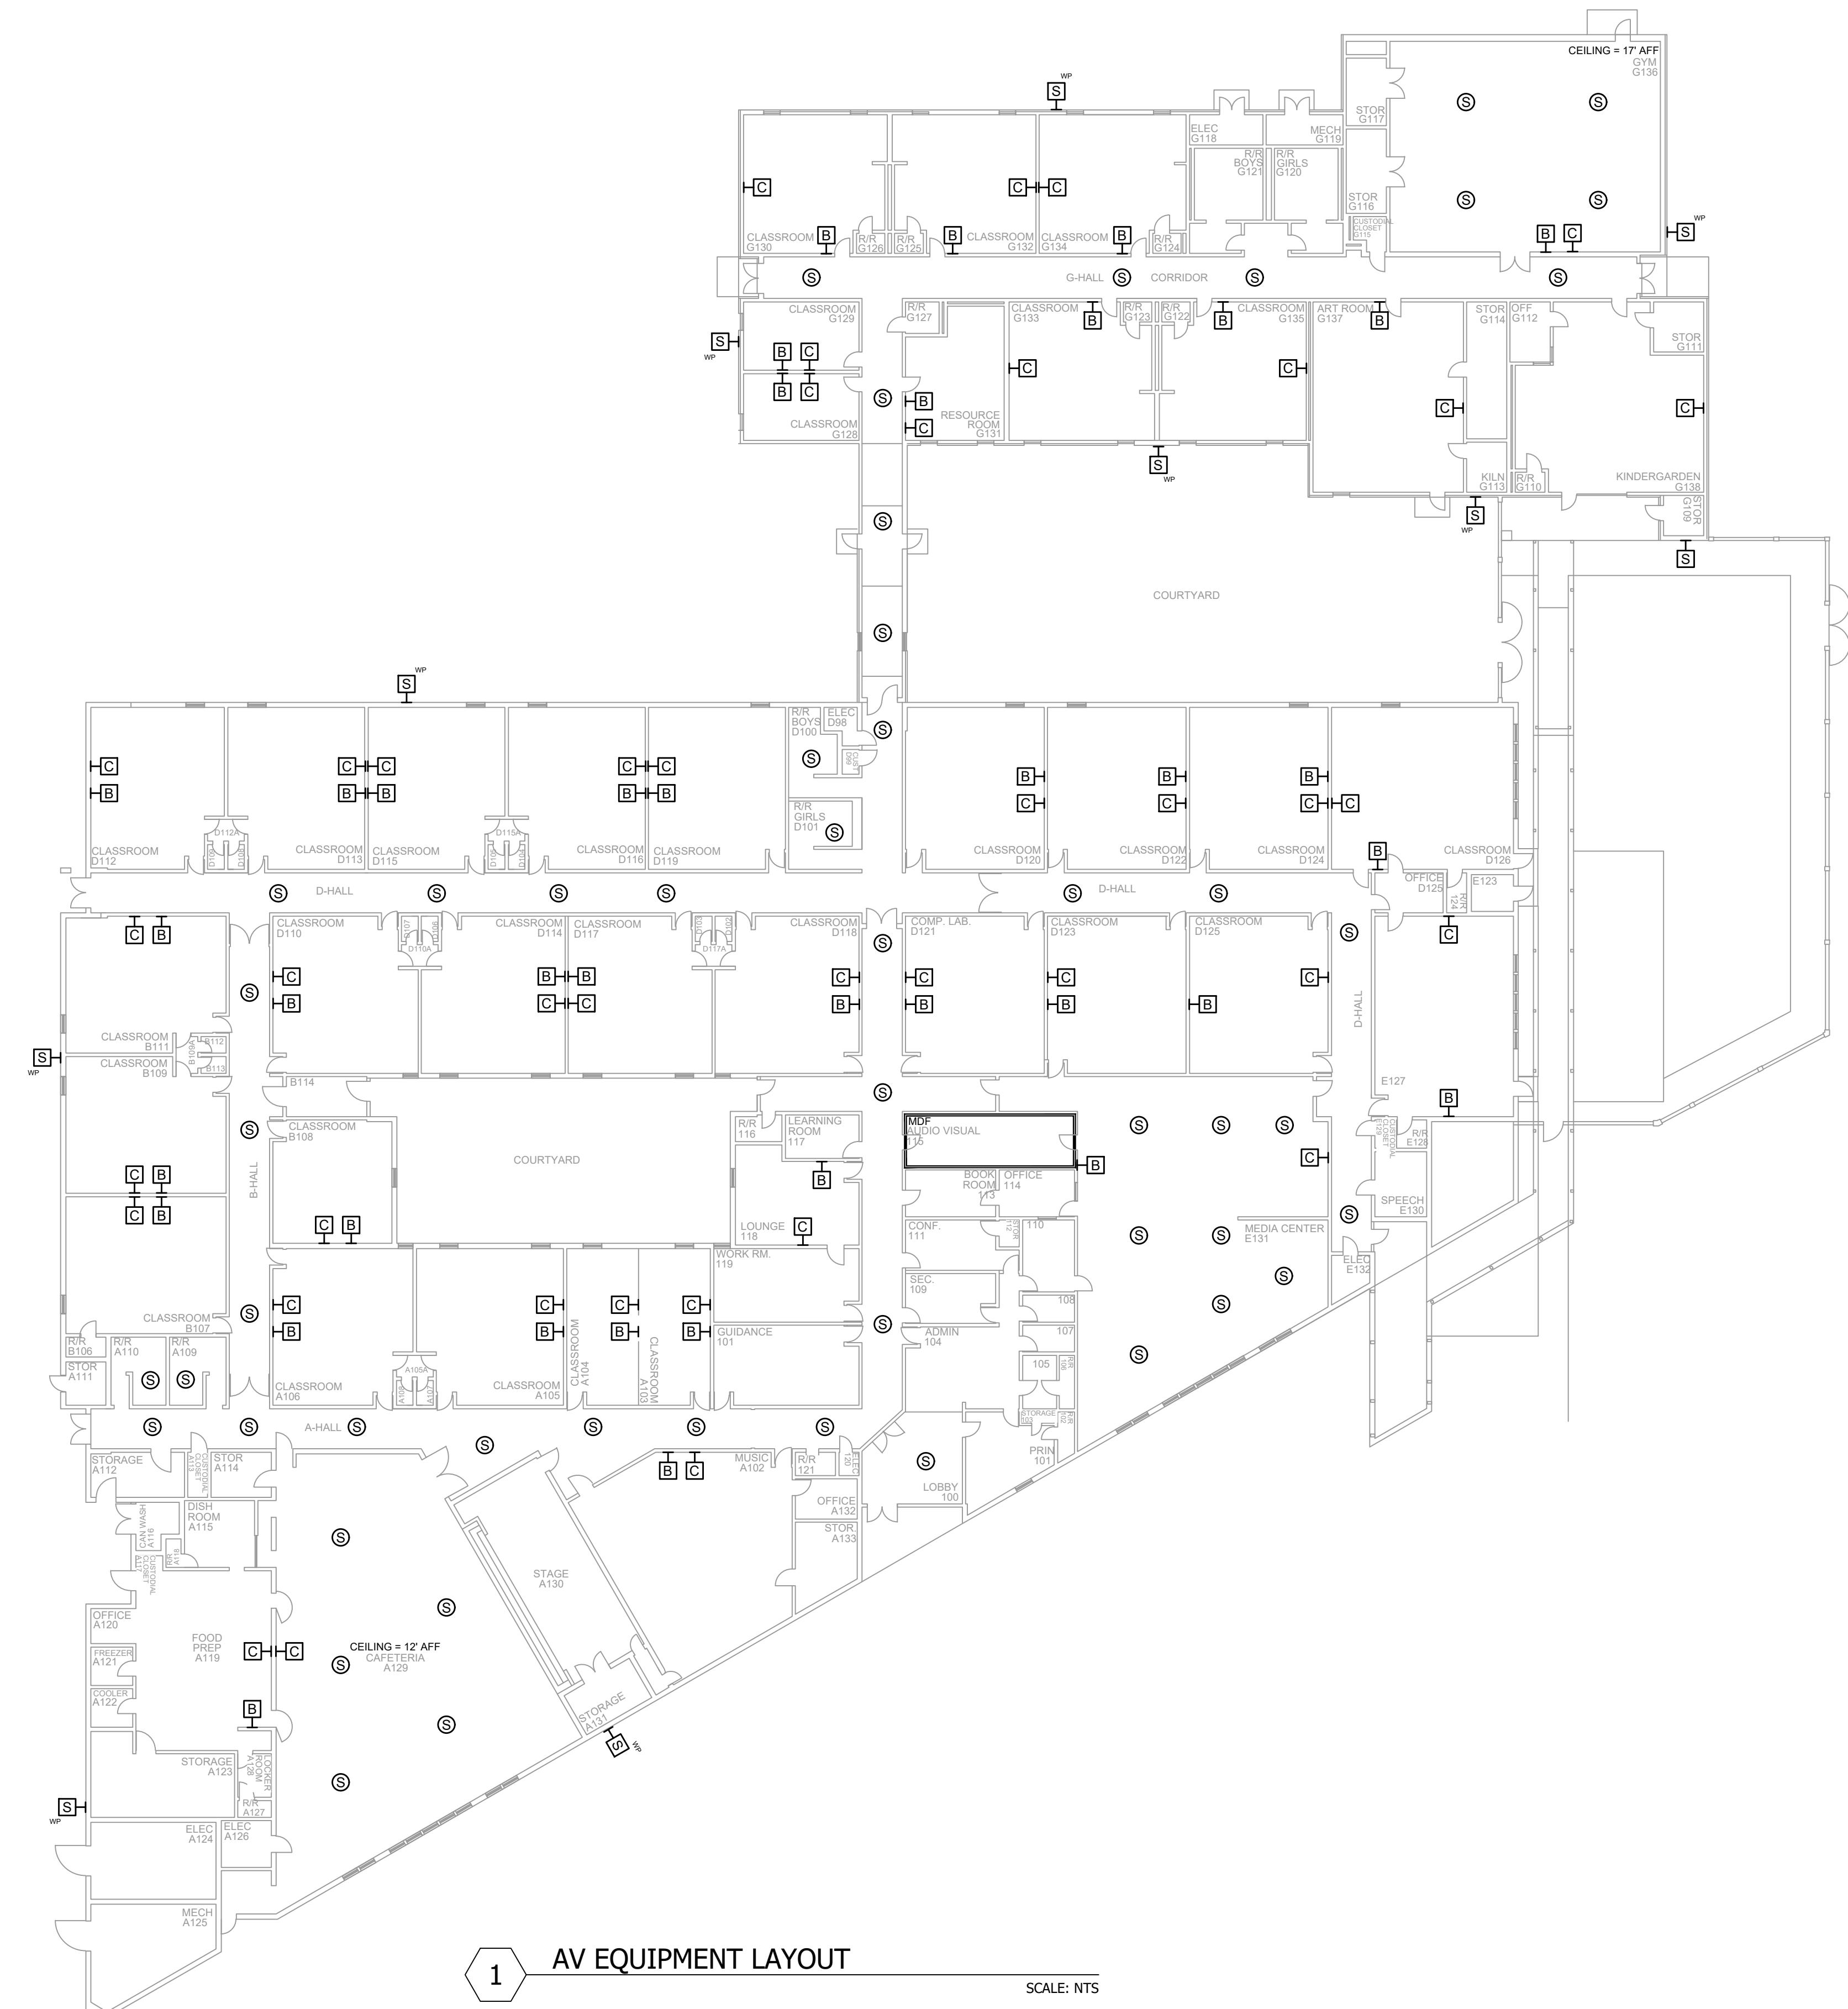

NOTES:

1. SEE DRAWING T-0-001 FOR SYMBOL LEGEND AND GENERAL NOTES.
2. CLASSROOMS & HALLWAY CEILINGS ARE 9' AFF.

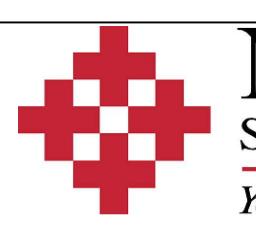

NetPlanner SYSTEMS, INC.[®]

Your Pathway to Connectivity

Atlanta, GA	770-662-5482	Augusta, GA	706-364-4190
Raleigh, NC	919-290-8010	Columbus, GA	706-571-9090
Toll Free	800-795-1975	Savannah, GA	912-748-8960

www.netplanner.com



CLIENT LOGO

PROJECT INFO

ROCK HILL SCHOOLS ROCK HILL, SC


SHEET INFO

INTERCOM & NOTIFICATIONS

INDEPENDENCE ELEMENTARY - NEW DEVICES

REVISIONS			ENGINEER APPROVAL	ENGINEER WM	DRAWING NAME
REV.	DESCRIPTION	DATE			TA-1-15-101N
			CAD AK	PROJECT NUMBER AR20245	PROJECT NUMBER AR20245
					AR20245
			PROJECT MANAGER SD	APPROVED DRAWING DATE 07-23-2021	RELEASE NUMBER 1
				07-23-2021	1

A B C D E F G H J K

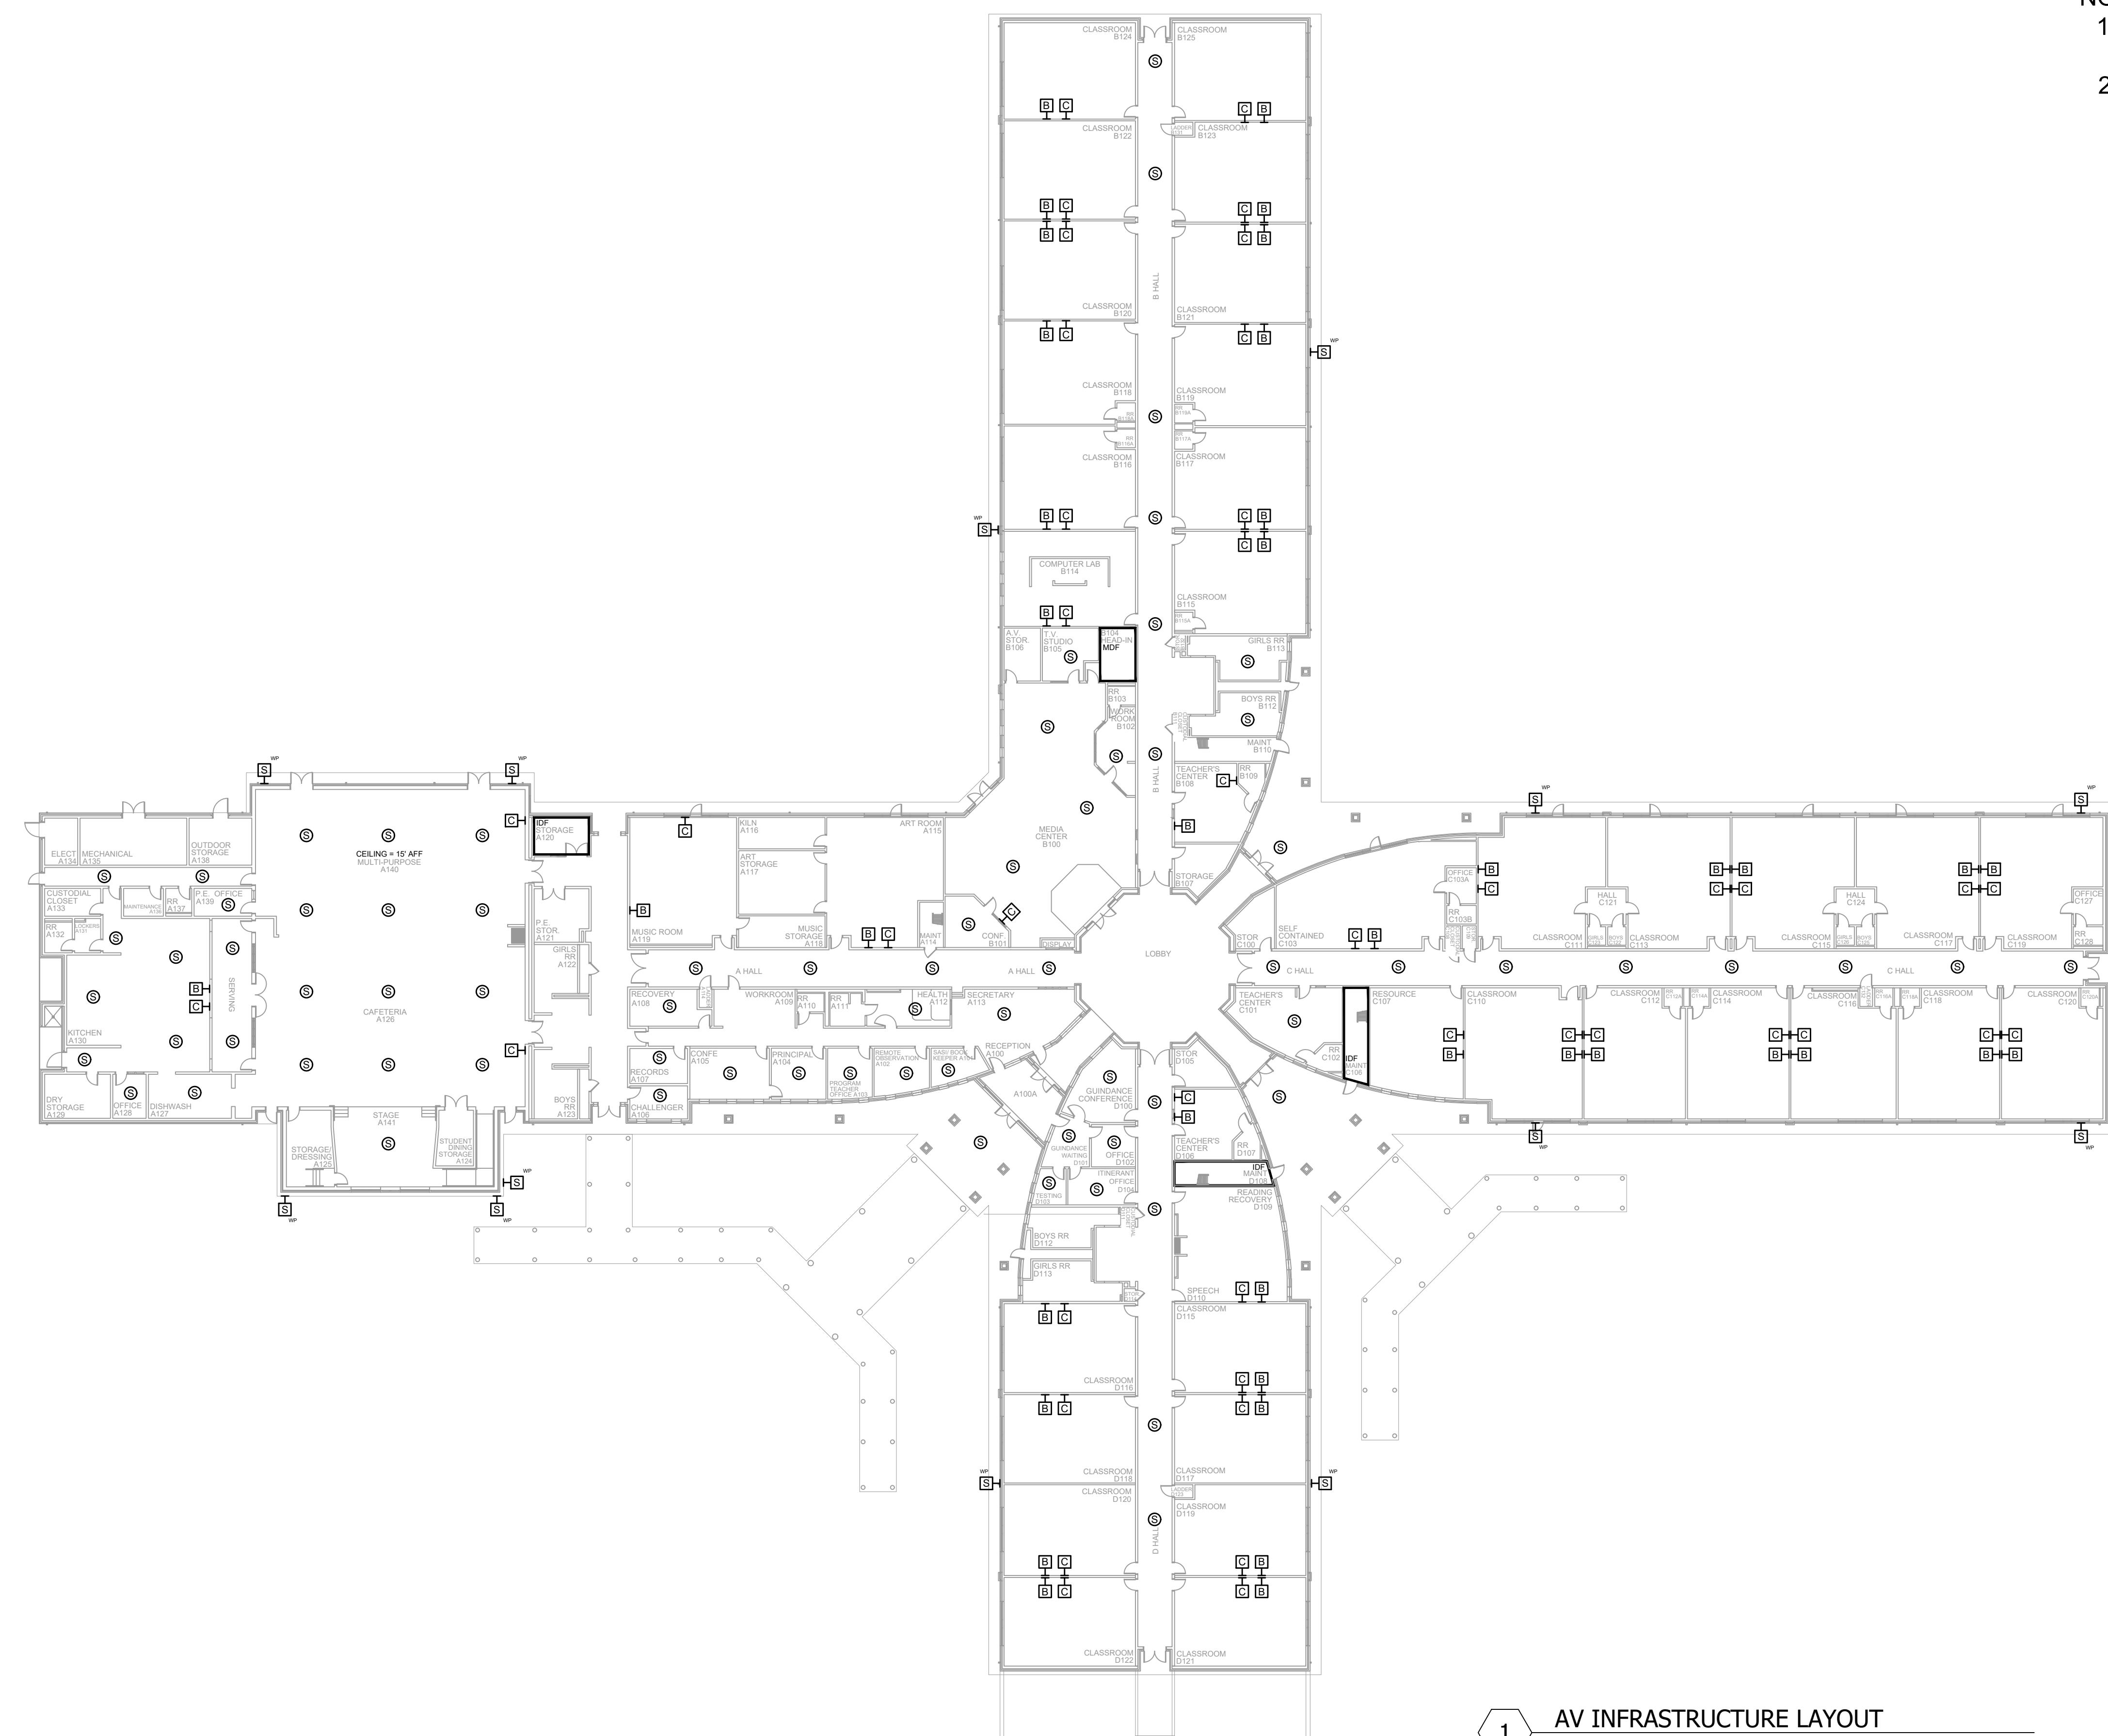

- NOTES:
- SEE DRAWING T-0-001 FOR SYMBOL LEGEND AND GENERAL NOTES.
 - CLASSROOMS & HALLWAY CEILINGS ARE 9.5' AFF.


1 AV INFRASTRUCTURE LAYOUT

SCALE: NTS

REV.	DESCRIPTION	DATE	REVISIONS	
			ENGINEER APPROVAL	DRAWING NAME
			WM	TA-1-16-101N
			CAD AK	PROJECT NUMBER AR20245
			SD	PROJECT MANAGER APPROVED DRAWING DATE 07-23-2021 RELEASE NUMBER 1

A B C D E F G H J K

- NOTES:
- SEE DRAWING T-0-001 FOR SYMBOL LEGEND AND GENERAL NOTES.
 - HALLWAY CEILINGS ARE 8' AFF.

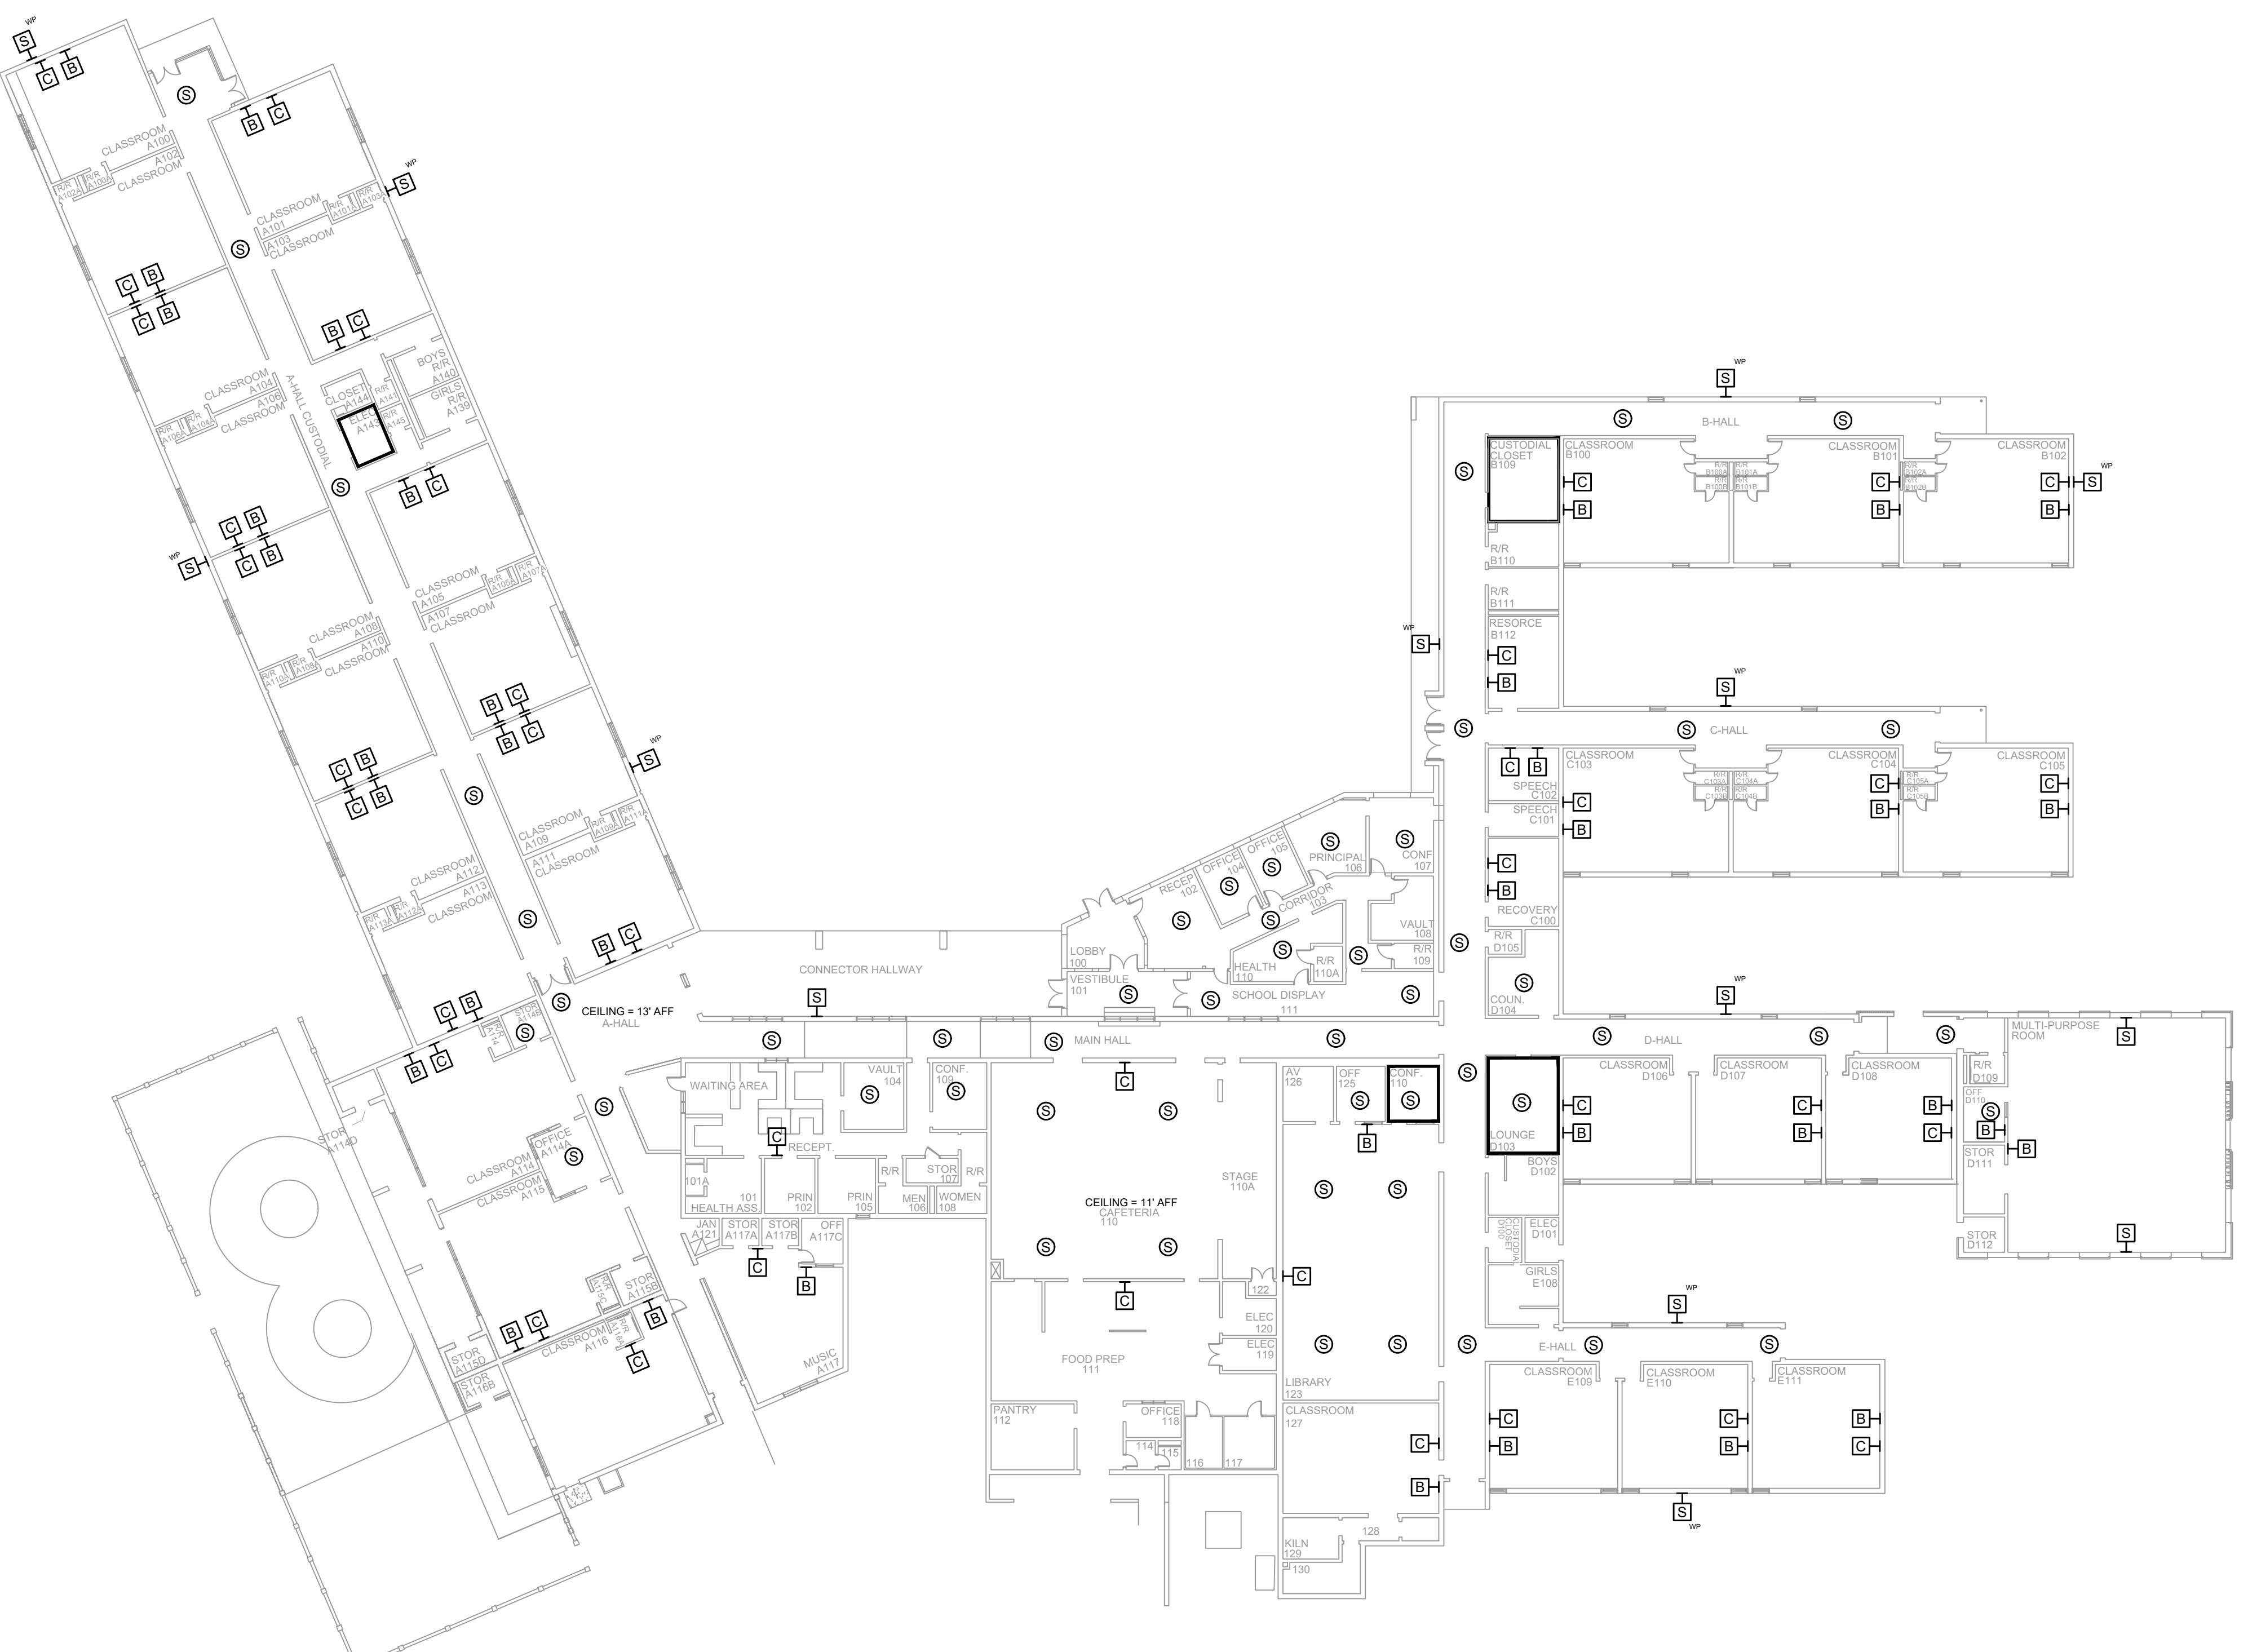

1 AV EQUIPMENT LAYOUT

SCALE: NTS


REV.	DESCRIPTION	DATE	REVISIONS	
			ENGINEER APPROVAL	DRAWING NAME
			WM	TA-1-17-101N
			CAD AK	PROJECT NUMBER AR20245
			SD	PROJECT MANAGER APPROVED DRAWING DATE 07-23-2021 RELEASE NUMBER 1



NOTES:
1. SEE DRAWING T-0-001 FOR SYMBOL LEGEND AND GENERAL NOTES.


REVISIONS		
REV.	DESCRIPTION	DATE

ENGINEER APPROVAL	ENGINEER	DRAWING NAME
	WM	TA-1-18-101N
CAD	AK	PROJECT NUMBER
PROJECT MANAGER	SD	AR20245
		APPROVED DRAWING DATE
		07-23-2021
		RELEASE NUMBER
		1

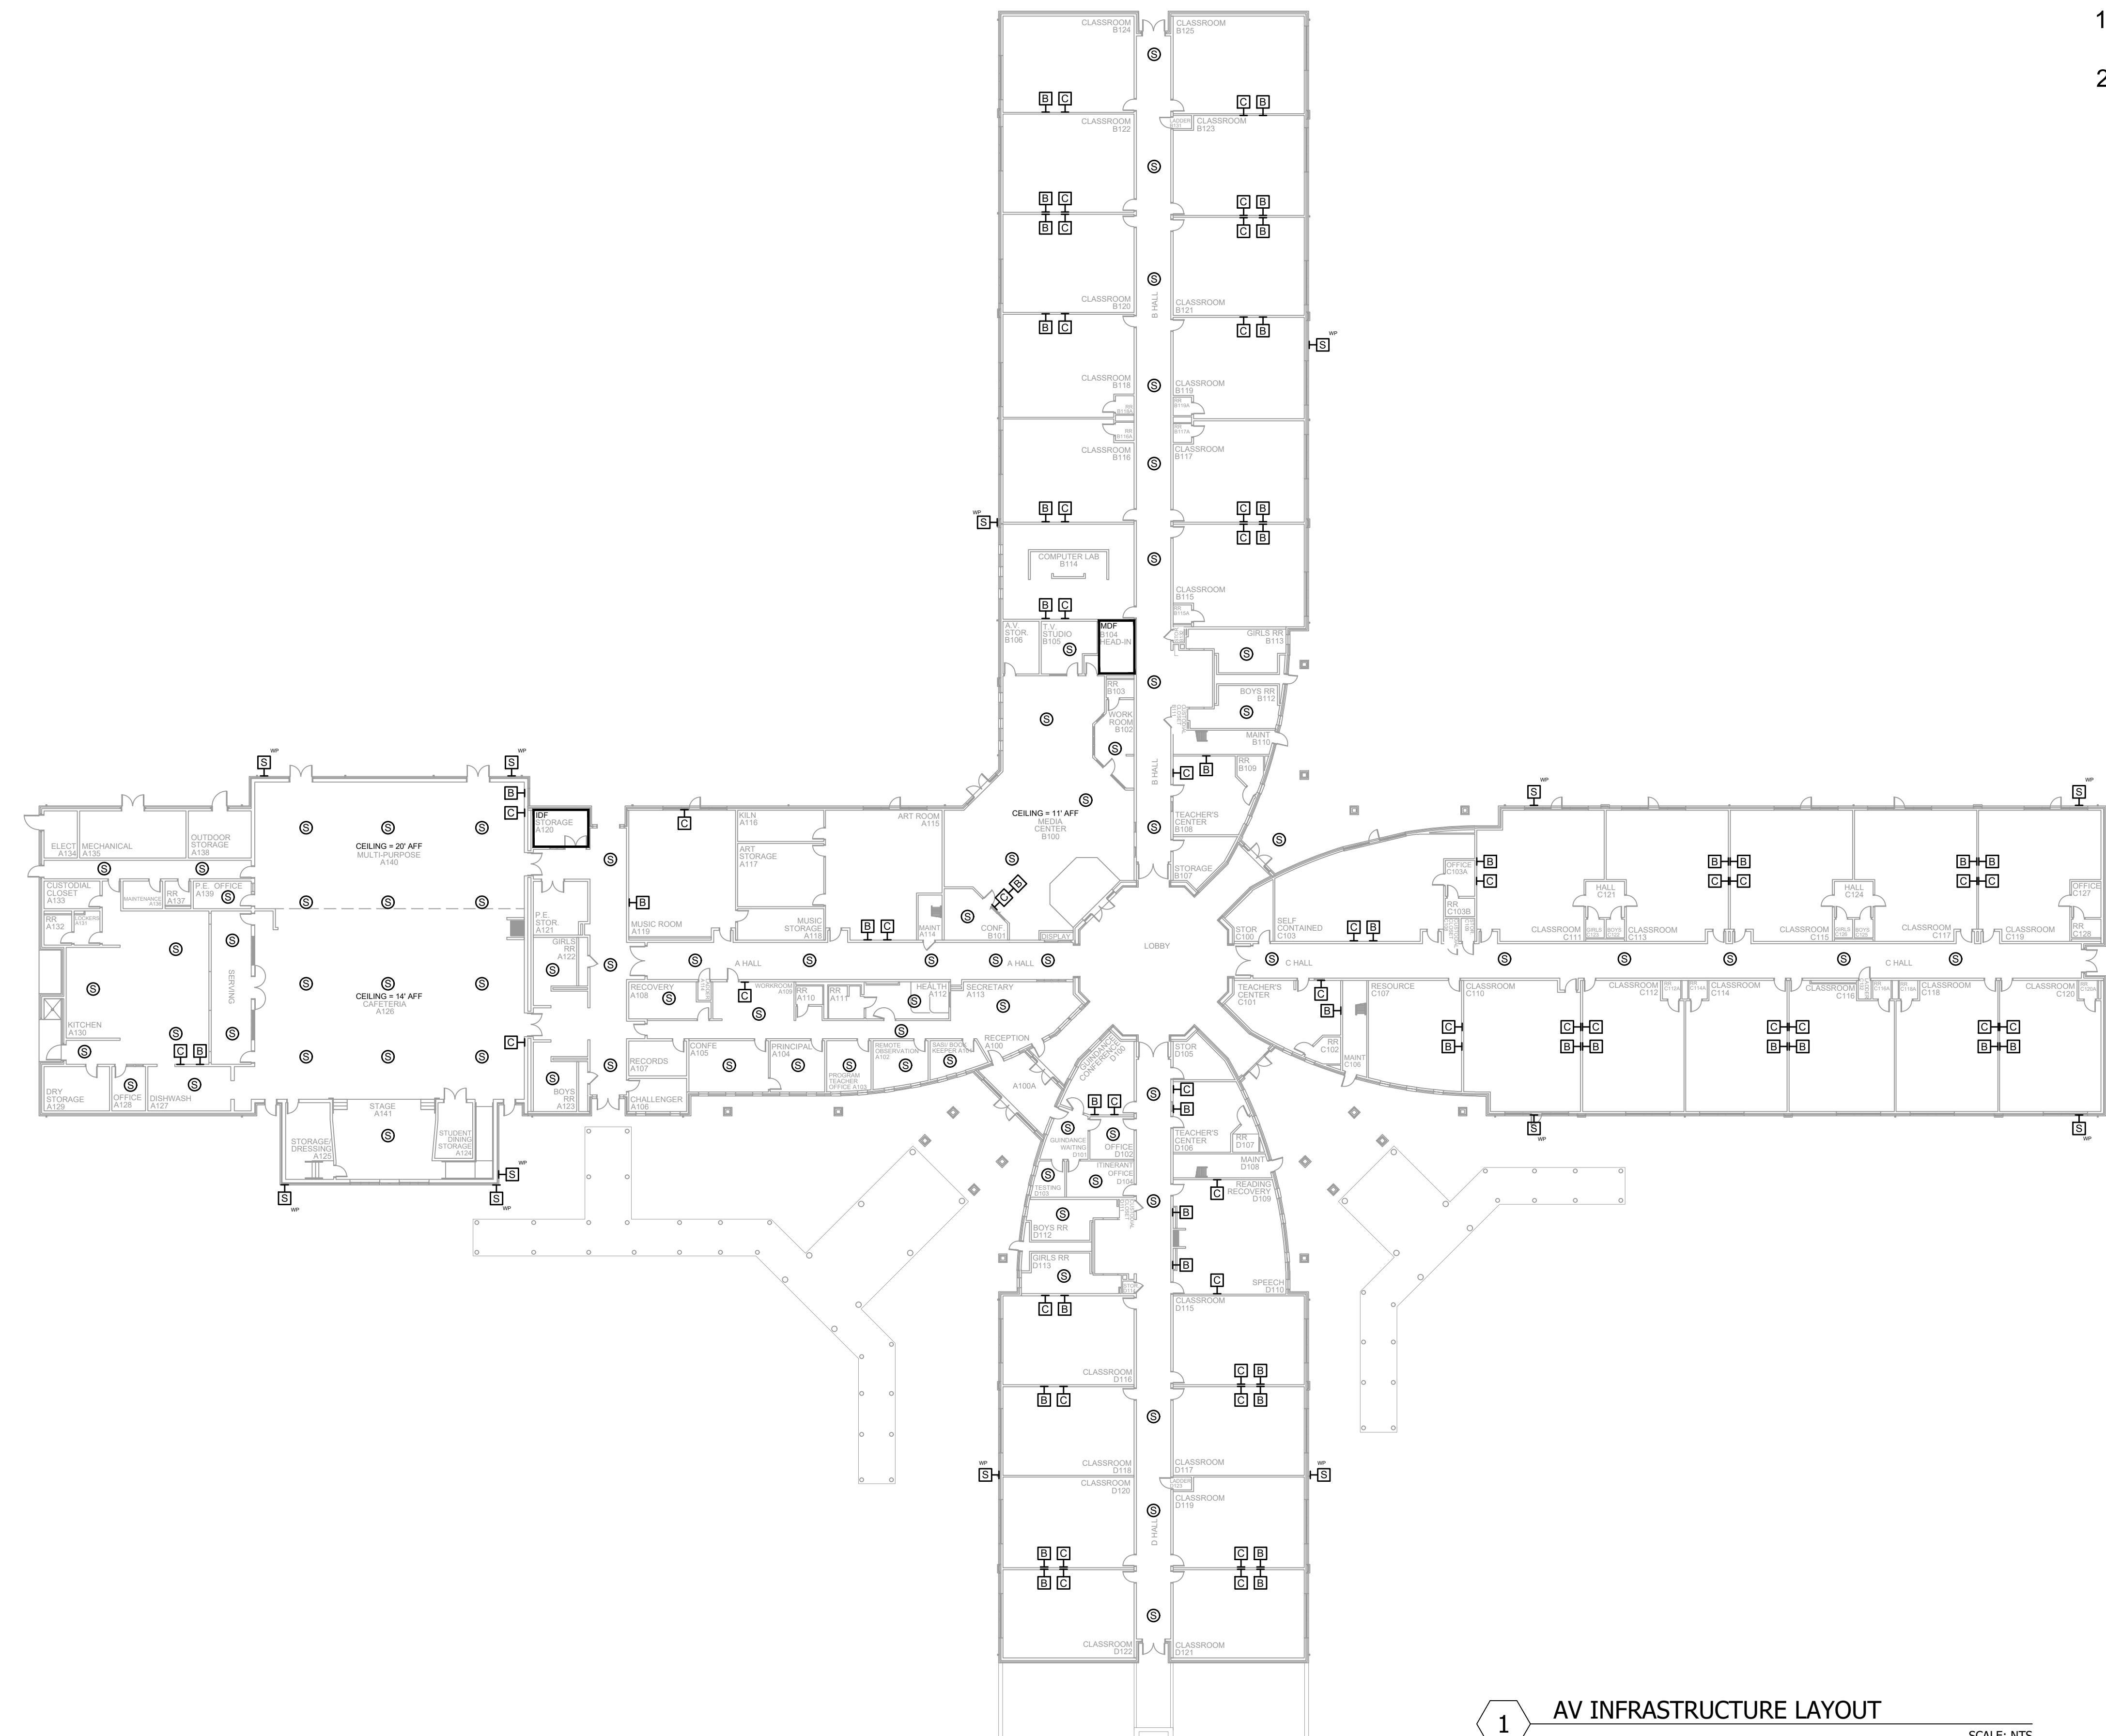

NOTES:

1. SEE DRAWING T-0-001 FOR SYMBOL LEGEND AND GENERAL NOTES.
2. CLASSROOMS & HALLWAY CEILINGS ARE 9.5' AFF.

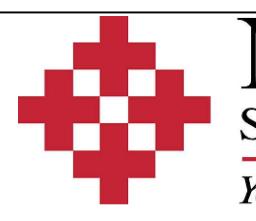

NetPlanner SYSTEMS, INC.[®]

Your Pathway to Connectivity

Your Pathway to Connectivity

Atlanta, GA	770-662-5482	Augusta, GA	706-364-4191
Raleigh, NC	919-290-8010	Columbus, GA	706-571-9091
Toll Free	800-795-1975	Savannah, GA	912-748-8961

www.netplanner.com



CLIENT LOGO

PROJECT INFO


ROCK HILL SCHOOLS ROCK HILL, SC

SHEET INFO

INTERCOM & NOTIFICATIONS

MT. HOLLY ELEMENTARY - NEW DEVICES

REVISIONS			ENGINEER APPROVAL	ENGINEER	DRAWING NAME
REV.	DESCRIPTION	DATE		WM	TA-1-19-101N
			CAD AK	CAD	PROJECT NUMBER
				AK	AR20245
			PROJECT MANAGER	APPROVED DRAWING DATE	
			SD	07-23-2021	RELEASE NUMBER 1

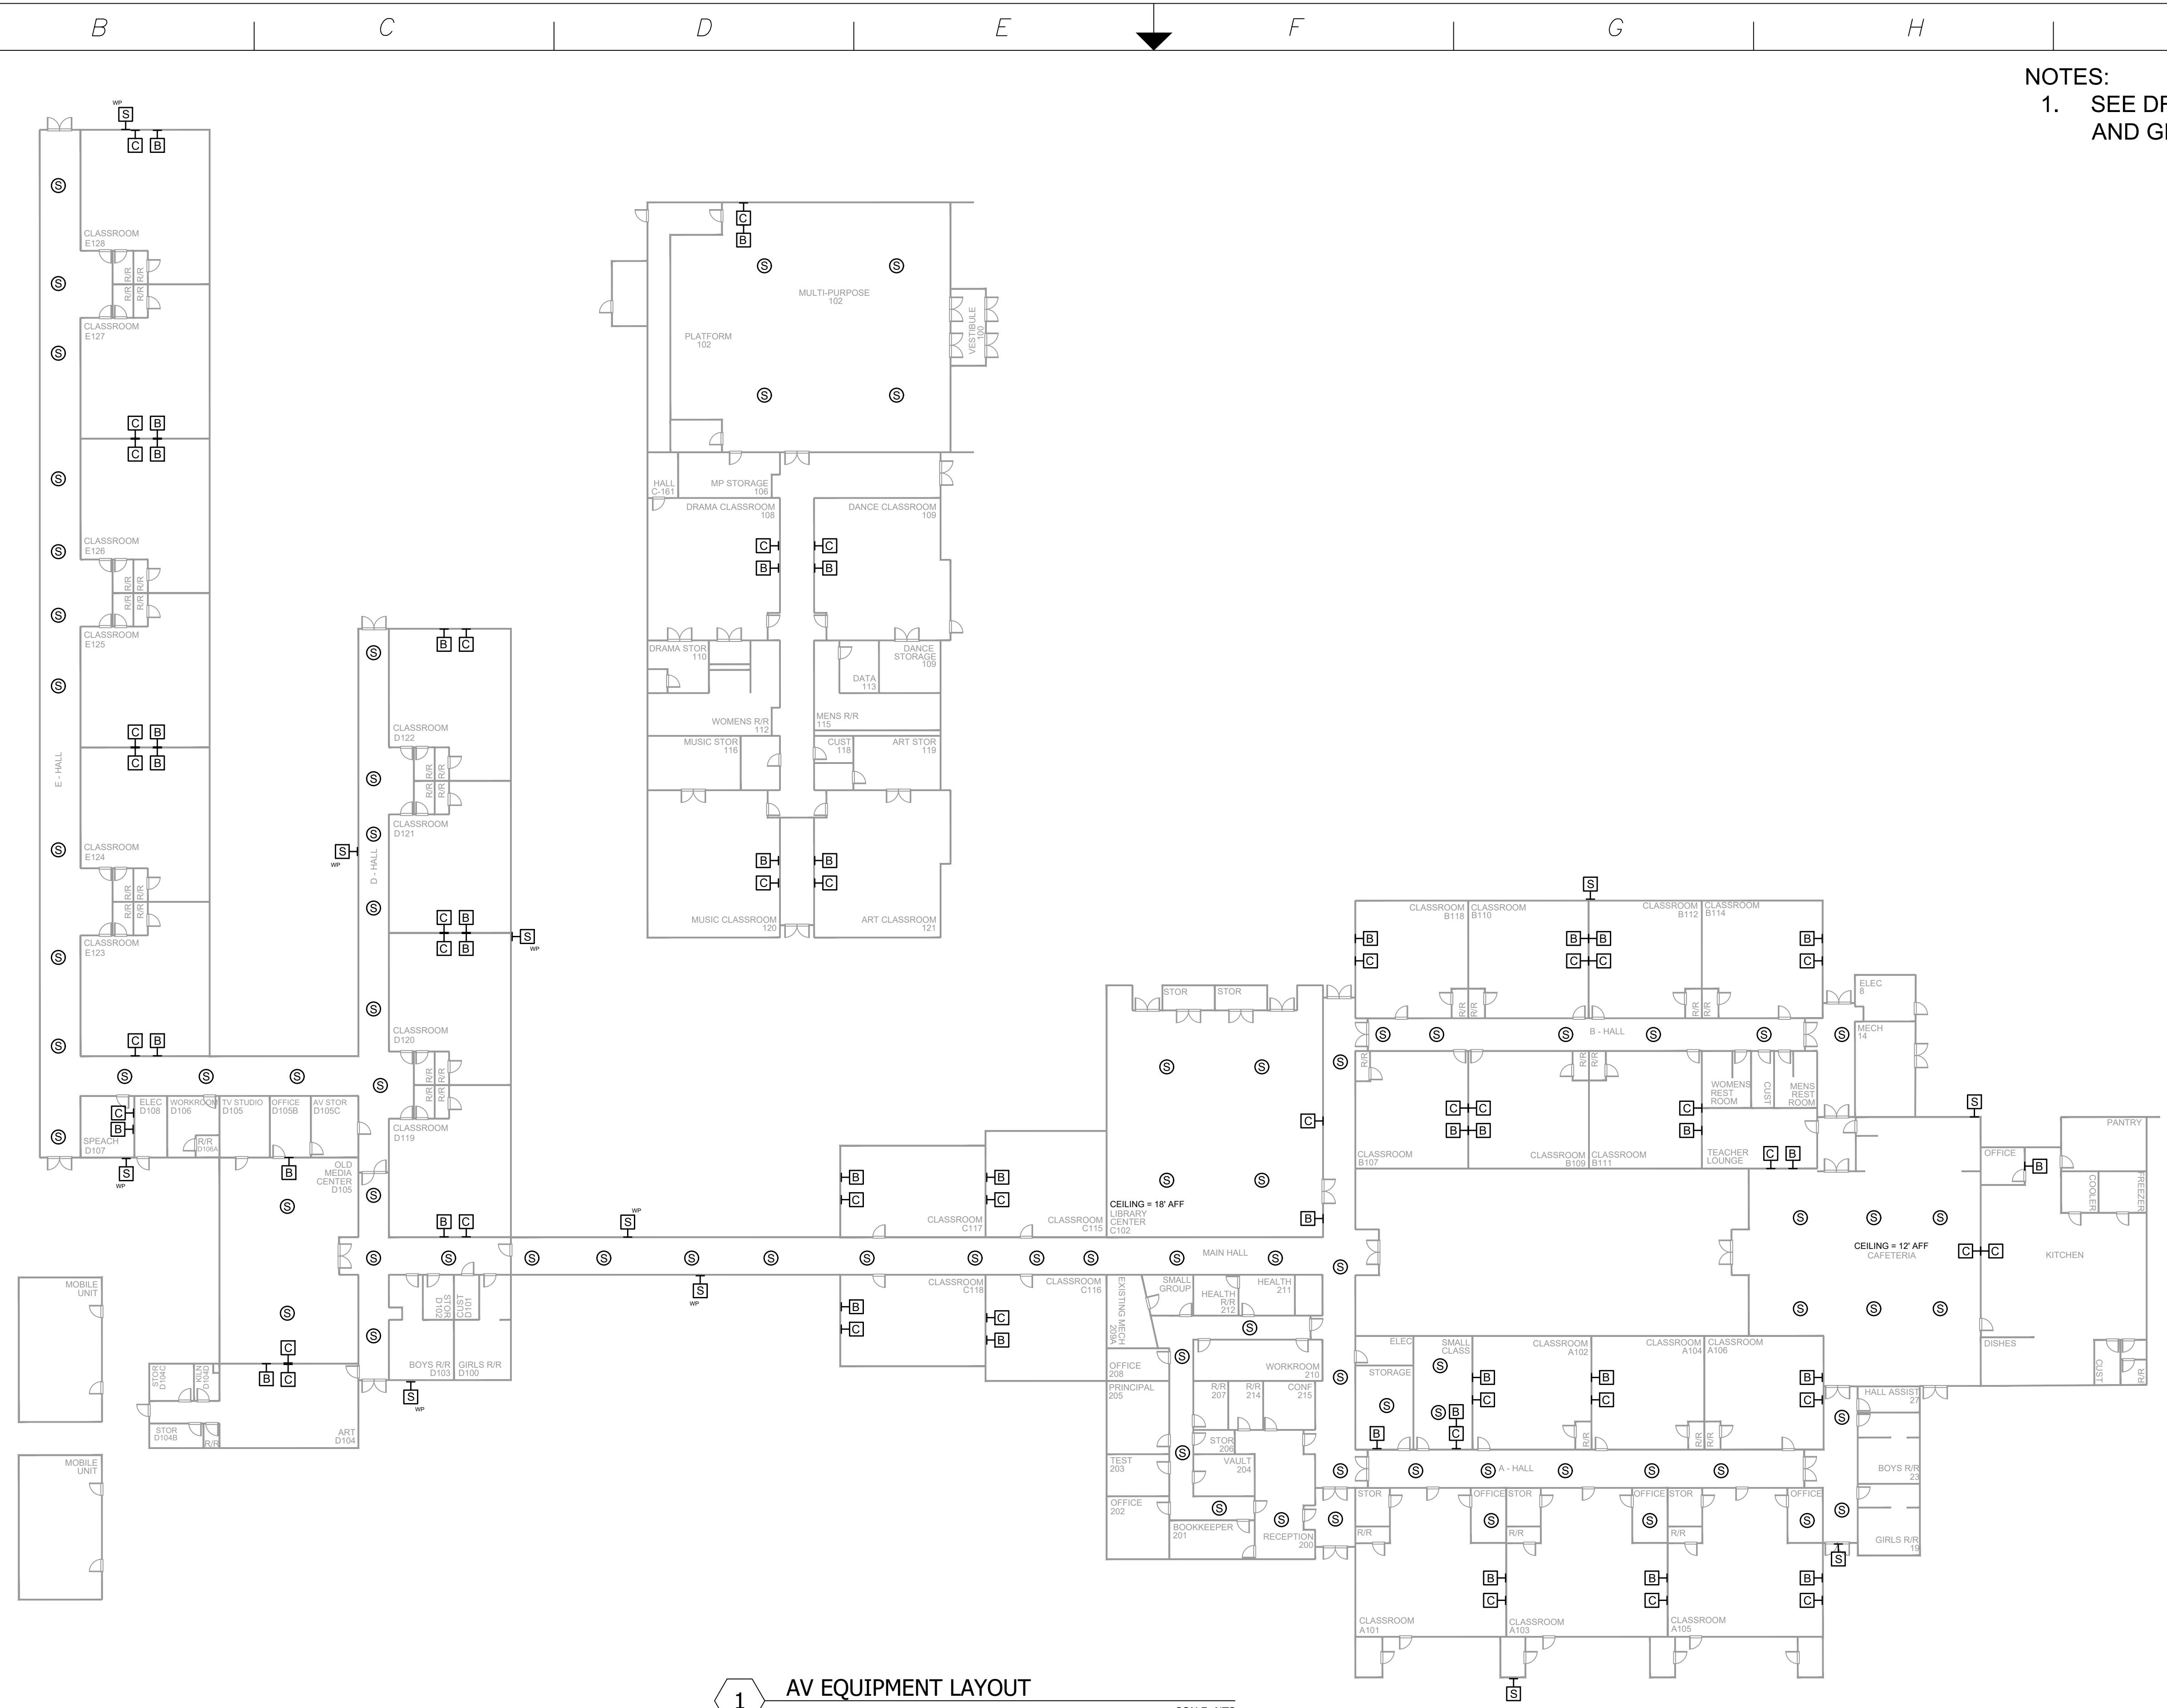

NOTES:

1. SEE DRAWING T-0-001 FOR SYMBOL LEGEND
AND GENERAL NOTES.



NetPlanner SYSTEMS, INC.[®]

Your Pathway to Connectivity

Atlanta, GA	770-662-5482	Augusta, GA	706-364-4190
Raleigh, NC	919-290-8010	Columbus, GA	706-571-9090
Toll Free	800-795-1975	Savannah, GA	912-748-8960

www.netplanner.com

CLIENT LOGO

PROJECT INFO

ROCK HILL SCHOOLS



ROCK HILL, SC

SHEET INFO

INTERCOM & NOTIFICATIONS

NORTHSIDE ELEMENTARY - NEW DEVICES

REVISIONS			ENGINEER APPROVAL	ENGINEER WM	DRAWING NAME
REV.	DESCRIPTION	DATE			TA-1-20-101N
				CAD AK	PROJECT NUMBER
					AR20245
				PROJECT MANAGER SD	APPROVED DRAWING DATE
					07-23-2021
					RELEASE NUMBER
					1

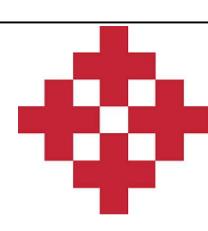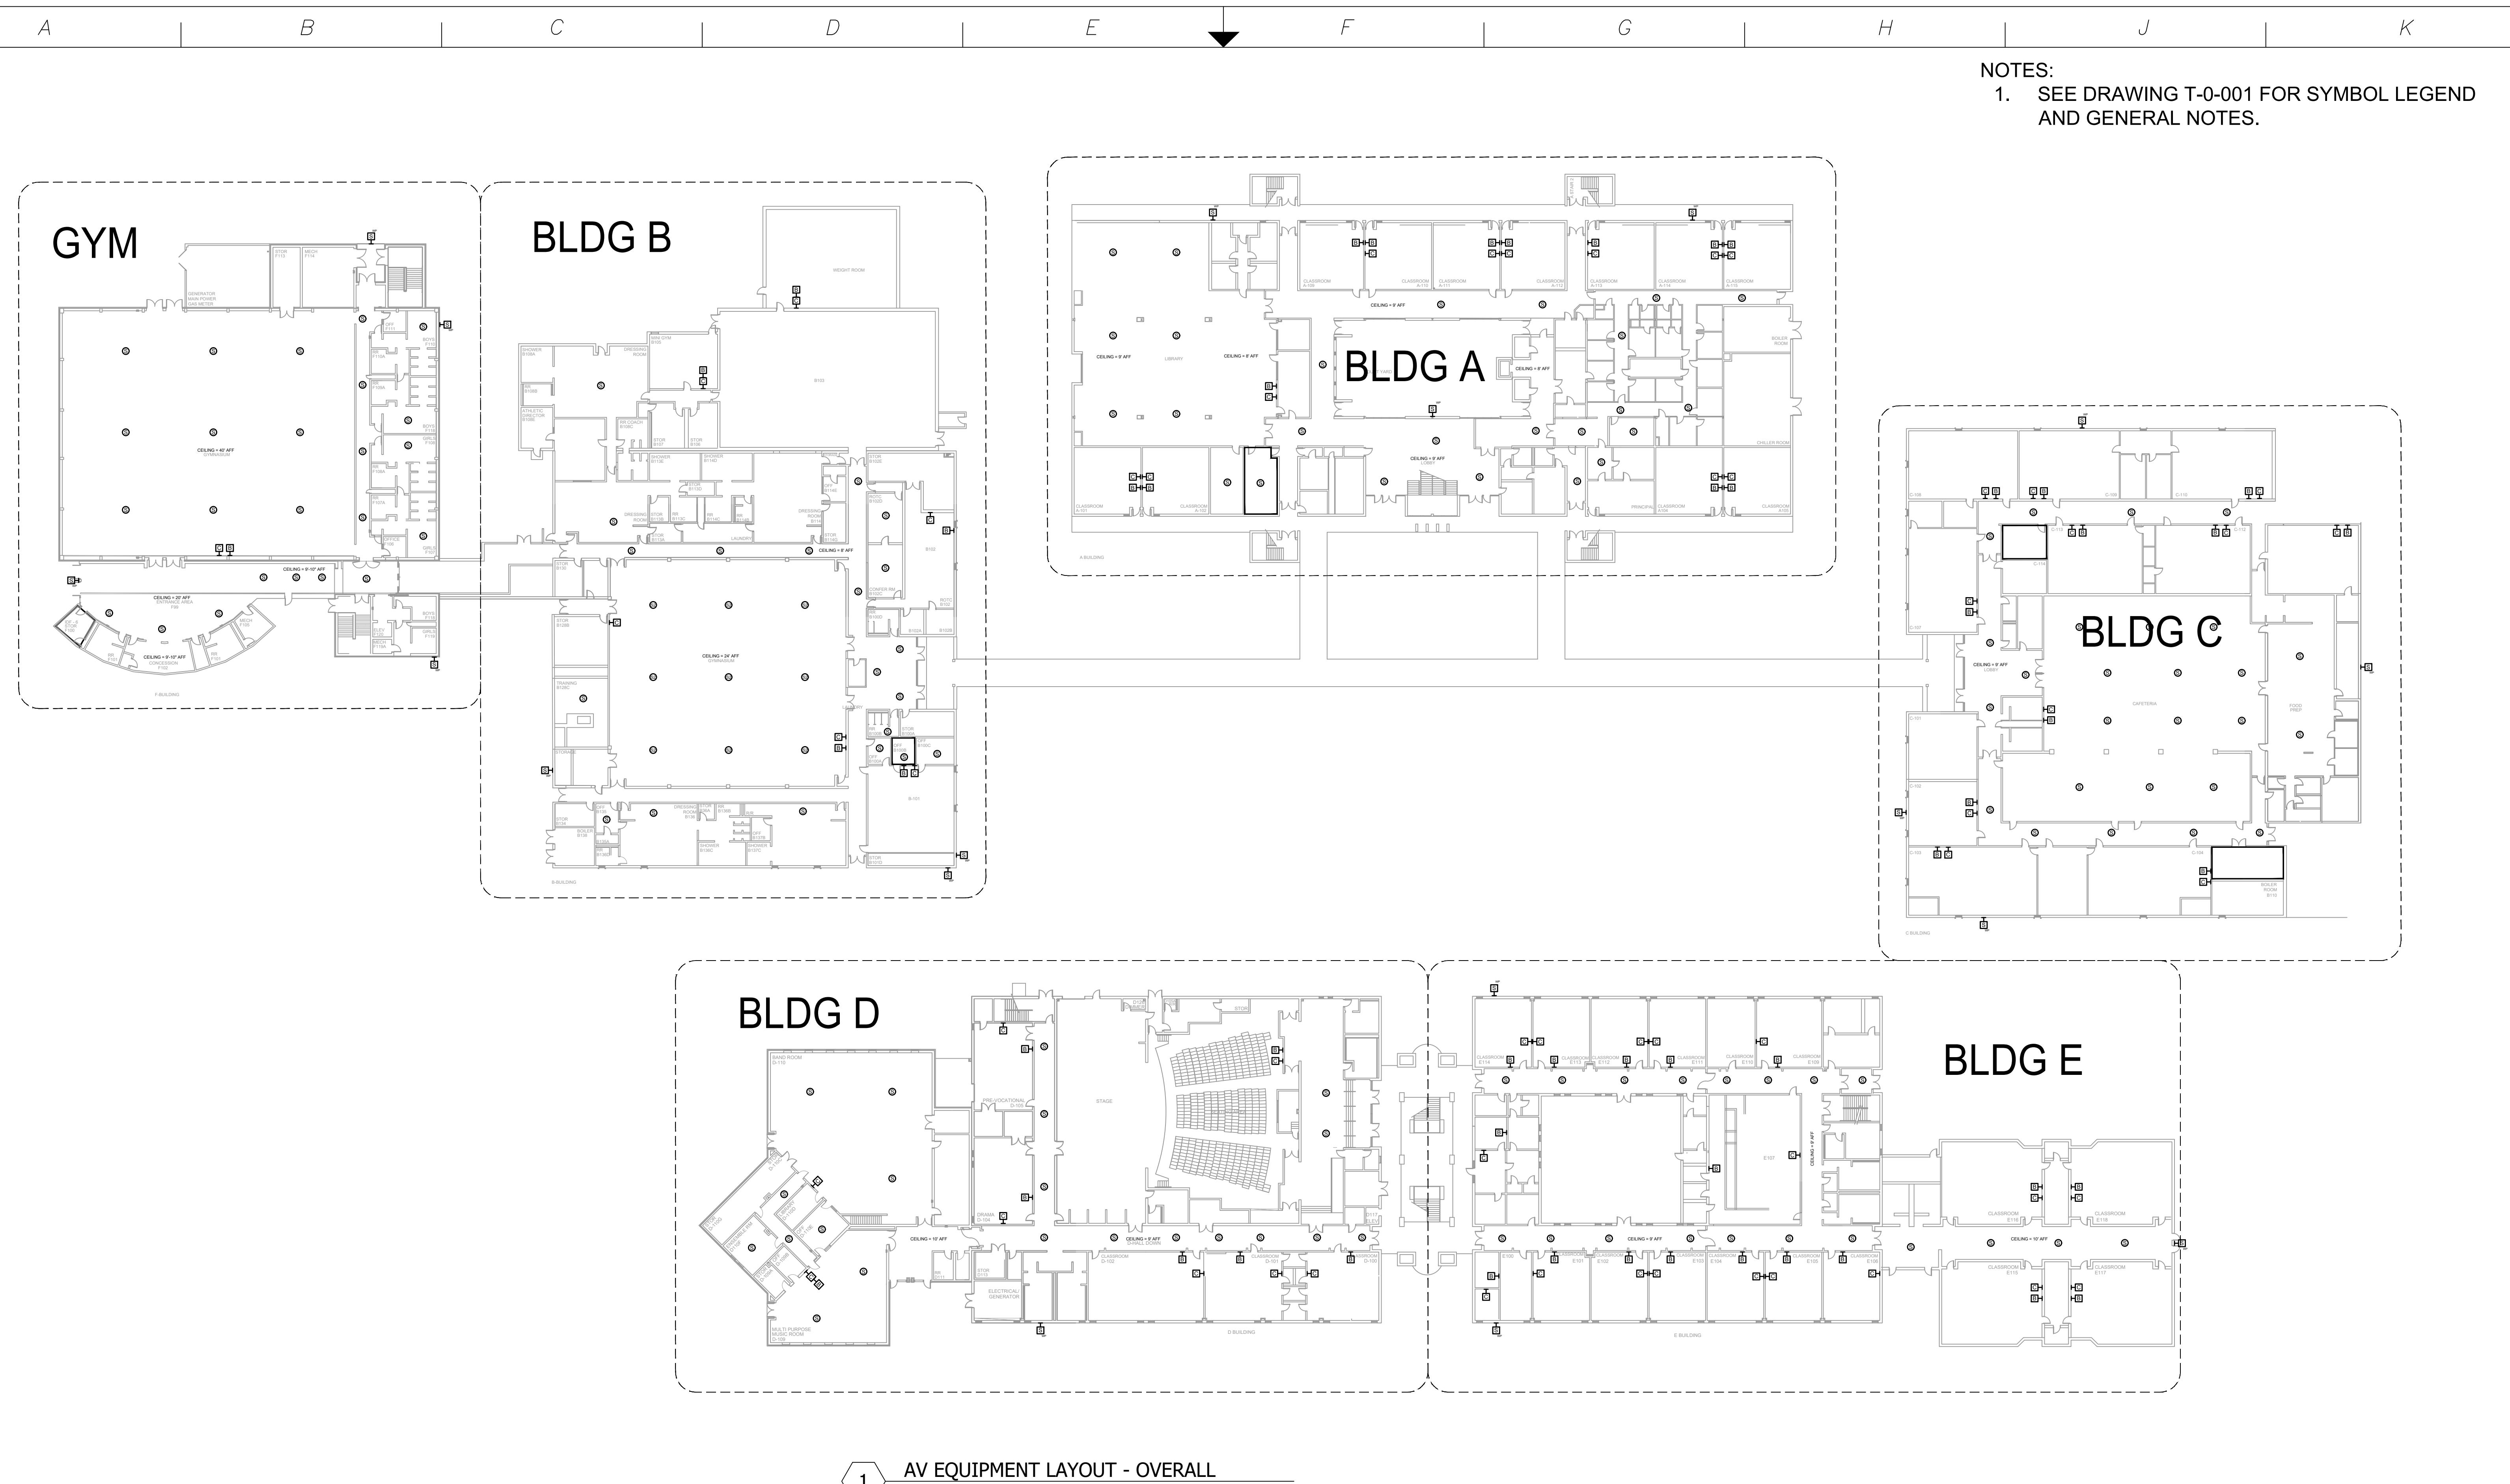

NetPlanner SYSTEMS, INC.[®]

Your Pathway to Connectivity

Your Pathway to Connectivity

Atlanta, GA	770-662-5482	Augusta, GA	706-364-
Raleigh, NC	919-290-8010	Columbus, GA	706-571-
Toll Free	800-795-1975	Savannah, GA	912-748-

www.netplanner.com



CLIENT LOGO

PROJECT INFO

ROCK HILL SCHOOLS

ROCK HILL, SC



SHEET INFO

INTERCOM & NOTIFICATIONS

NORTHWESTERN HS - 1ST FLOOR OVERALL - NEW DEVICES

NOTES:

1. SEE DRAWING T-0-001 FOR SYMBOL LEGEND AND GENERAL NOTES.

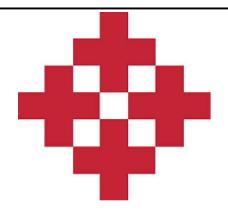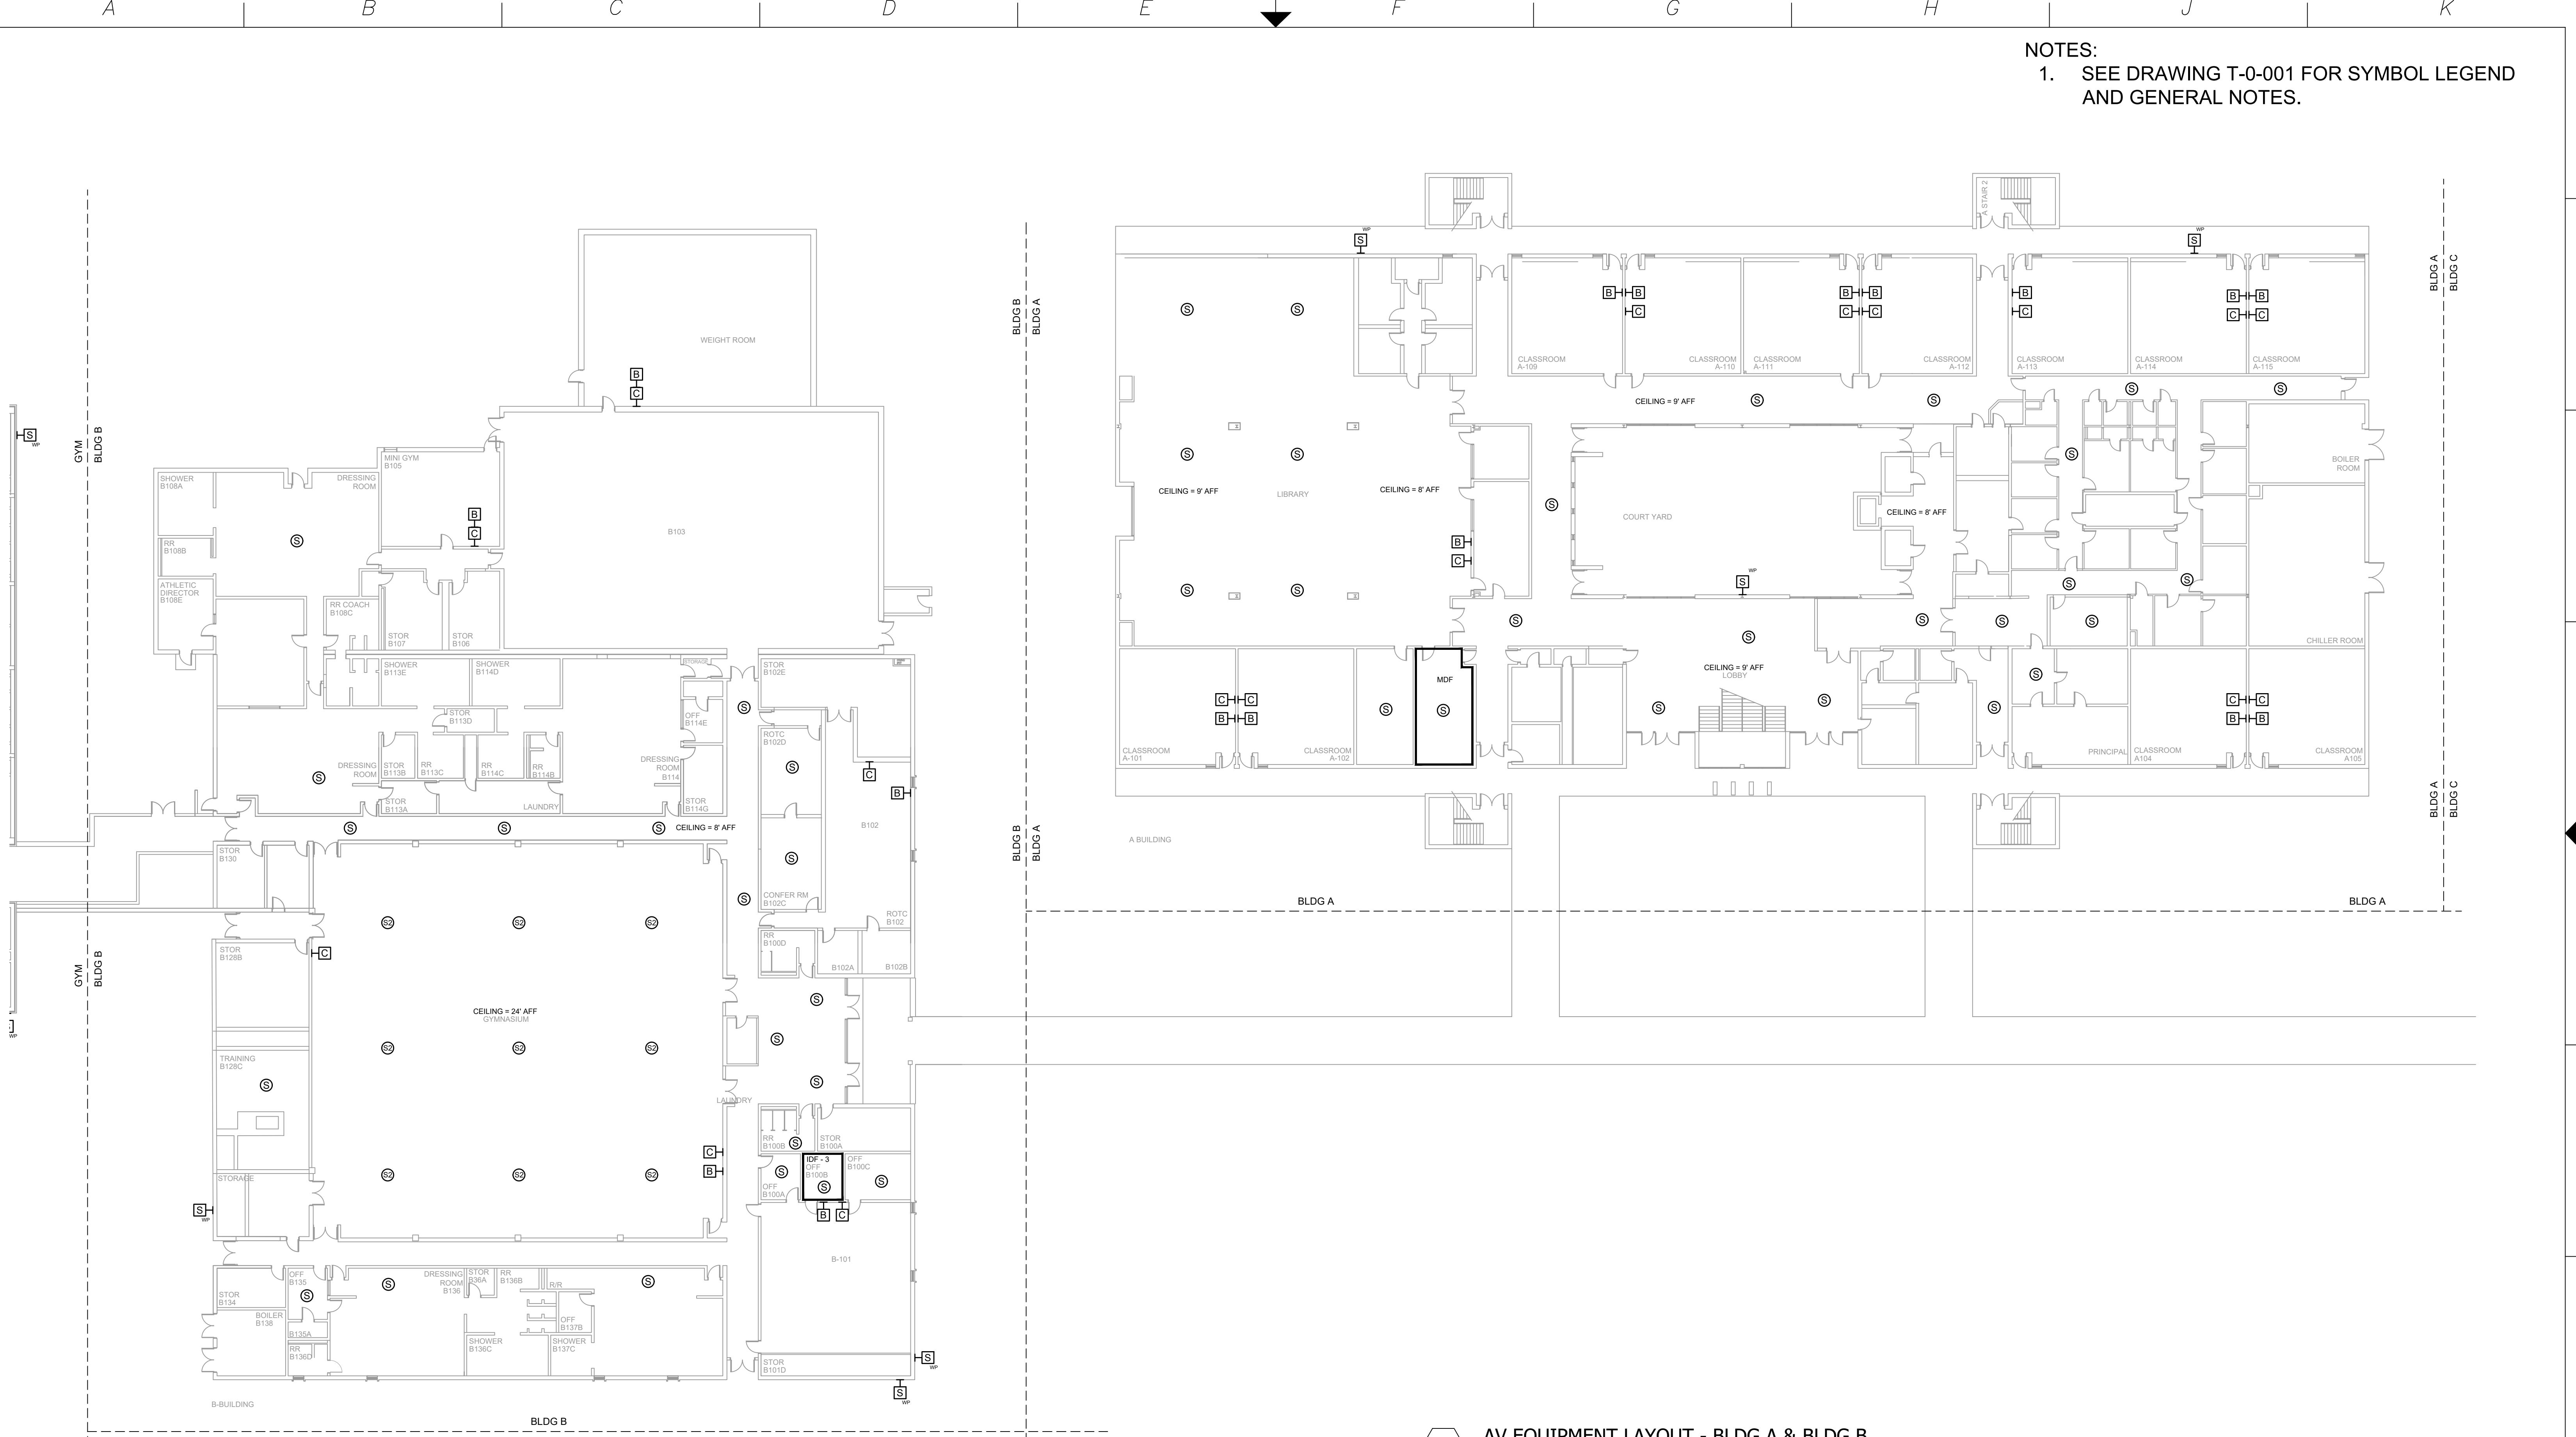

NetPlanner SYSTEMS, INC.[®]

Atlanta
Raleigh
Tallahassee

770-662-5482 Augusta, GA
919-290-8010 Columbus, GA
800-795-1975 Savannah, GA
www.netplanner.com

706-36
706-57
212-5

64-419
71-909
48-222

CLIENT LOC

LL
14

PROJECT INFO

ROCK HILL SCHOOLS

ROCK HILL, SC

SHEET INFO


INTERCOM & NOTIFICATIONS

**NORTHWESTERN HS - 1ST FLOOR BLDG A & B
- NEW DEVICES**

REVISIONS			ENGINEER APPROVAL	ENGINEER WM	DRAWING NAME
REV.	DESCRIPTION	DATE			TA-1-21-101N
				CAD	PROJECT NUMBER
				AK	AR20245
				PROJECT MANAGER	APPROVED DRAWING DATE
				SD	07-23-2021
					RELEASE NUMBER
					1

A B C D E F G H J K

NOTES:
1. SEE DRAWING T-0-001 FOR SYMBOL LEGEND
AND GENERAL NOTES.

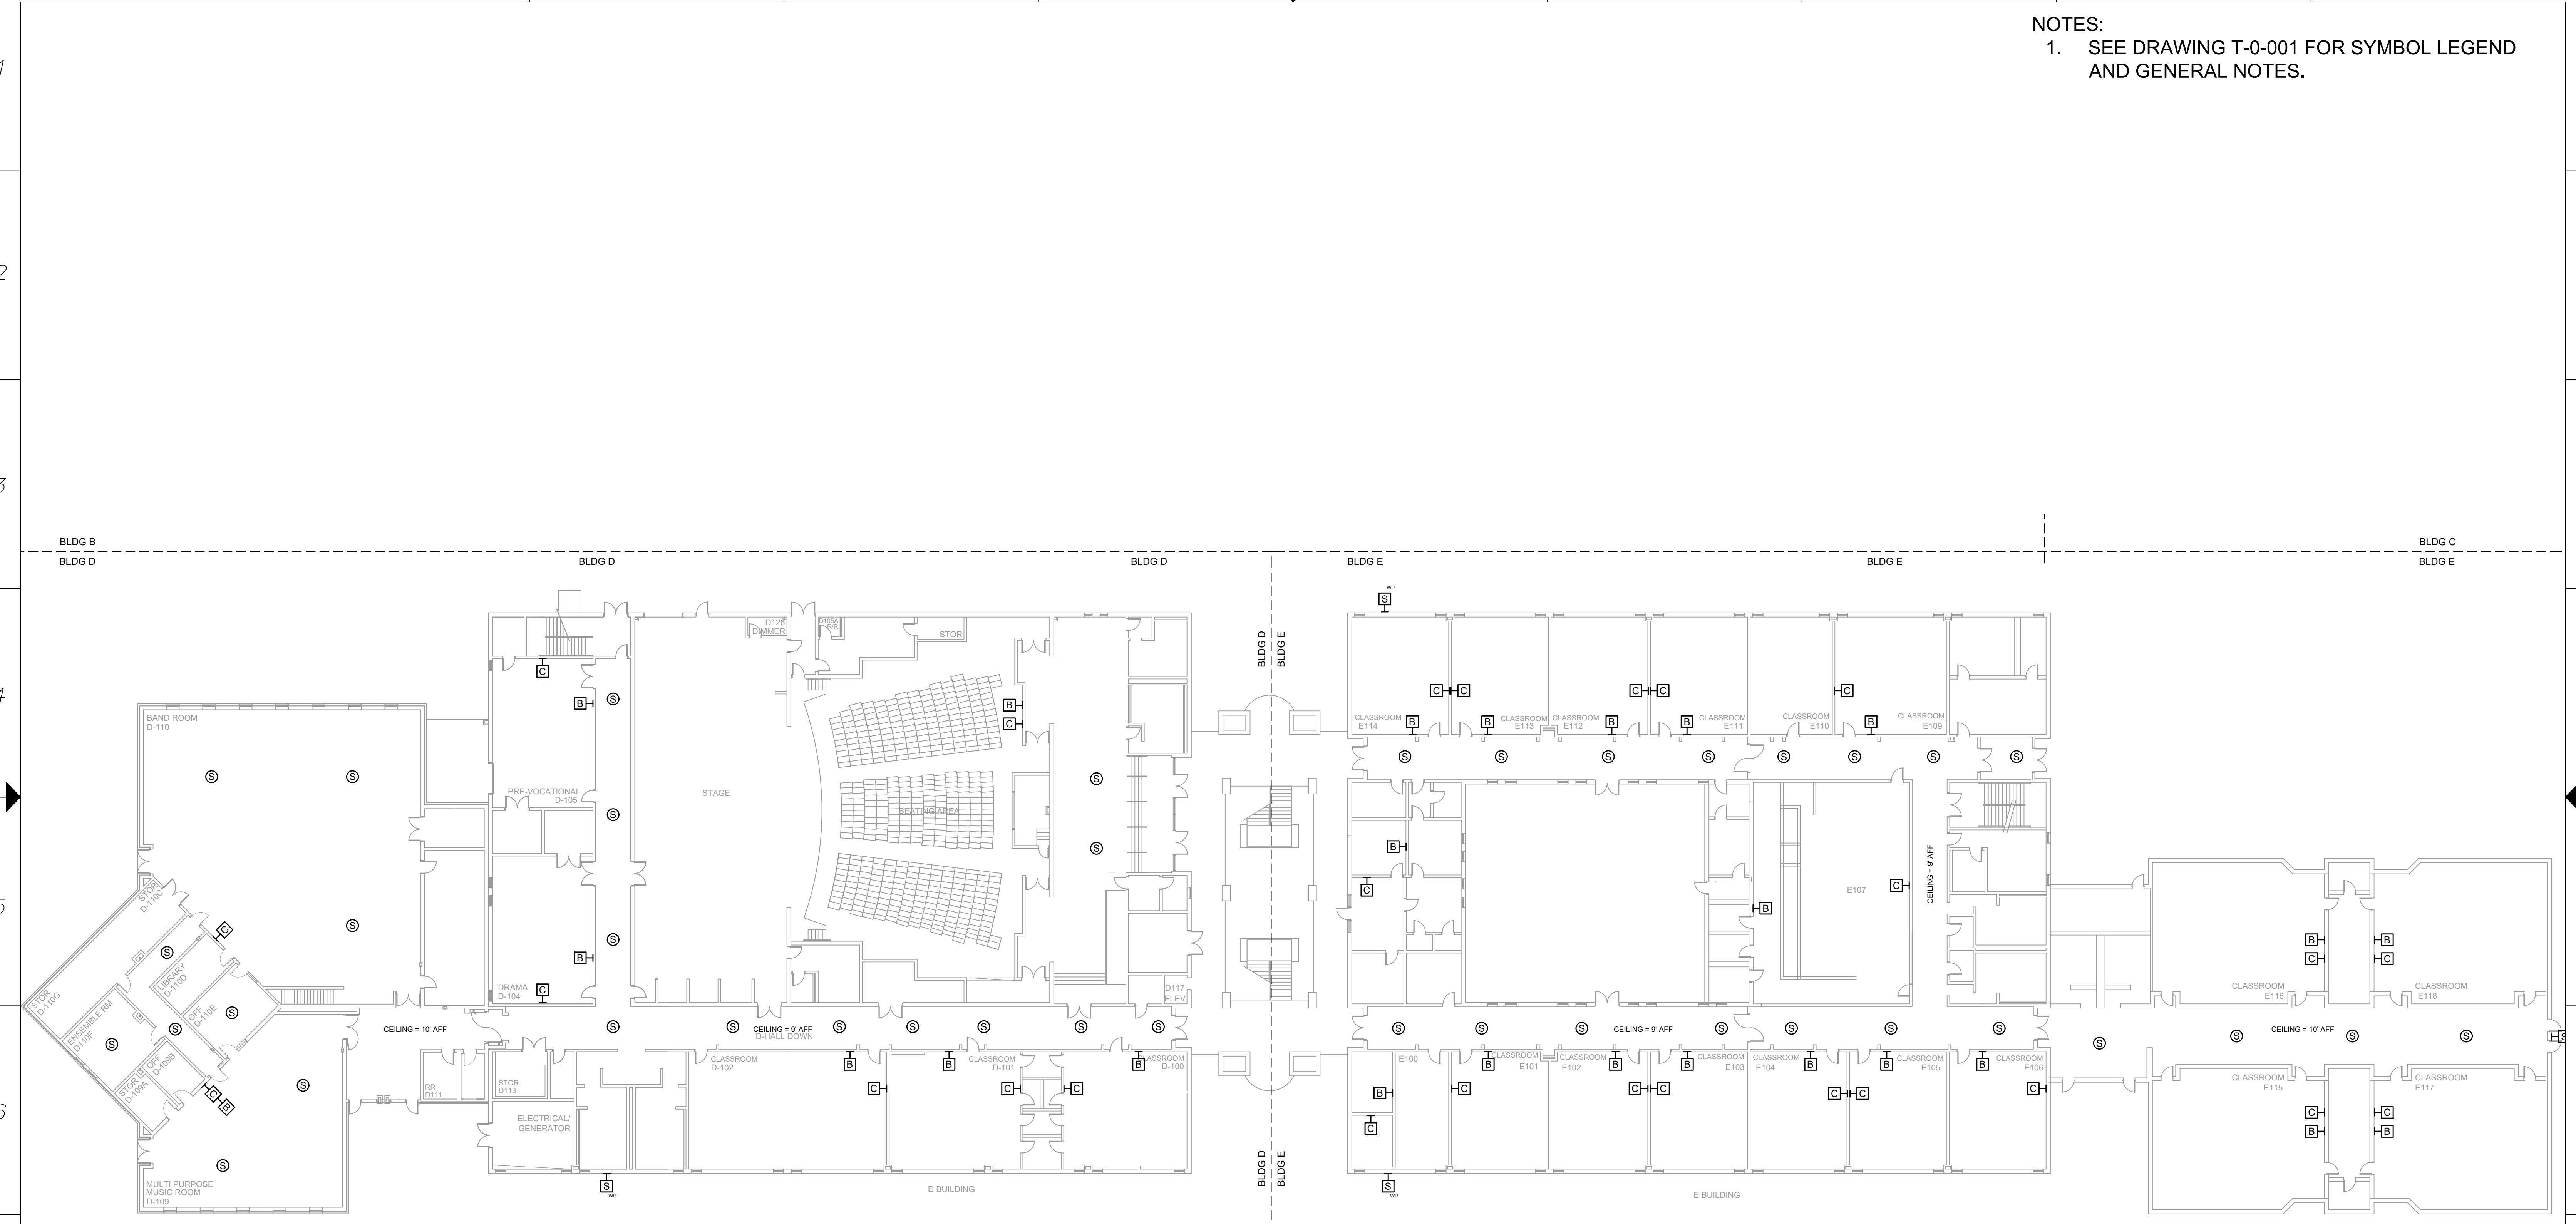

1 AV EQUIPMENT LAYOUT - BLDG E & D
SCALE: NTS



REVISIONS		
REV.	DESCRIPTION	DATE

ENGINEER APPROVAL	ENGINEER	DRAWING NAME
	WM	TA-1-21-103N
	AK	PROJECT NUMBER
SD	AR20245	RELEASE NUMBER 1
SD	APPROVED DRAWING DATE 07-23-2021	RELEASE NUMBER 1

A


NOTES:

1. SEE DRAWING T-0-001 FOR SYMBOL LEGEND AND GENERAL NOTES.

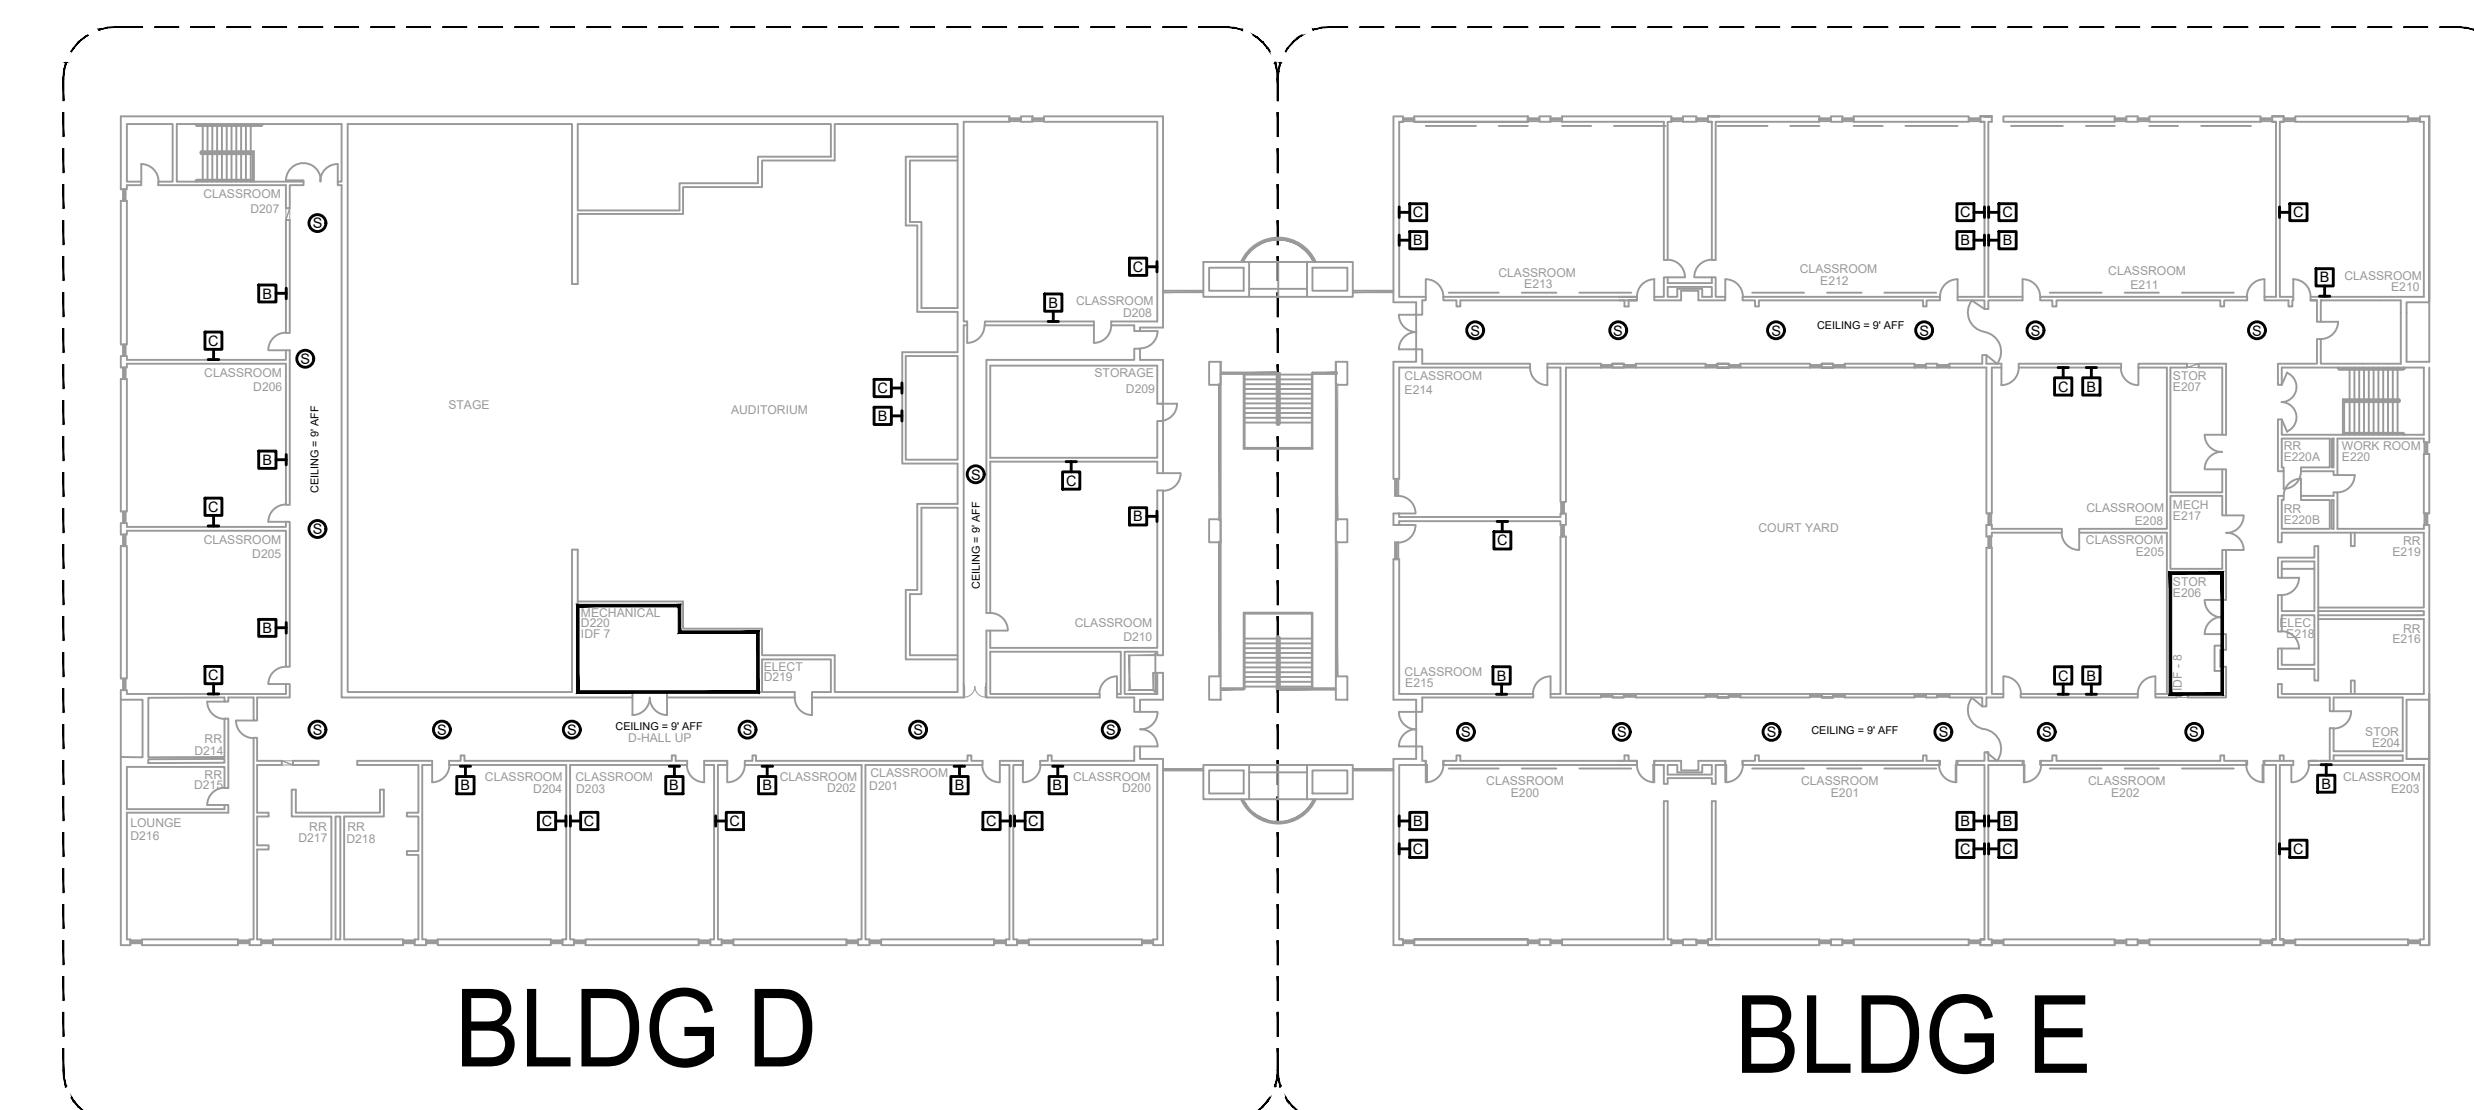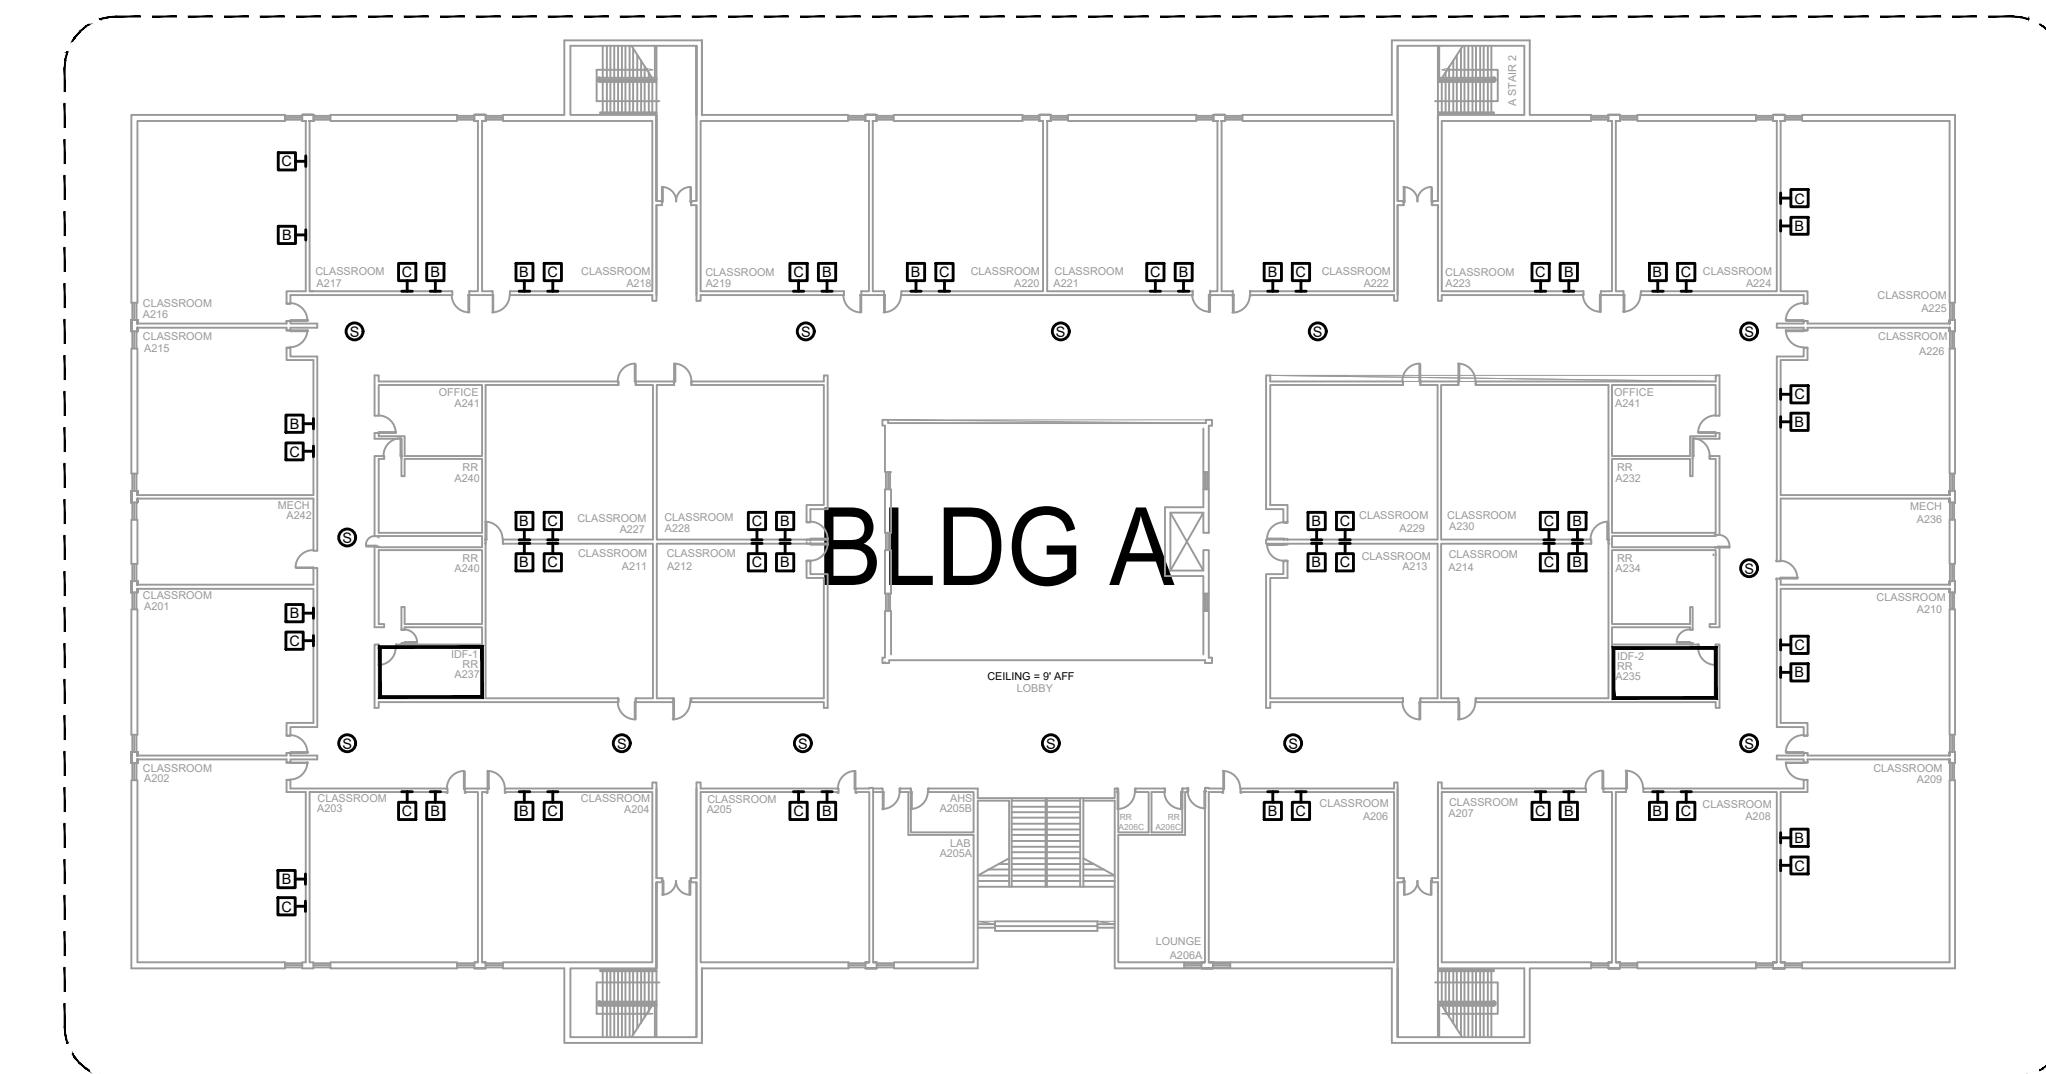

AV EQUIPMENT LAYOUT - OVERALL

SCM 107

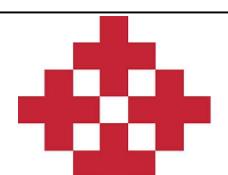

NetPlanner SYSTEMS, INC.[®]

Your Pathway to Connectivity			
Atlanta, GA	770-662-5482	Augusta, GA	706-364-4190
Raleigh, NC	919-290-8010	Columbus, GA	706-571-9090
Toll Free	800-795-1975	Savannah, GA	912-748-8960

CLIENT LOGO

PROJECT INFO

ROCK HILL SCHOOL ROCK HILL, SC

SHEET INFO

INTERCOM & NOTIFICATIONS

NORTHWESTERN HS - 2ND FLOOR

OVERALL - NEW DEVICES


EN
AF

INEE
ROVA

DRAWING NAME
TA-1-21-200N
PROJECT NUMBER
AR20245
APPROVED DRAWING DATE
07-23-2021

A B C D E F G H J K

NOTES:
1. SEE DRAWING T-0-001 FOR SYMBOL LEGEND
AND GENERAL NOTES.

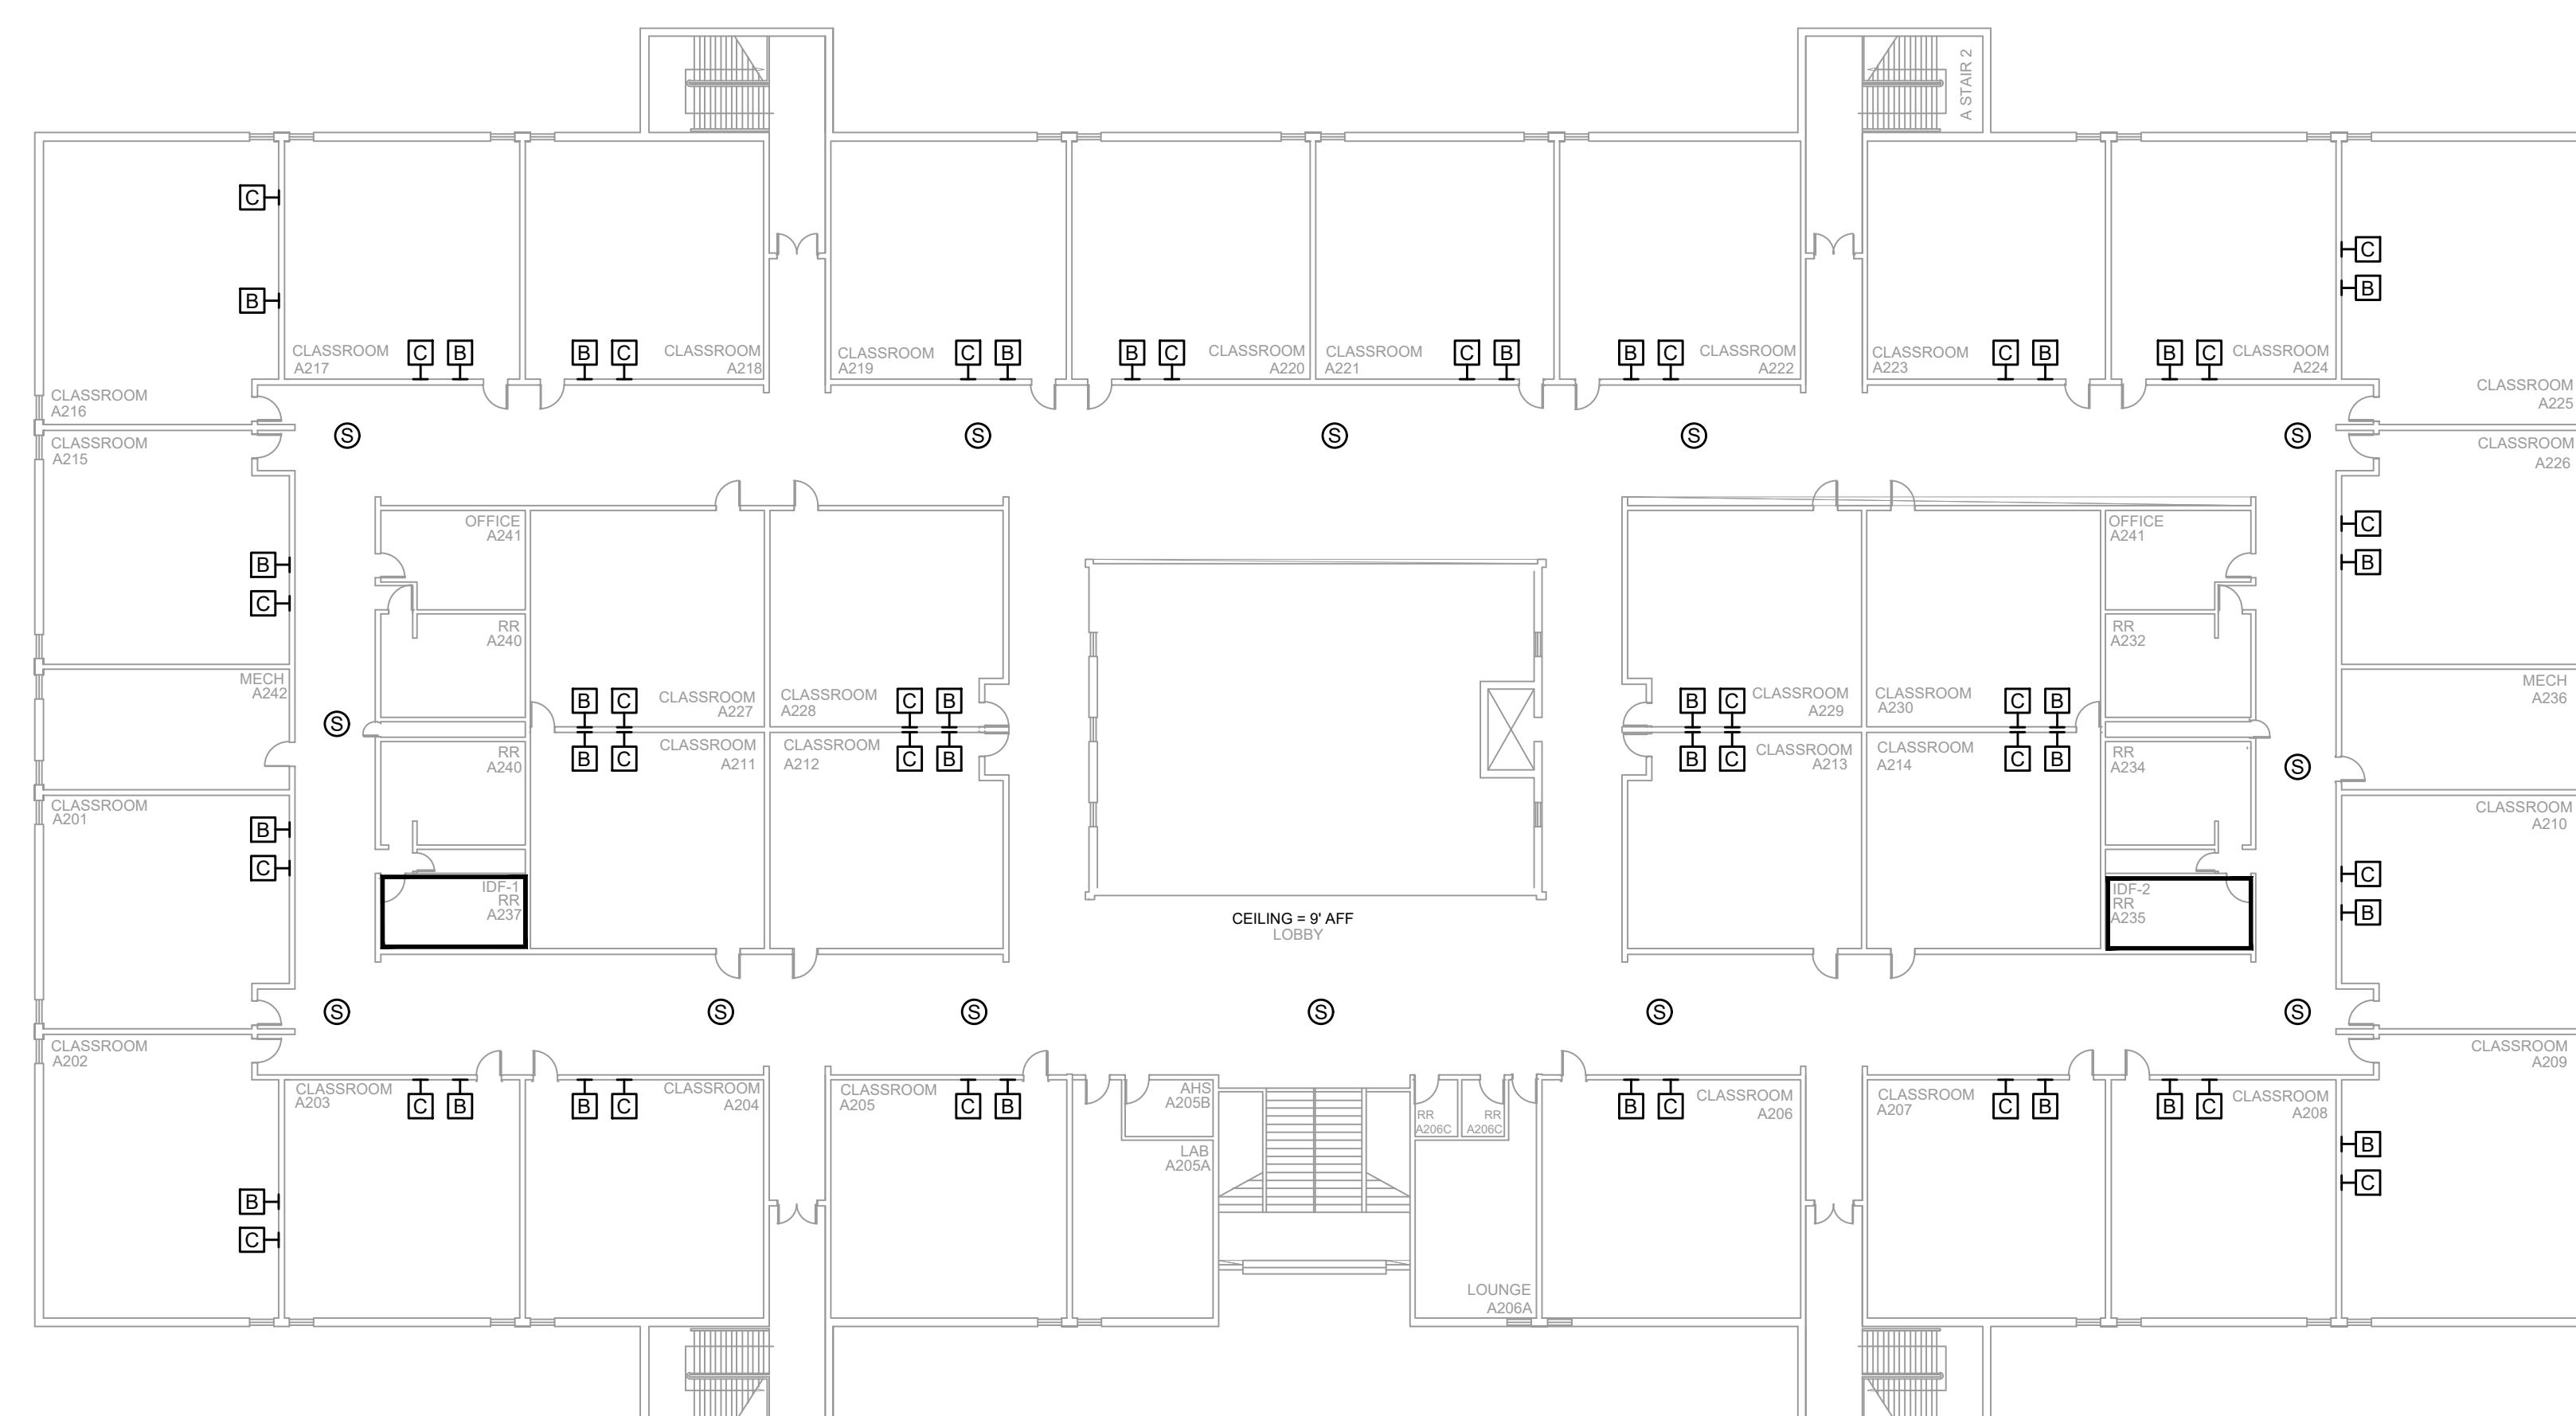

AV EQUIPMENT LAYOUT - BLDG A

SCALE: NTS



CLIENT LOGO

PROJECT INFO
ROCK HILL SCHOOLS
ROCK HILL, SC

SHEET INFO
INTERCOM & NOTIFICATIONS
NORTHWESTERN HS - 2ND FLOOR BLDG A -
NEW DEVICES

REVISIONS		
REV.	DESCRIPTION	DATE

ENGINEER APPROVAL

ENGINEER WM

CAD AK

PROJECT NUMBER AR20245

PROJECT MANAGER SD

APPROVED DRAWING DATE 07-23-2021


RELEASE NUMBER 1

DRAWING NAME
TA-1-21-201N

A B C D E F G H J K

A B C D E F G H J K

NOTES:
1. SEE DRAWING T-0-001 FOR SYMBOL LEGEND
AND GENERAL NOTES.


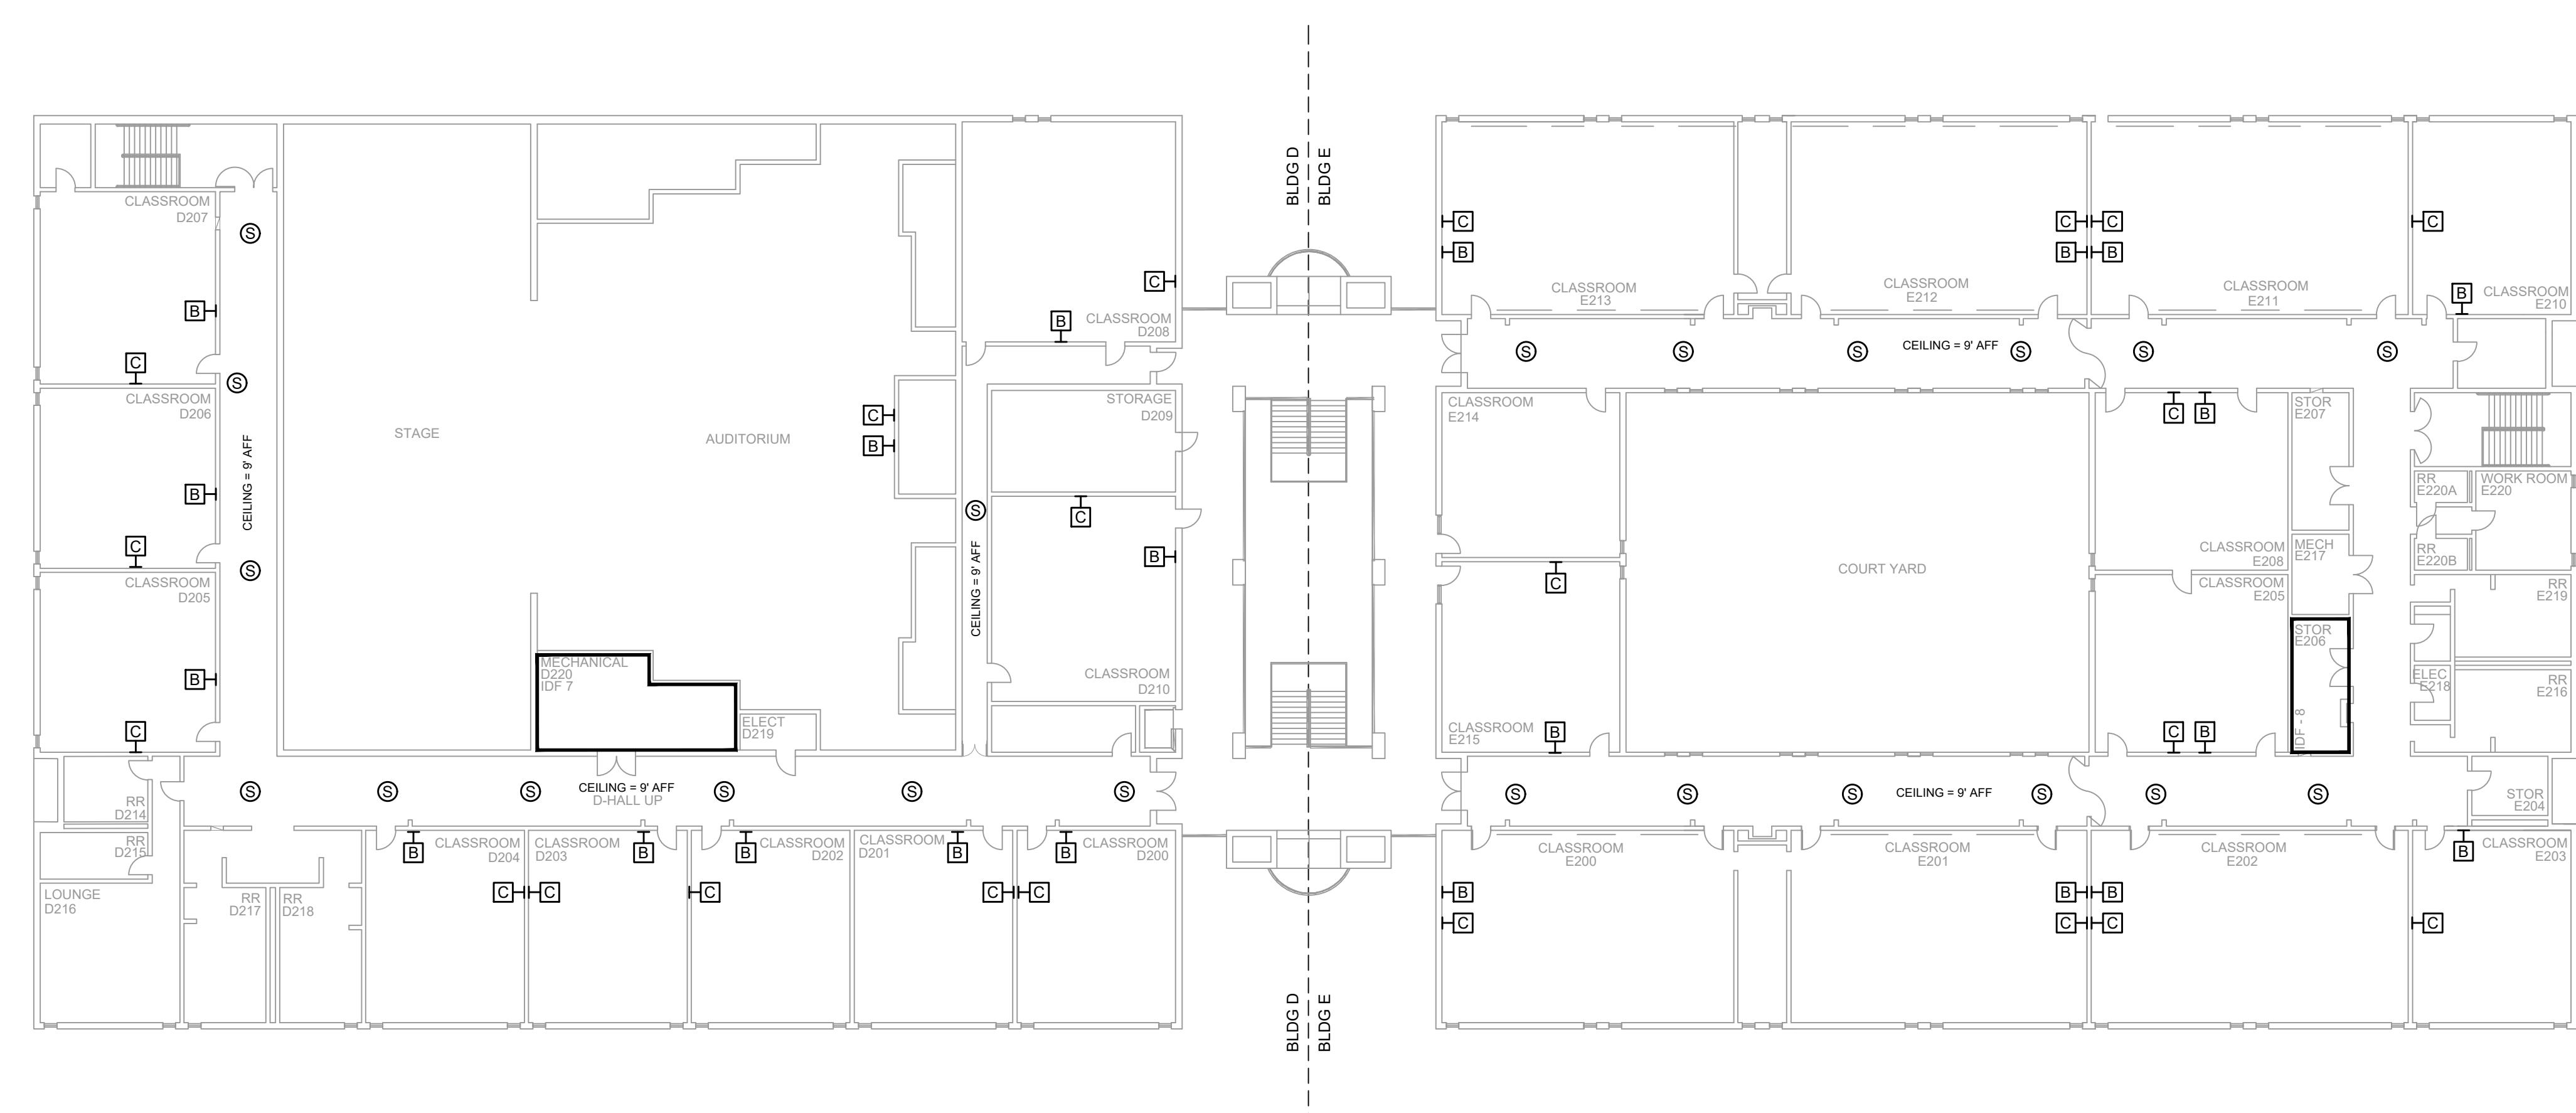


1 AV EQUIPMENT LAYOUT - BLDG E & D

SCALE: NTS

REV.	DESCRIPTION	DATE	REVISIONS	
			ENGINEER APPROVAL	ENGINEER DRAWING NAME
			WM	TA-1-21-202N
			AK	PROJECT NUMBER
			SD	AR20245
				PROJECT MANAGER APPROVED DRAWING DATE
				07-23-2021 RELEASE NUMBER
				1

A B C D E F G H J K

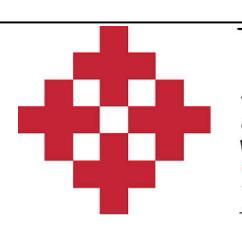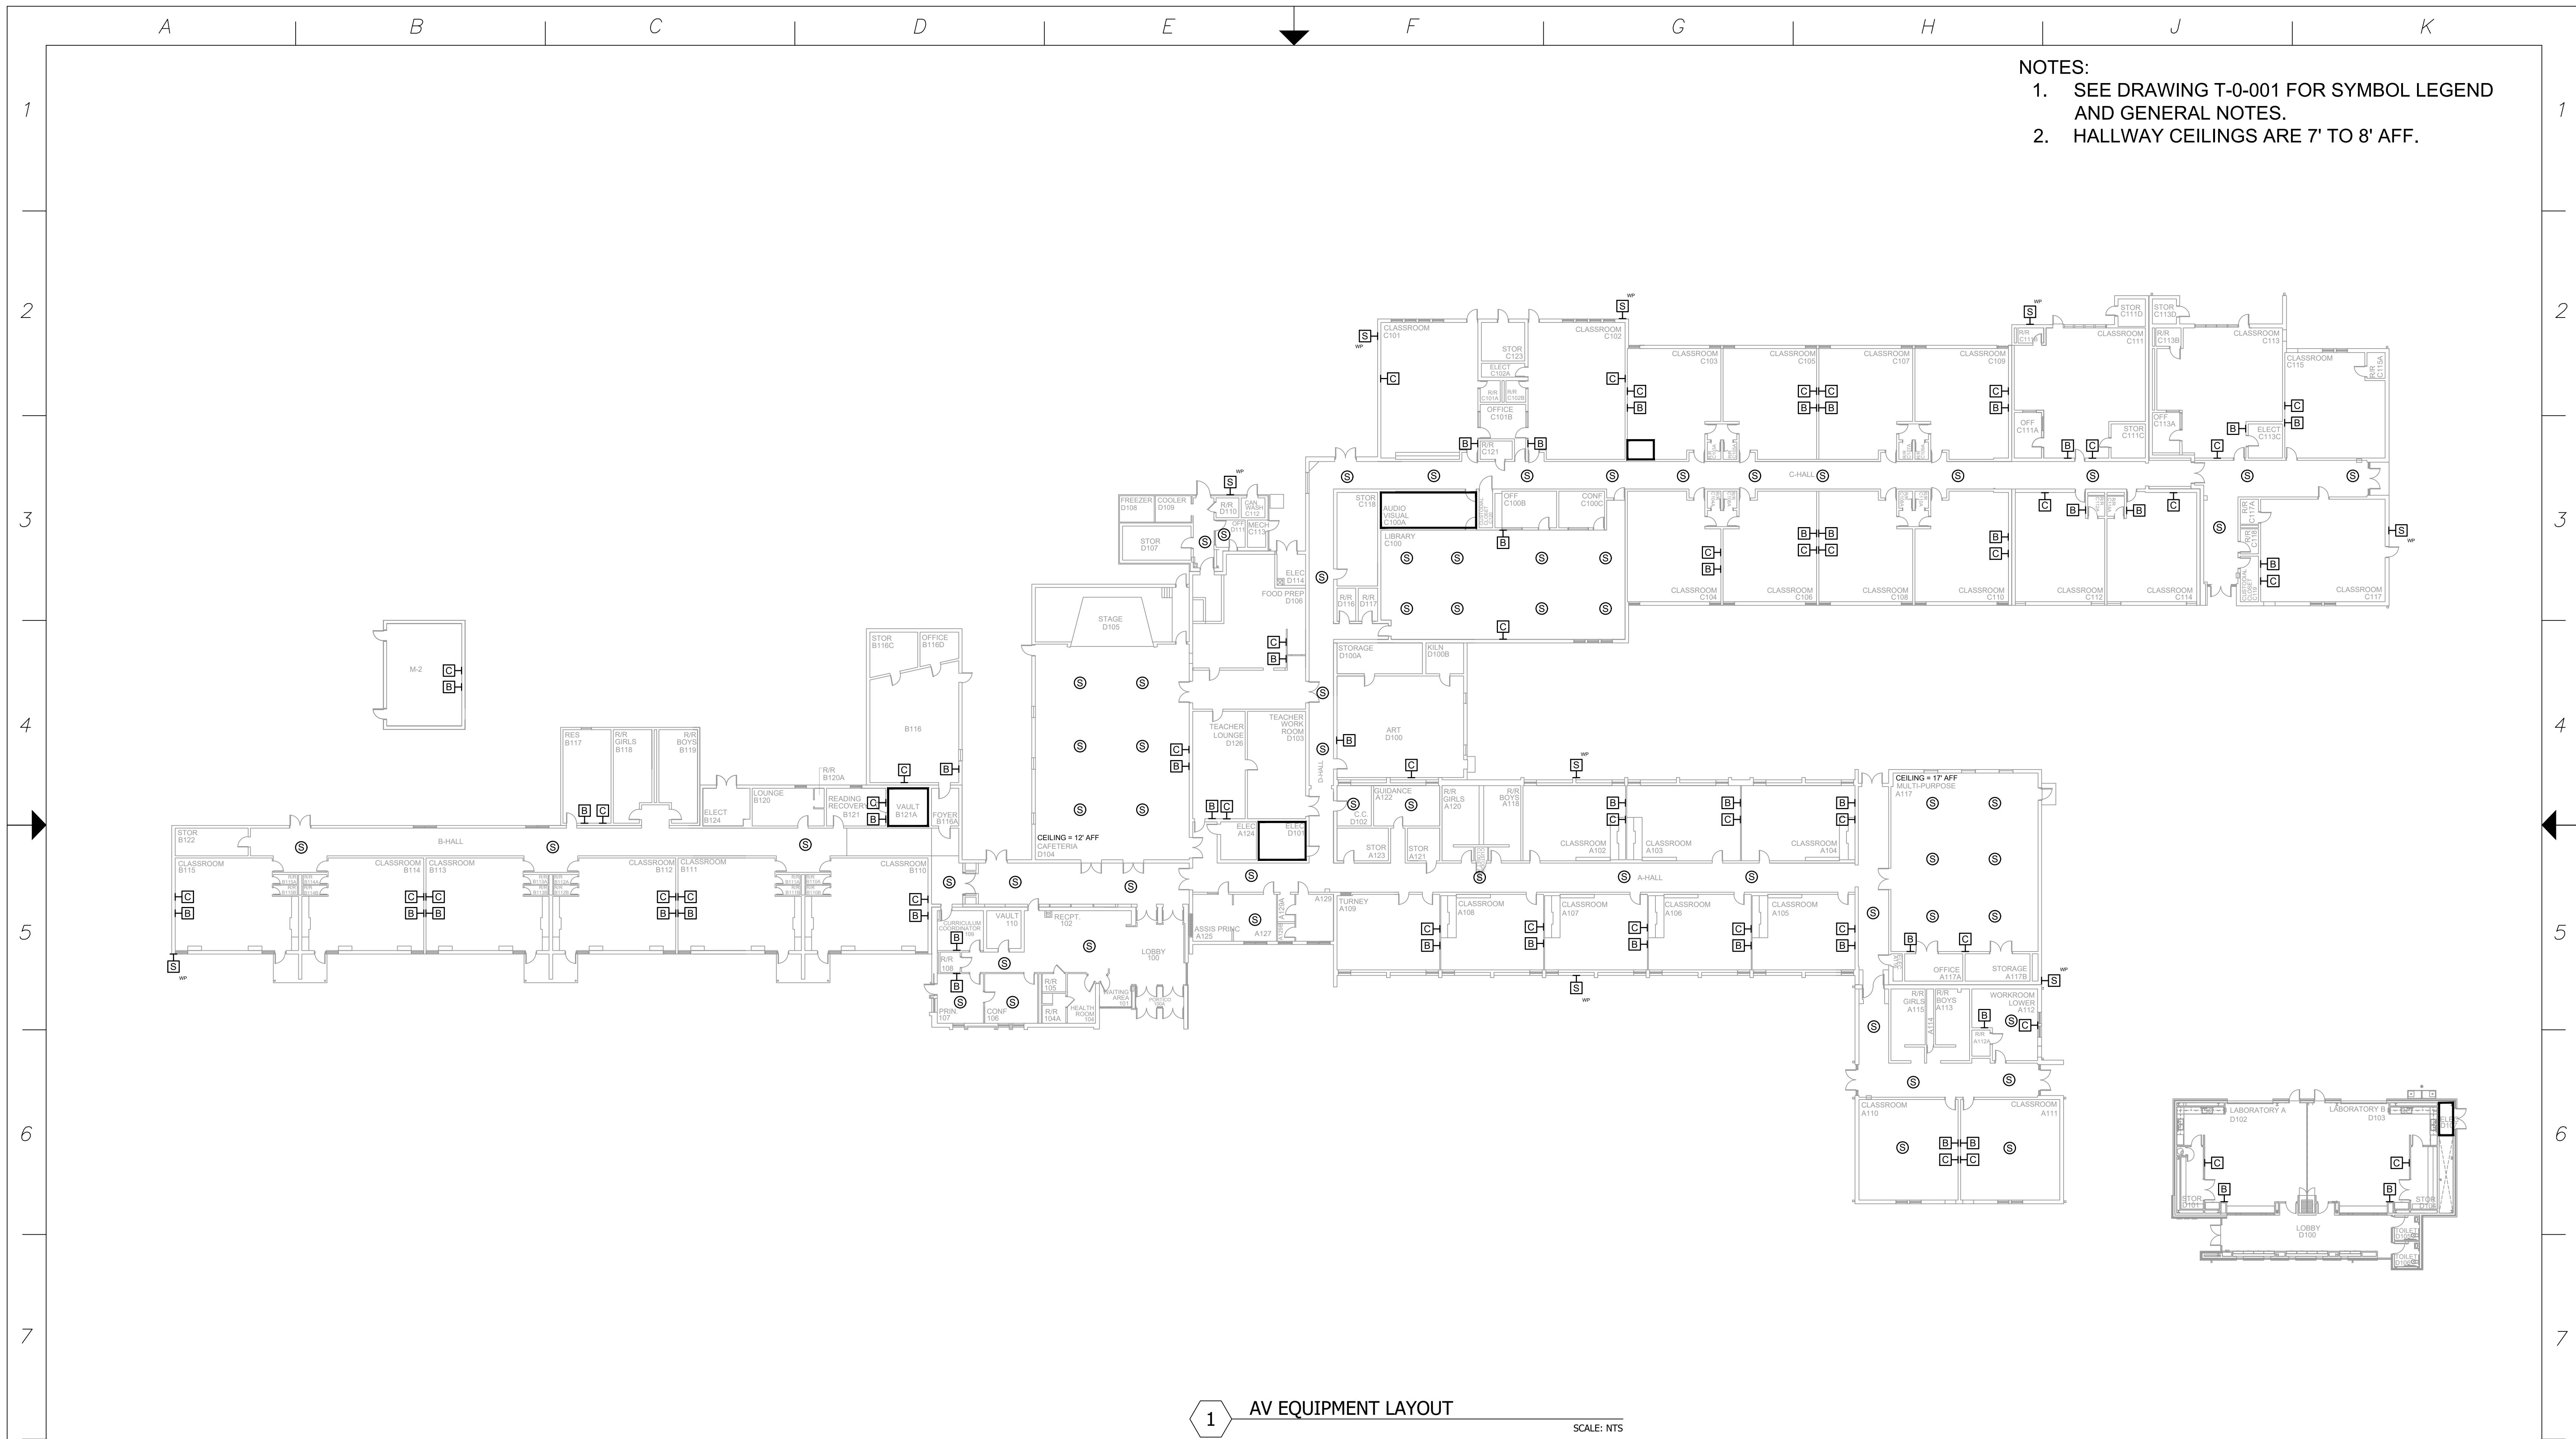

NetPlanner SYSTEMS, INC.[®]

Your Pathway to Connectivity			
Atlanta, GA	770-662-5482	Augusta, GA	706-364-4190
Raleigh, NC	919-290-8010	Columbus, GA	706-571-9090
Toll Free	800-795-1975	Savannah, GA	912-748-8960

CLIENT LOGO

PROJECT INFO


ROCK HILL SCHOOLS ROCK HILL, SC

SHEET INFO

INTERCOM & NOTIFICATIONS

OAKDALE ELEMENTARY - NEW DEVICES

REVISIONS			ENGINEER APPROVAL	ENGINEER WM	DRAWING NAME
REV.	DESCRIPTION	DATE			TA-1-22-101N
				CAD	PROJECT NUMBER
				AK	AR20245
				PROJECT MANAGER	APPROVED DRAWING DATE
				SD	07-23-2021
					RELEASE NUMBER
					1

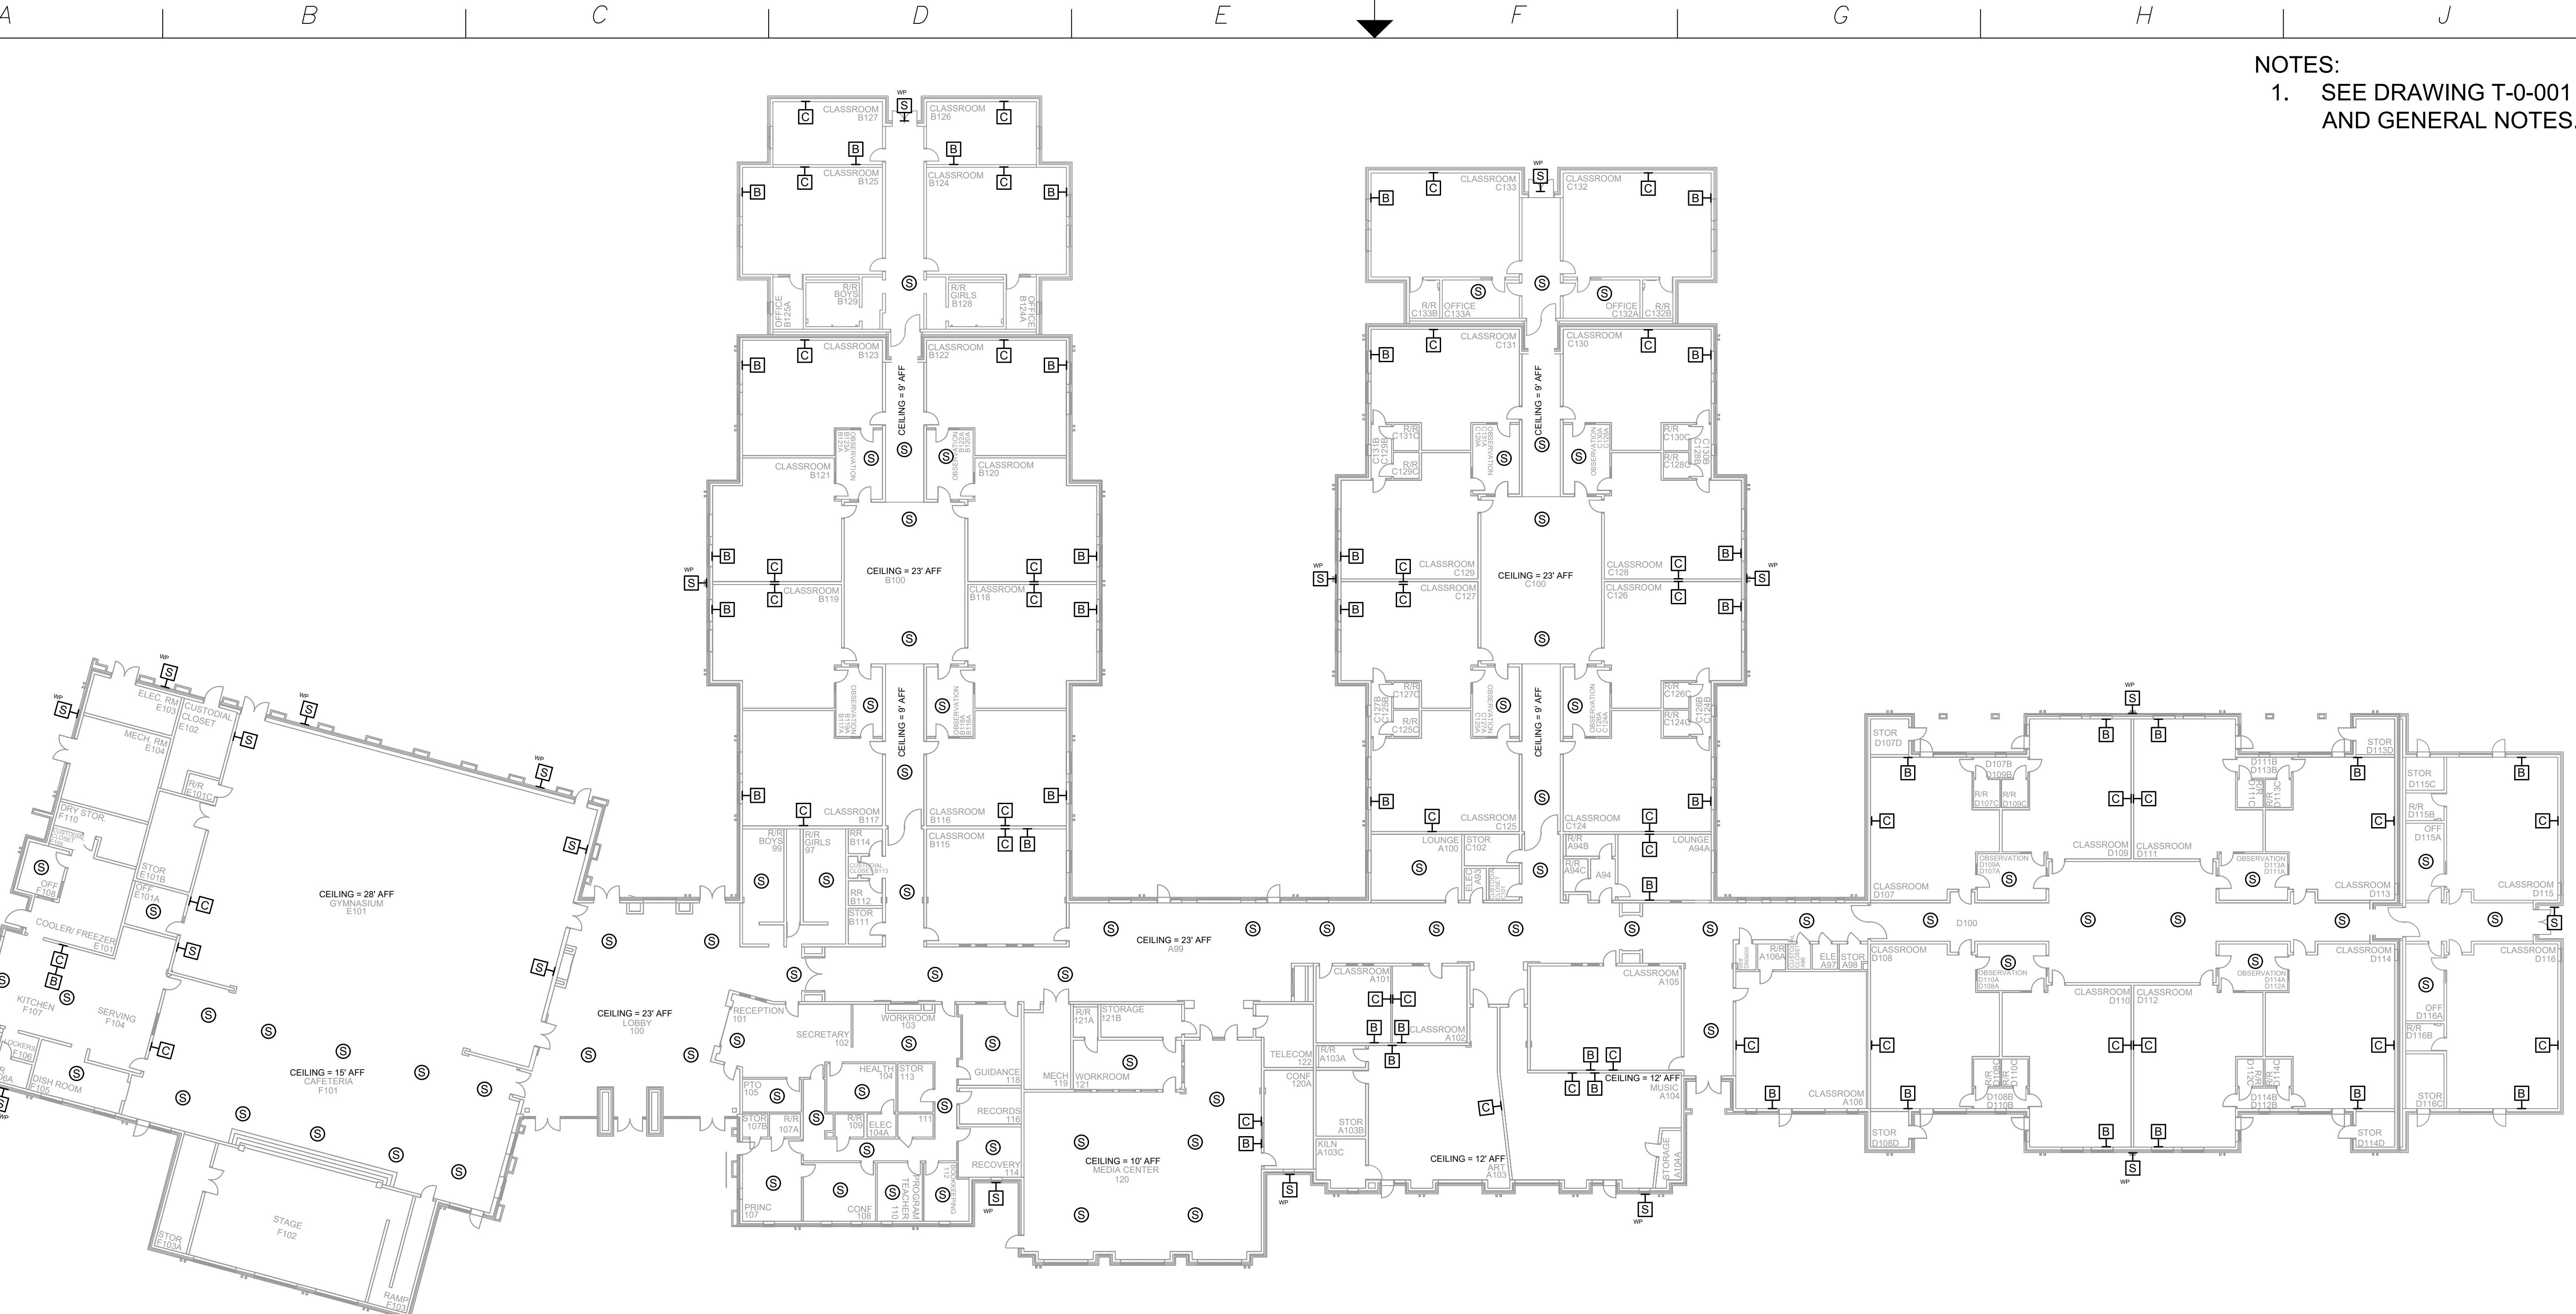

NOTES:

1. SEE DRAWING T-0-001 FOR SYMBOL LEGEND AND GENERAL NOTES.






SCALE: NTC

 NetPlanner SYSTEMS, INC. [®] <i>Your Pathway to Connectivity</i> Atlanta, GA 770-662-5482 Augusta, GA 706-364-4190 Raleigh, NC 919-290-8010 Columbus, GA 706-571-9090 Toll Free 800-795-1975 Savannah, GA 912-748-8960 www.netplanner.com		CLIENT LOGO 	PROJECT INFO SHEET INFO REVISIONS REV. DESCRIPTION DATE		ENGINEER APPROVAL WM CAD AK PROJECT MANAGER SD	DRAWING NAME TA-1-23-101N PROJECT NUMBER AR20245 APPROVED DRAWING DATE 07-23-2021 RELEASE NUMBER 1
ROCK HILL SCHOOLS ROCK HILL, SC OLD POINTE ELEMENTARY - NEW DEVICES						

A B C D E F G H J K

NOTES:
1. SEE DRAWING T-0-001 FOR SYMBOL LEGEND
AND GENERAL NOTES.

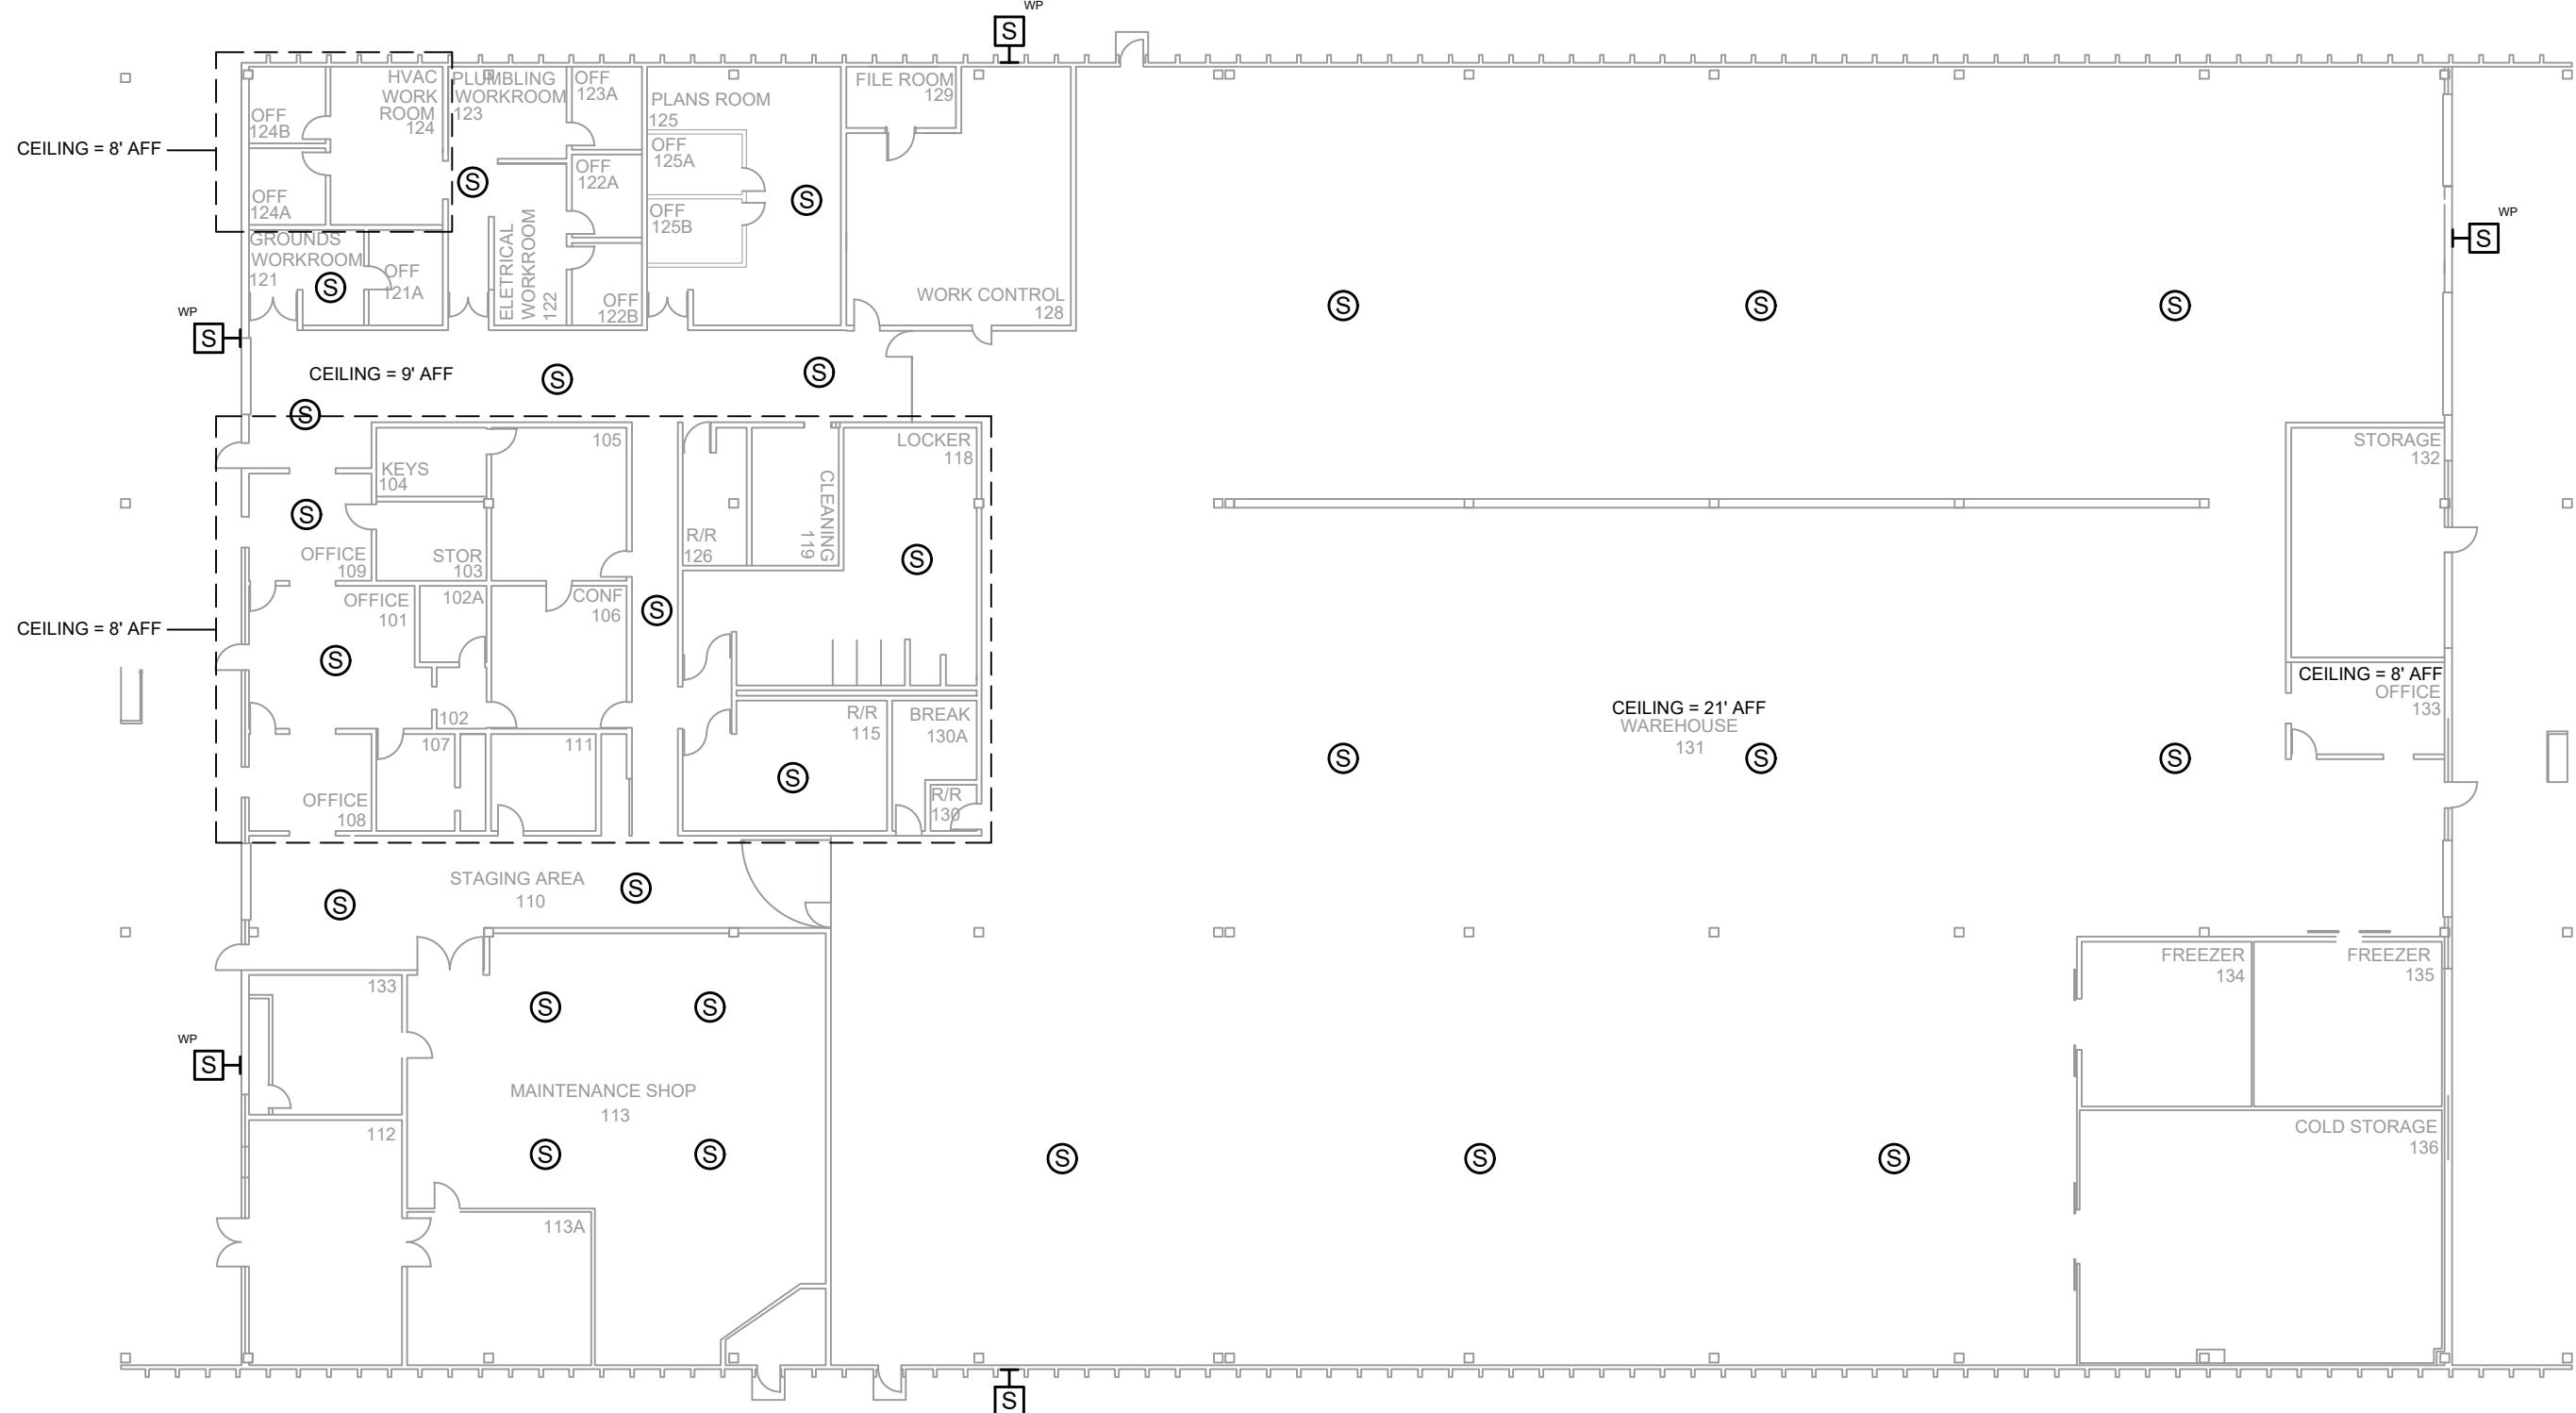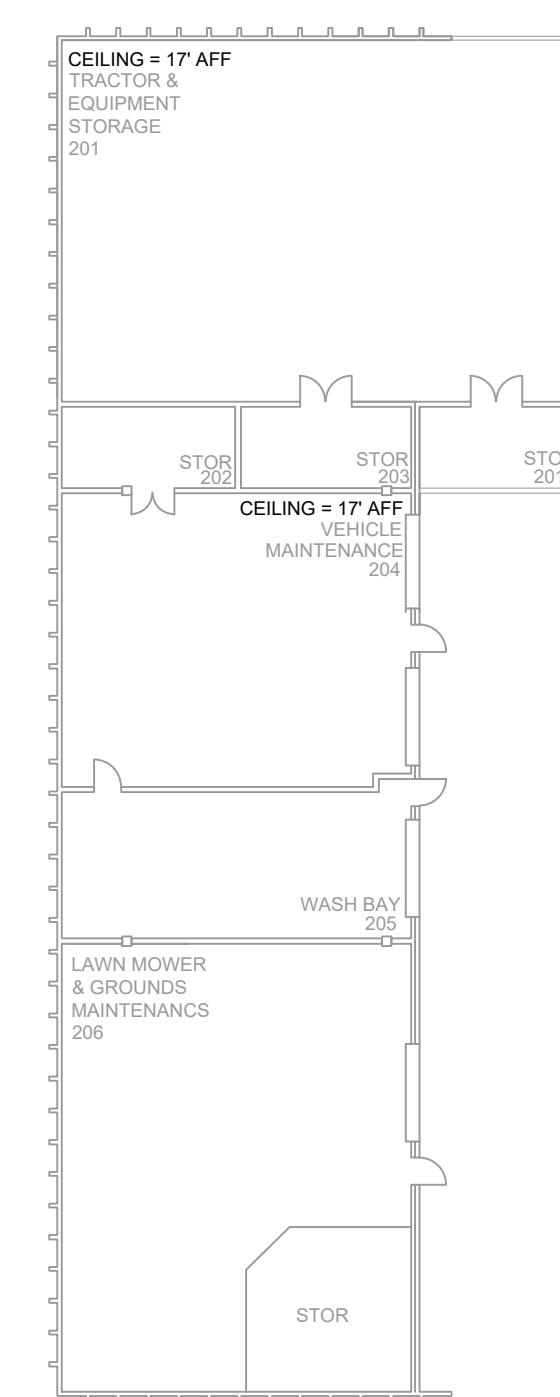
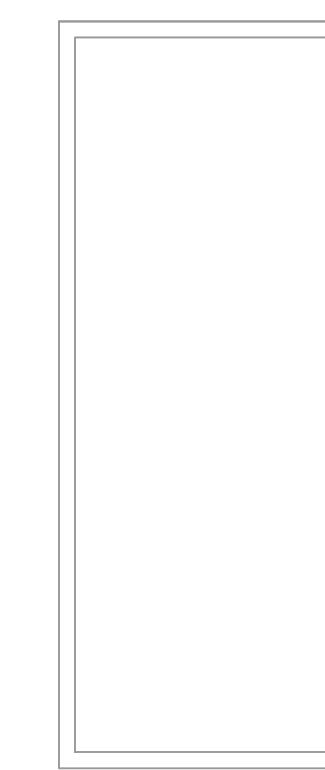


AV EQUIPMENT LAYOUT

SCALE: NTS

REV.	DESCRIPTION	DATE	REVISIONS	
			ENGINEER APPROVAL	ENGINEER WM
			CAD AK	PROJECT NUMBER AR20245
			PROJECT MANAGER SD	APPROVED DRAWING DATE 07-23-2021
				RELEASE NUMBER 1

A B C D E F G H J K

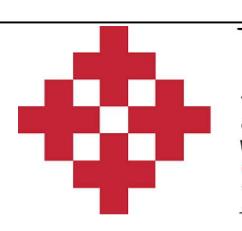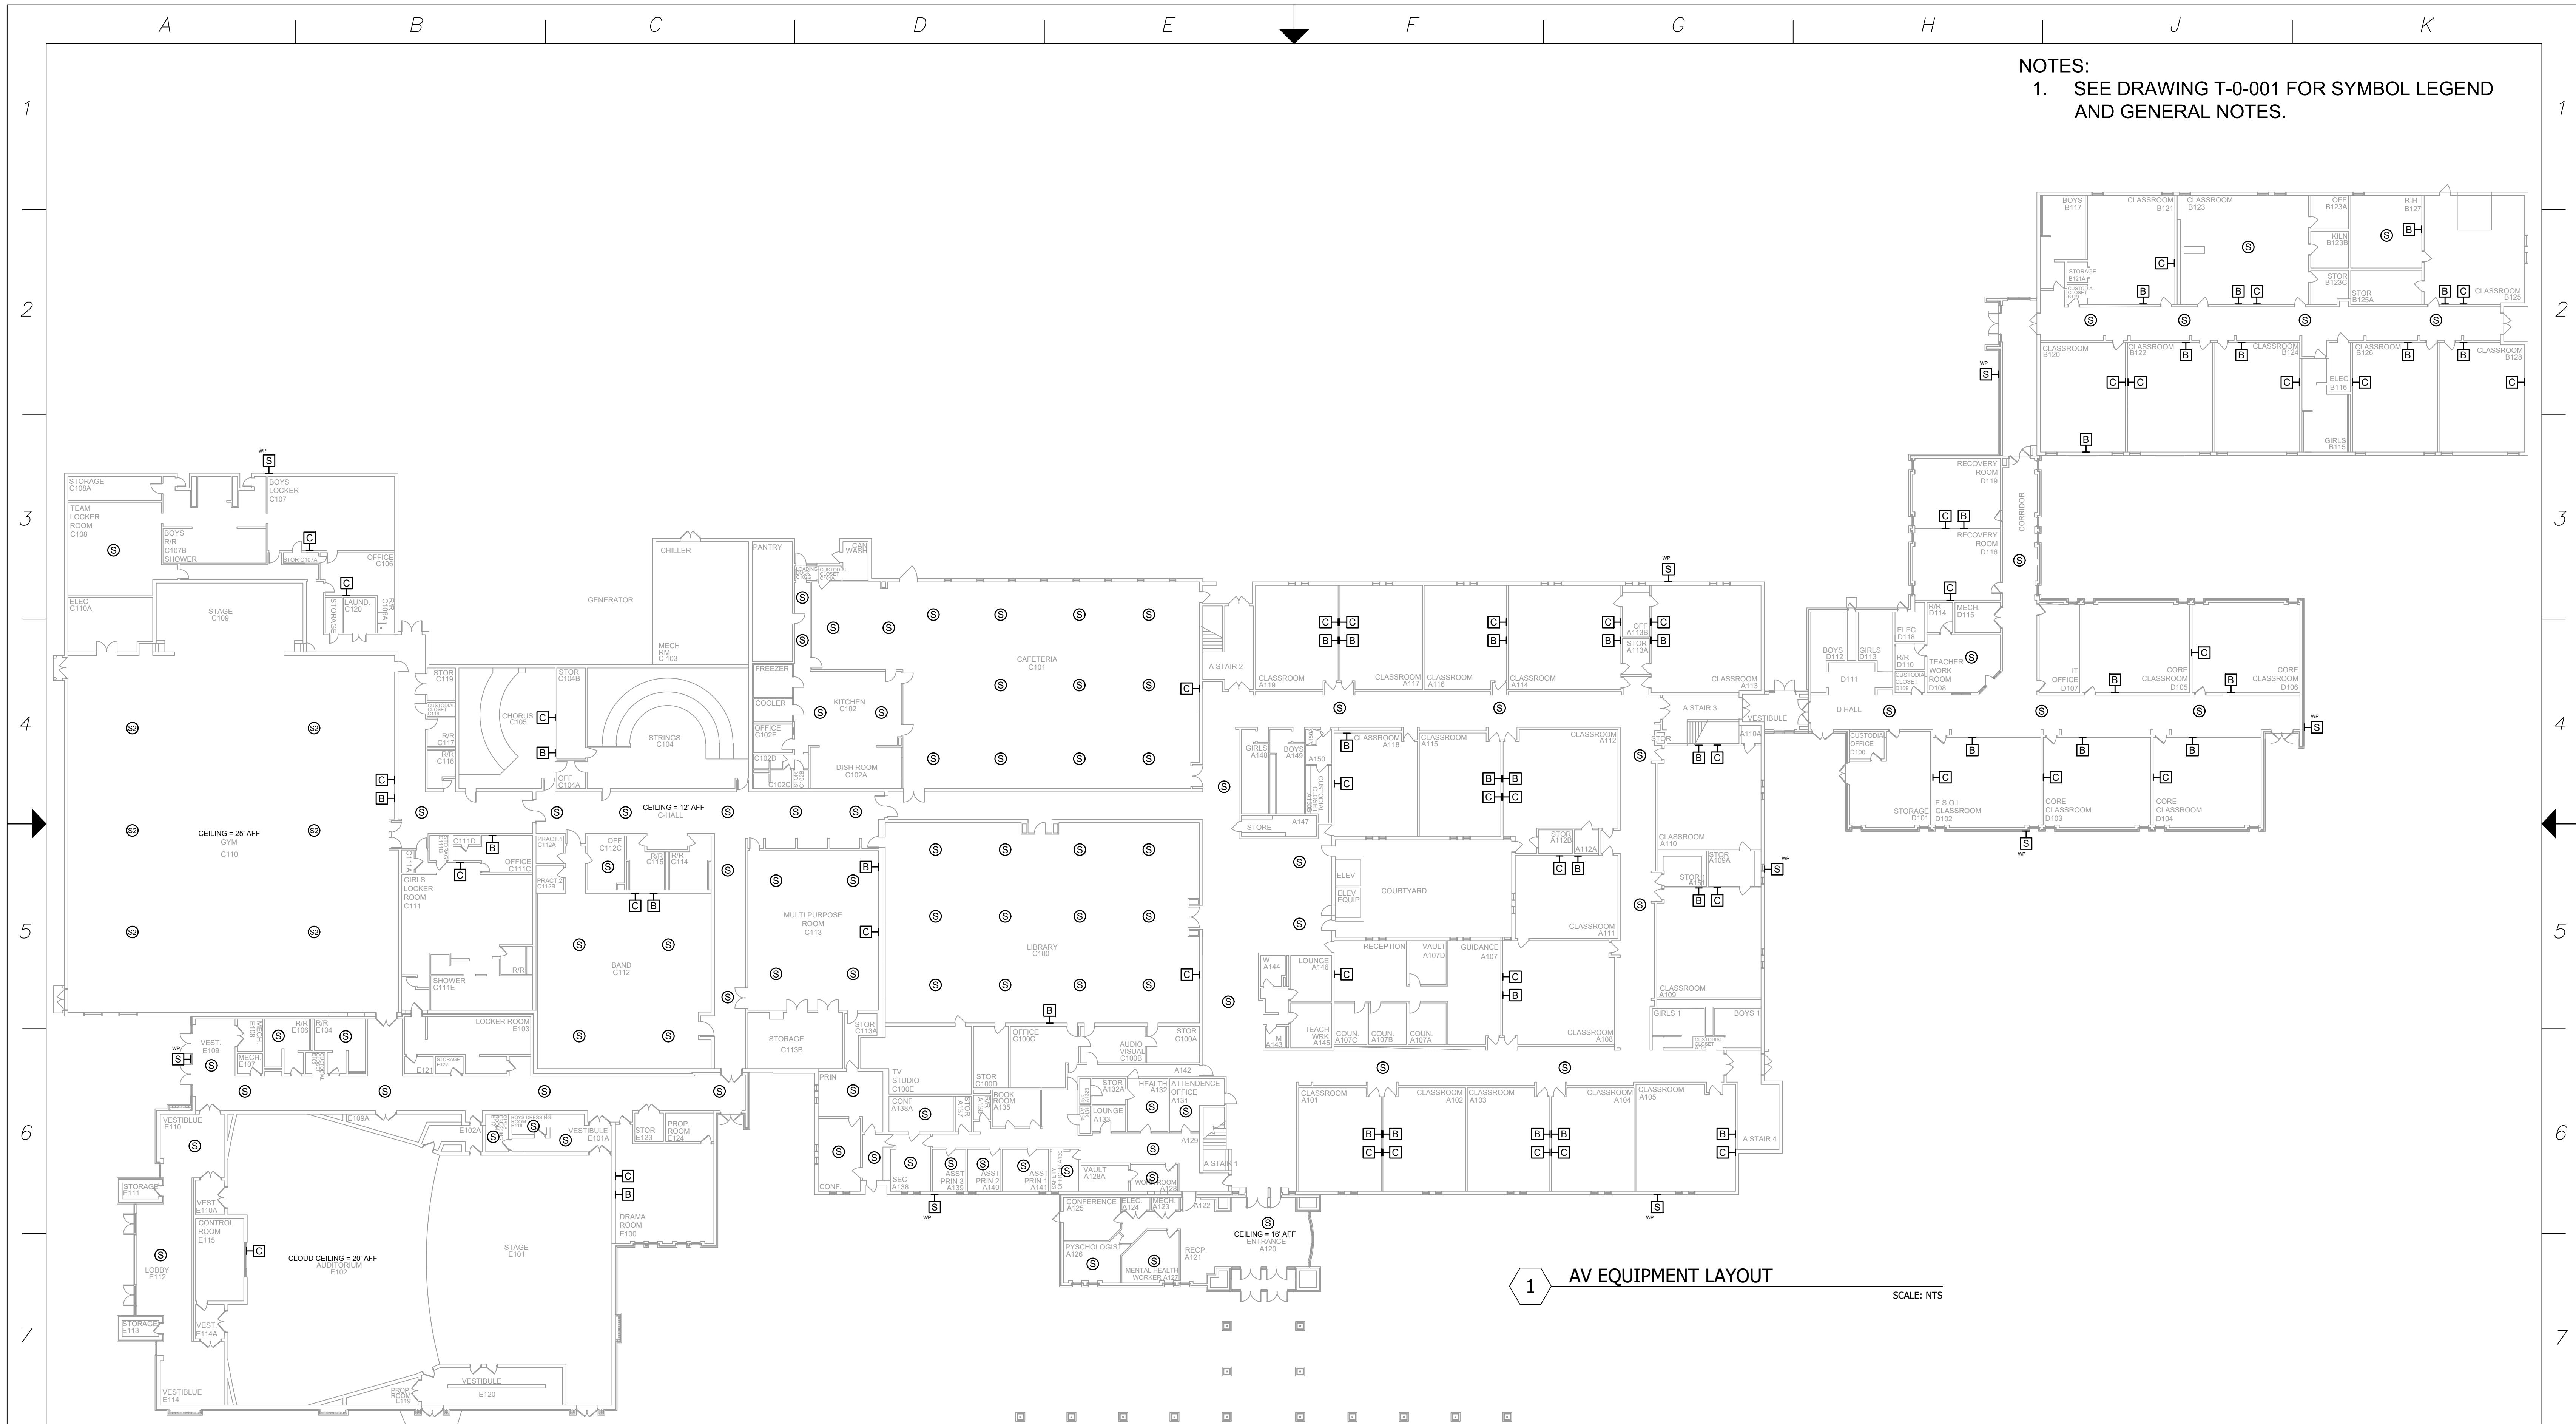

NetPlanner SYSTEMS, INC.[®]

Your Pathway to Connectivity

Atlanta, GA	770-662-5482	Augusta, GA	706-364-4
Raleigh, NC	919-290-8010	Columbus, GA	706-571-9
Toll Free	800-795-1975	Savannah, GA	912-748-8

www.netplanner.com

CLIENT LOGO

PROJECT INFO

ROCK HILL SCHOOLS ROCK HILL, SC

SHEET INFO

INTERCOM & NOTIFICATIONS


RAWLINSON ROAD MS - 1ST FLR -

NEW DEVICES

REVISIONS			ENGINEER APPROVAL	ENGINEER WM	DRAWING NAME
REV.	DESCRIPTION	DATE			TA-1-25-101N
				CAD AK	PROJECT NUMBER
					AR20245
				PROJECT MANAGER SD	APPROVED DRAWING DATE
					07-23-2021
					RELEASE NUMBER
					1

A B C D E F G H J K

NOTES:
1. SEE DRAWING T-0-001 FOR SYMBOL LEGEND
AND GENERAL NOTES.

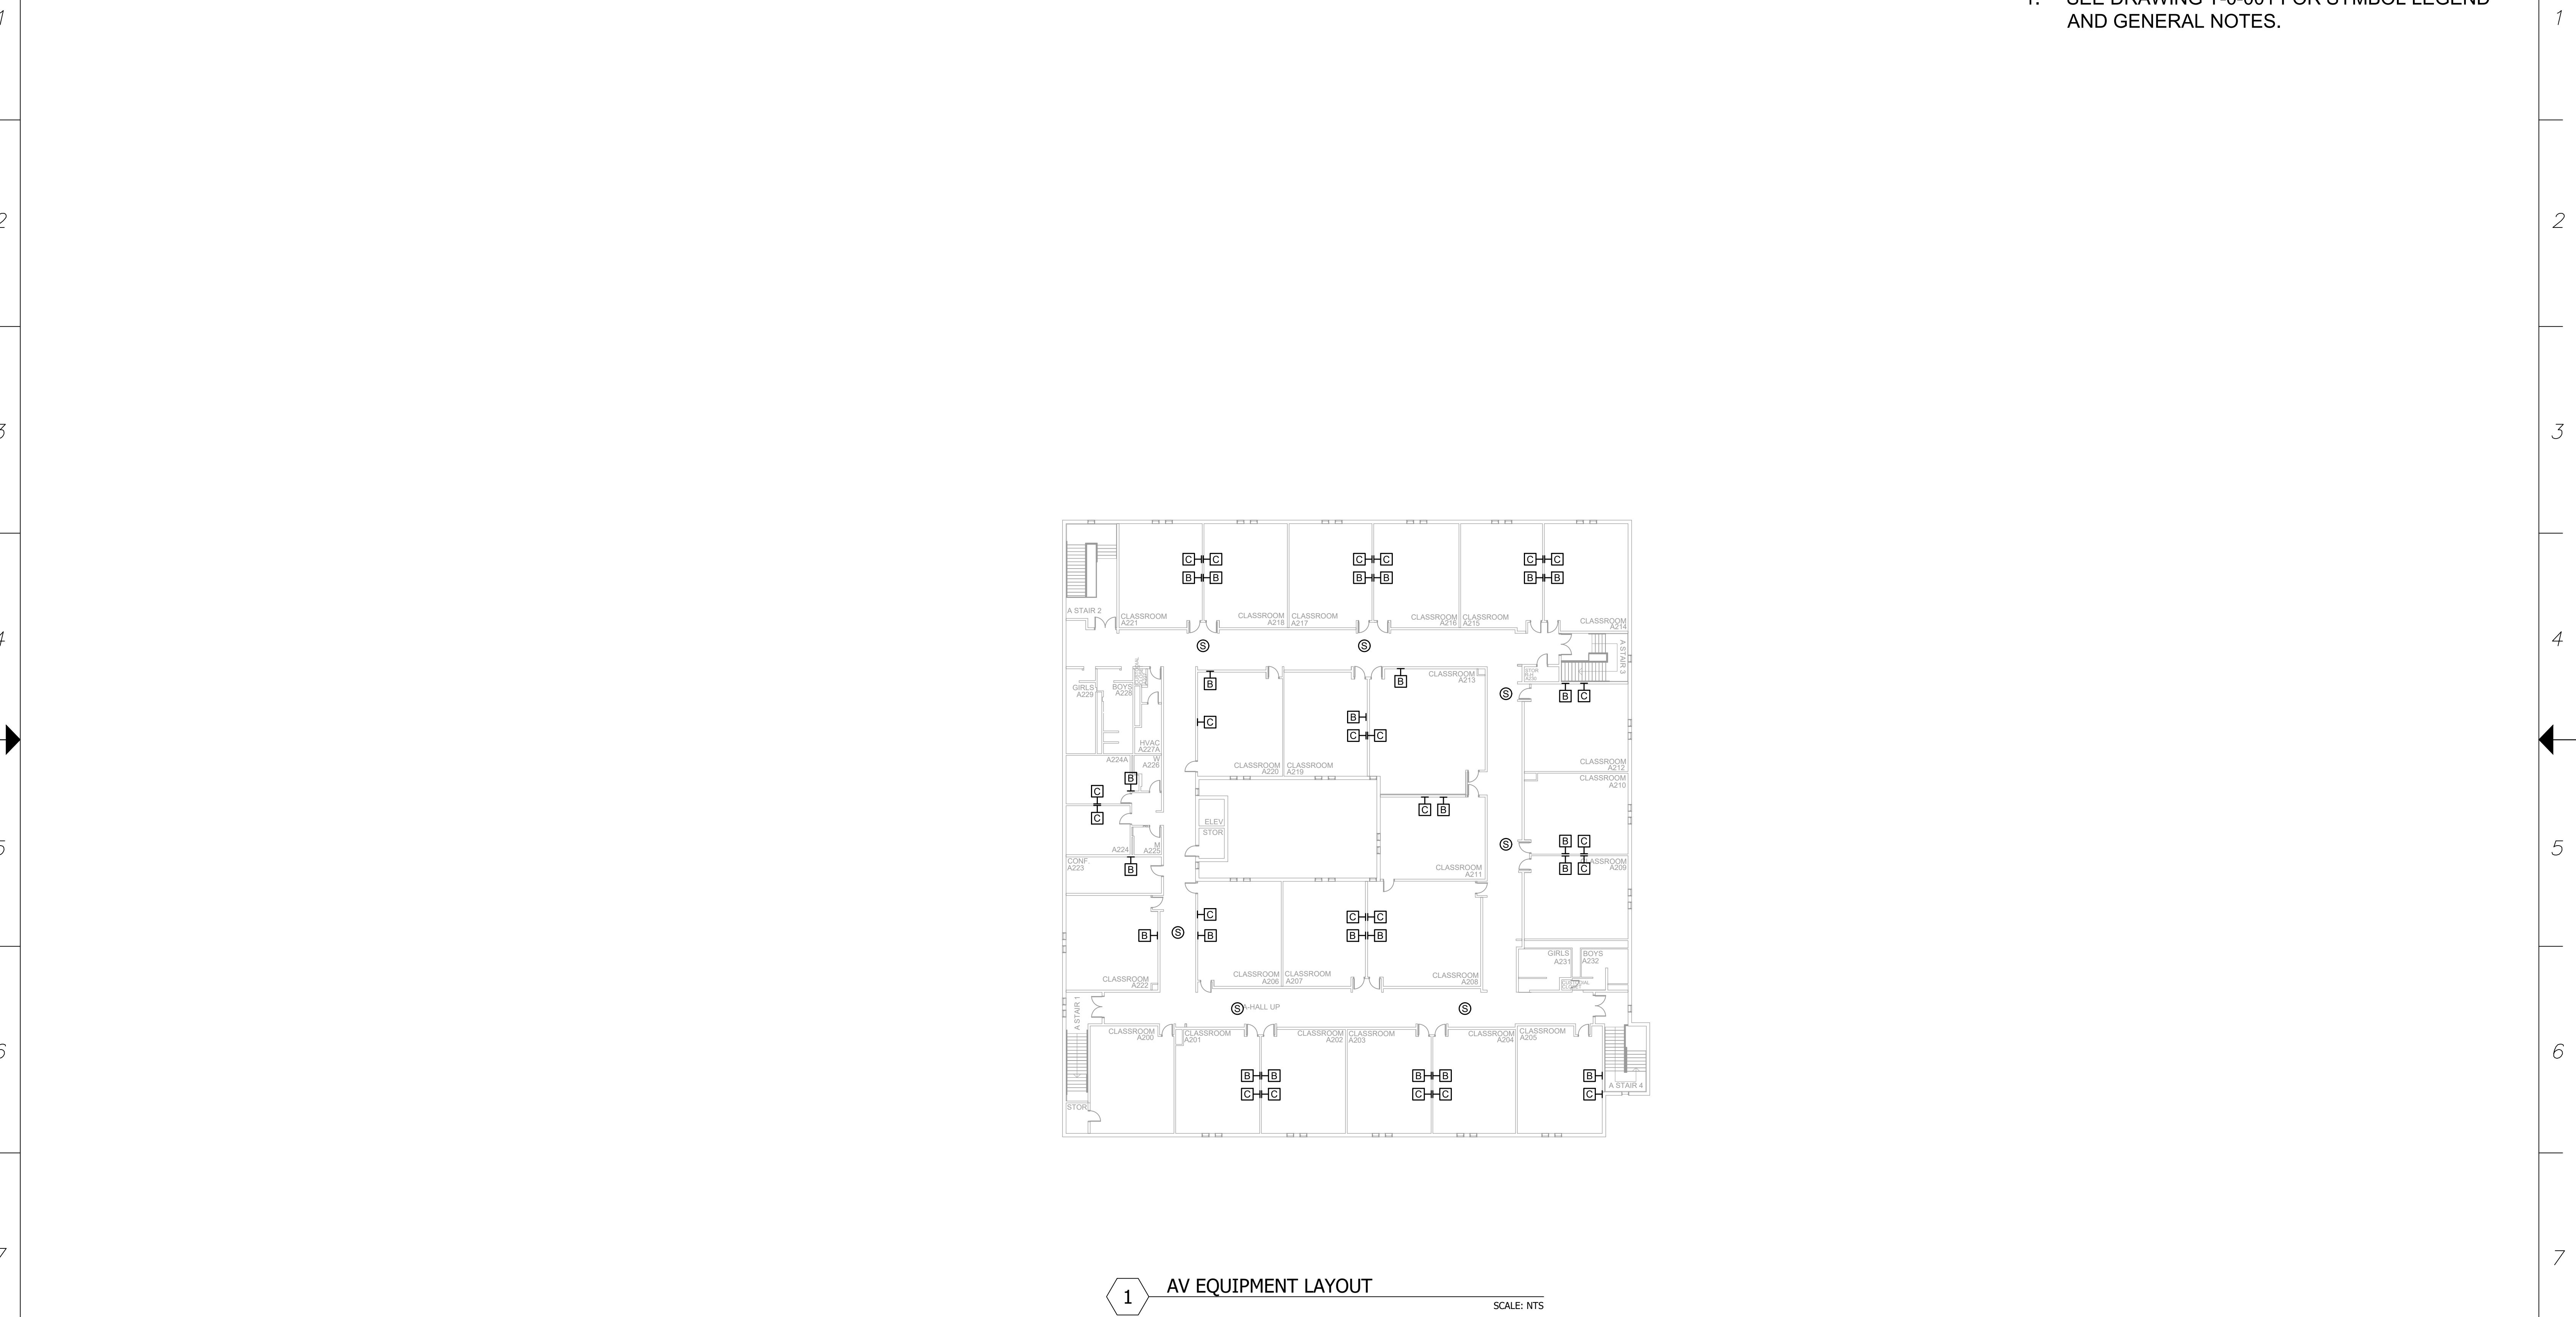


REV.	DESCRIPTION	DATE	REVISIONS	
			ENGINEER APPROVAL	ENGINEER DRAWING NAME
			WM	TA-1-25-201N
			CAD	PROJECT NUMBER
			AK	AR20245
			PROJECT MANAGER	APPROVED DRAWING DATE
			SD	RELEASE NUMBER
				07-23-2021
				1

A B C D E F G H J K

A | *B* | *C* | *D* | *E* | *F* | *G* | *H* | *J* | *K*


NOTES:

1. SEE DRAWING T-0-001 FOR SYMBOL LEGEND AND GENERAL NOTES.

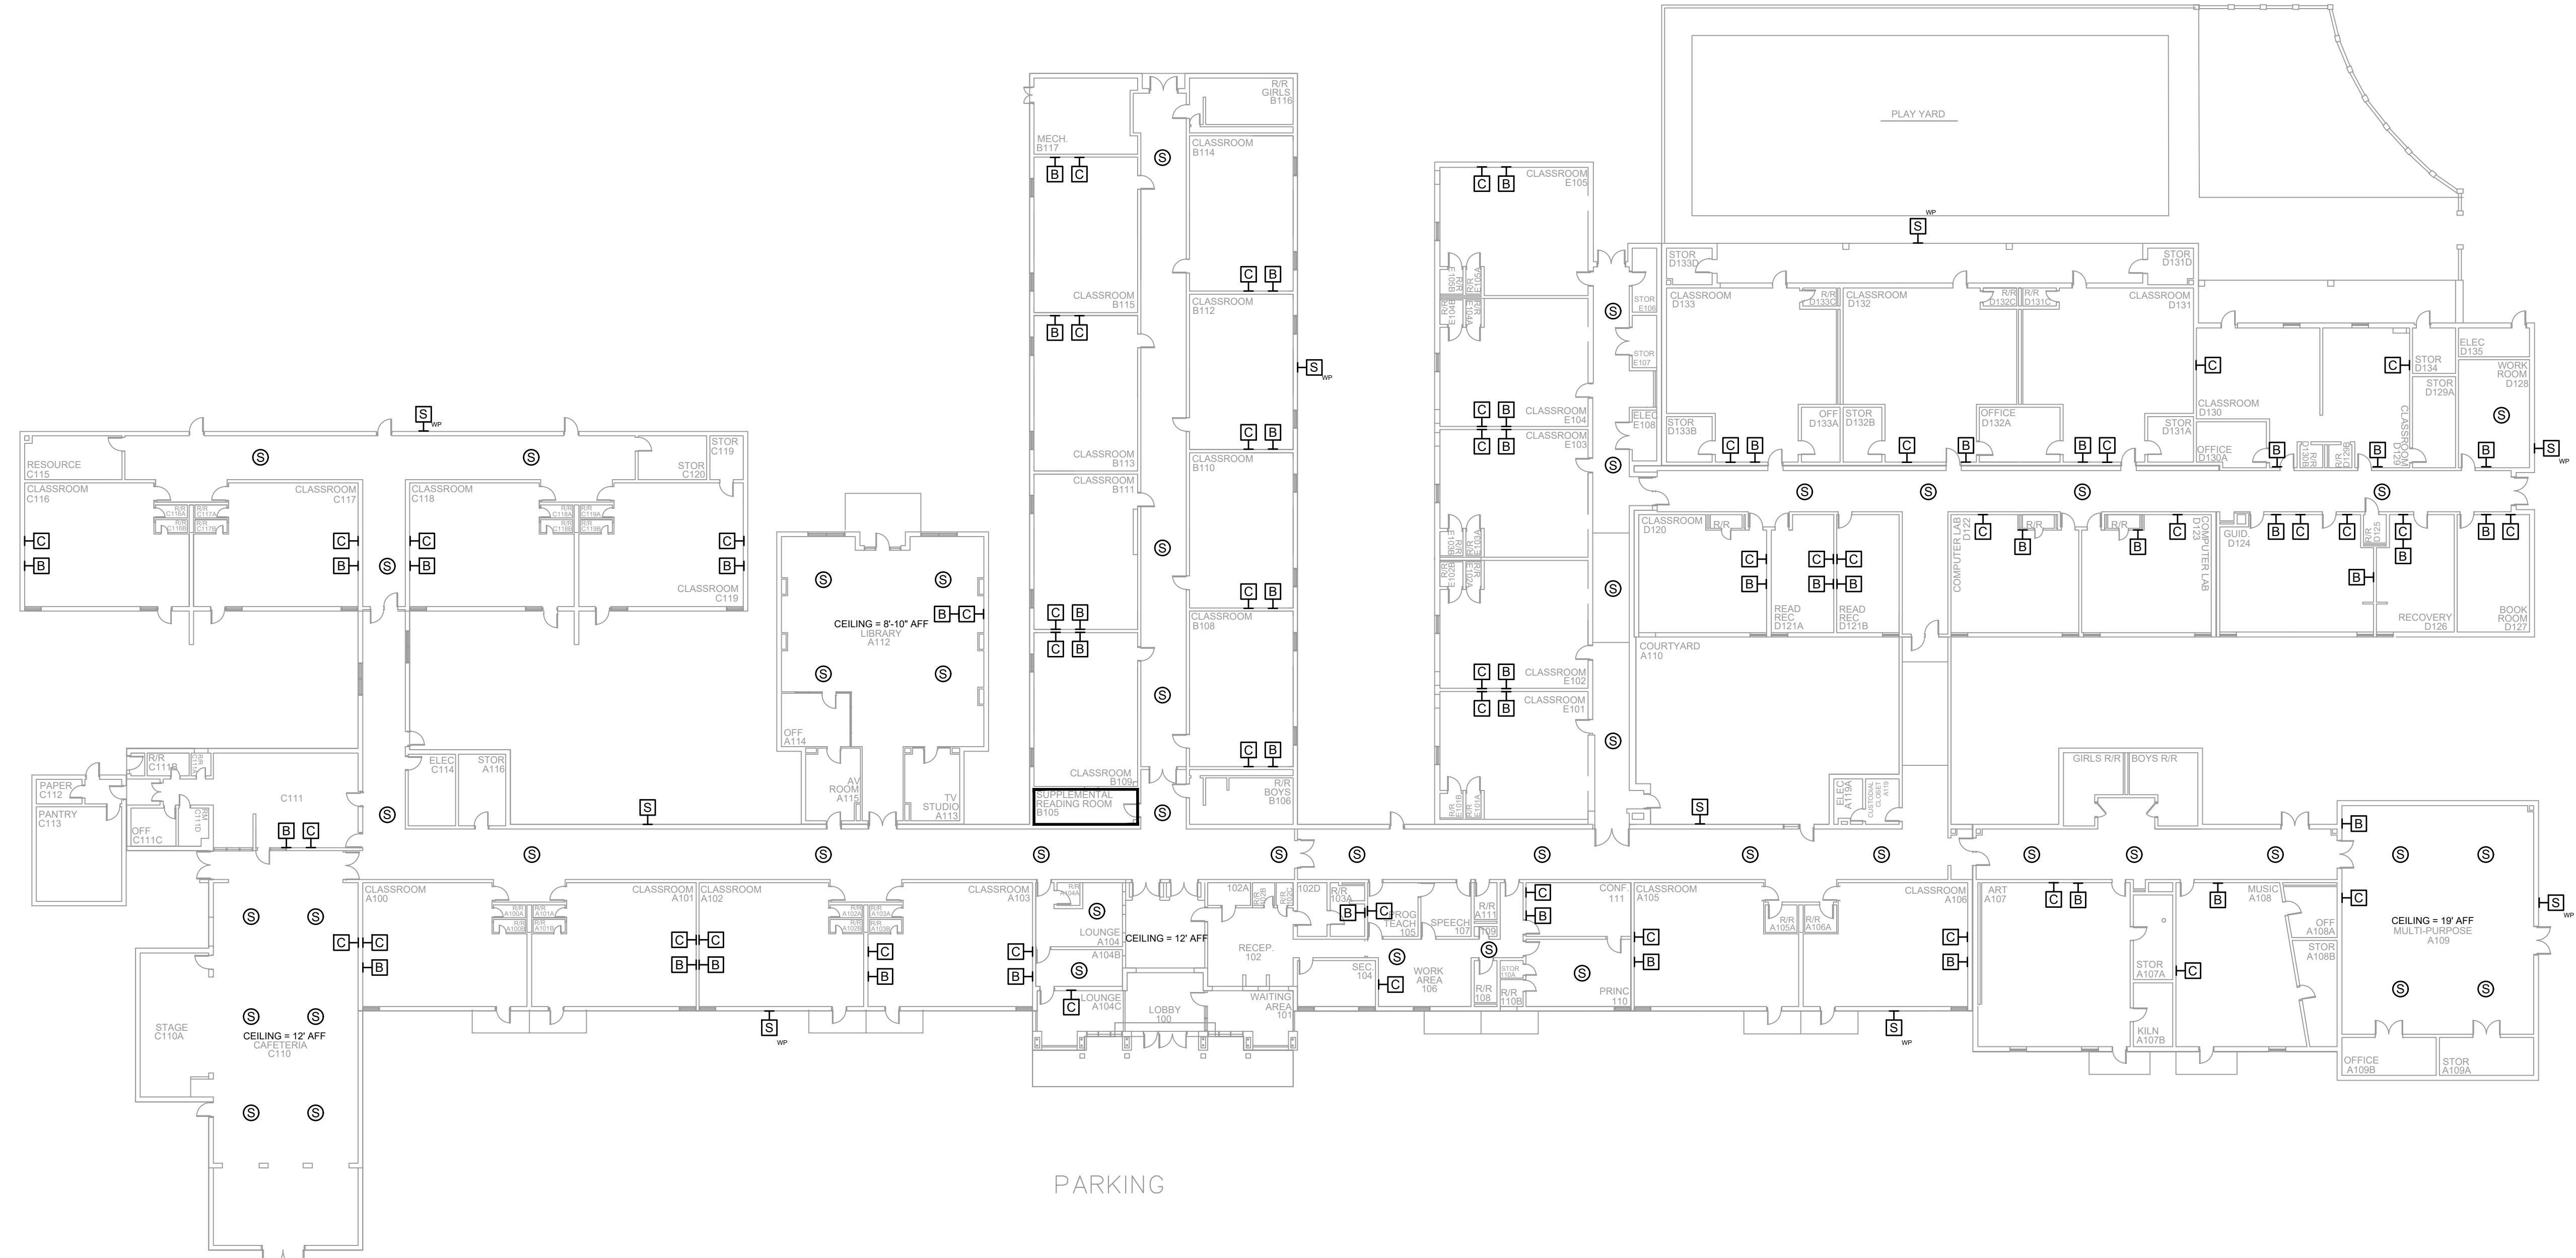

AV EQUIPMENT LAYOUT

SCALE: NTS

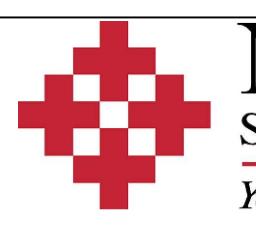

NetPlanner

S Y S T E M S, I N C.®

Your Pathway to Connectivity

662-5482	Augusta, GA	706-364-
90-8010	Columbus, GA	706-571-
95-1975	Savannah, GA	912-748-

CLIENT LOGO



PROJECT INFO

ROCK HILL SCHOOLS


ROCK HILL, SC

SHEET INFO


REVISIONS			ENGINEER APPROVAL	ENGINEER	DRAWING NAME
REV.	DESCRIPTION	DATE		WM	TA-1-26-101N
				CAD	PROJECT NUMBER
				AK	AR20245
				PROJECT MANAGER	APPROVED DRAWING DATE
				SD	07-23-2021
					RELEASE NUMBER
					1

A B C D E F G H J K



NOTES:
 1. SEE DRAWING T-0-001 FOR SYMBOL LEGEND AND GENERAL NOTES.
 2. HALLWAY CEILINGS ARE 9' AFF.

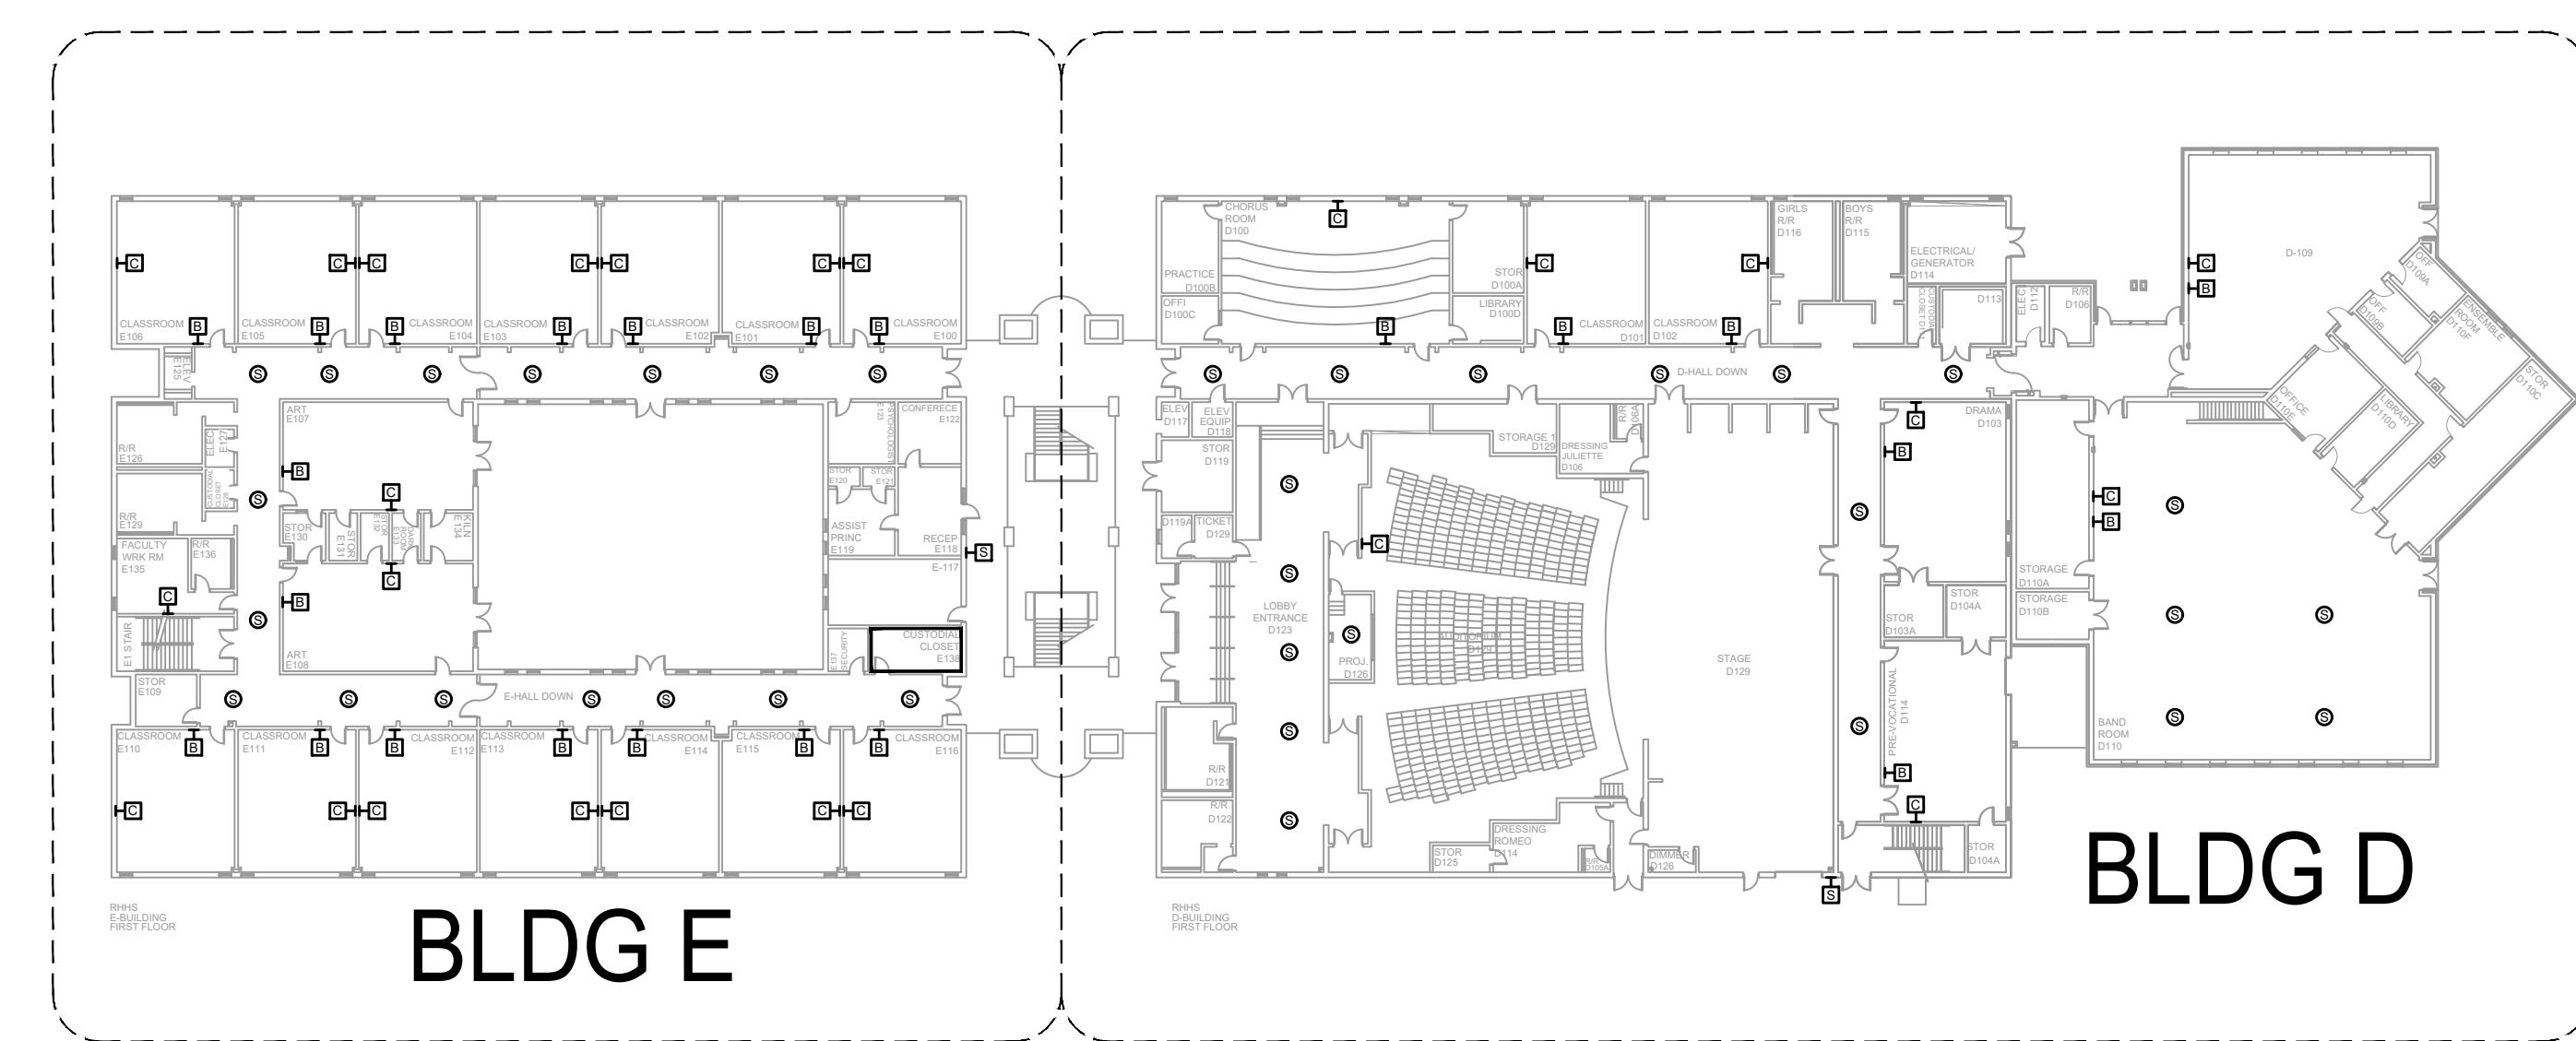

BLDG C

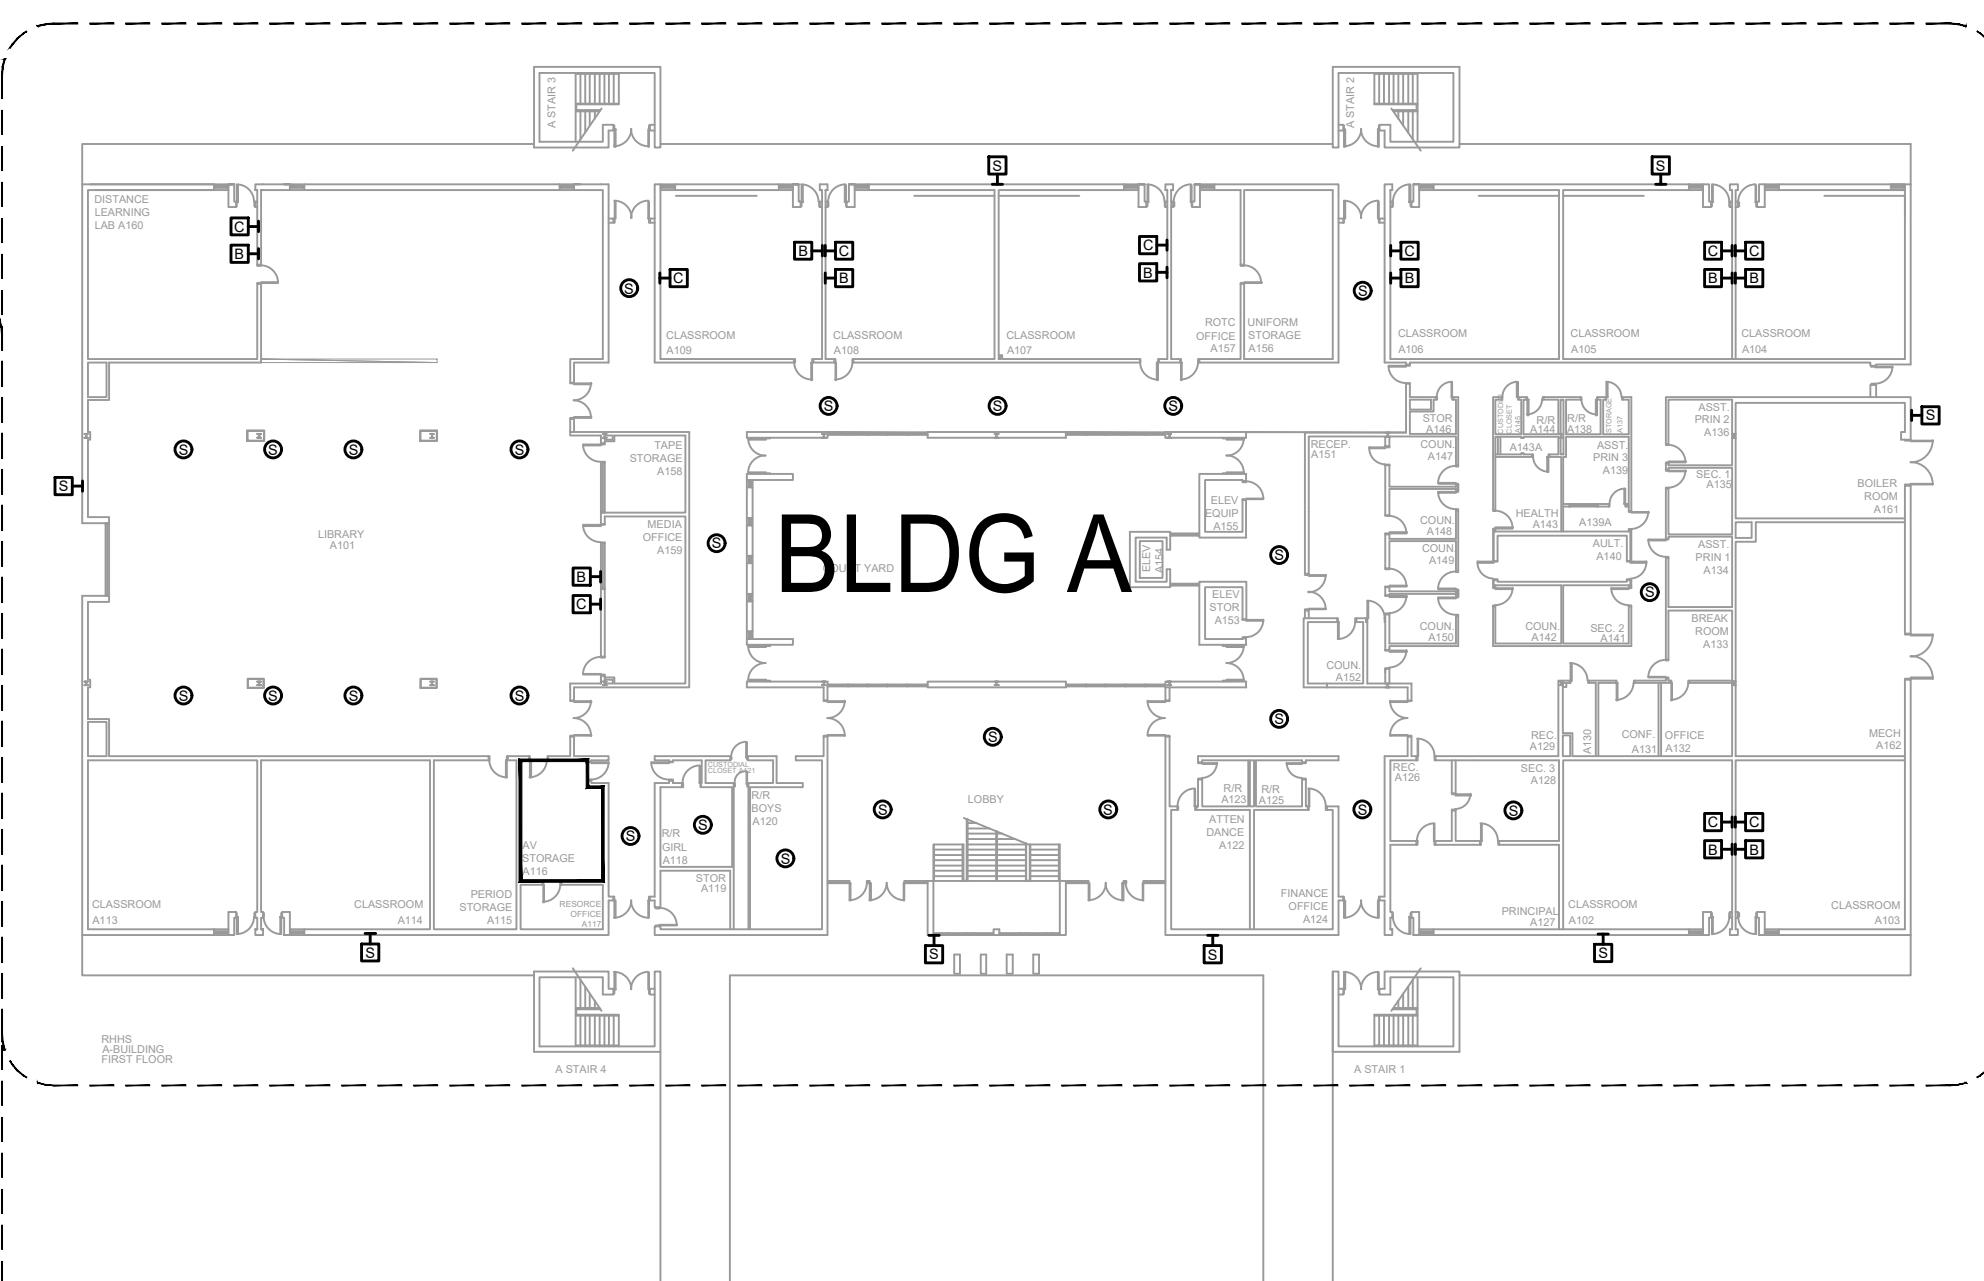

GYM

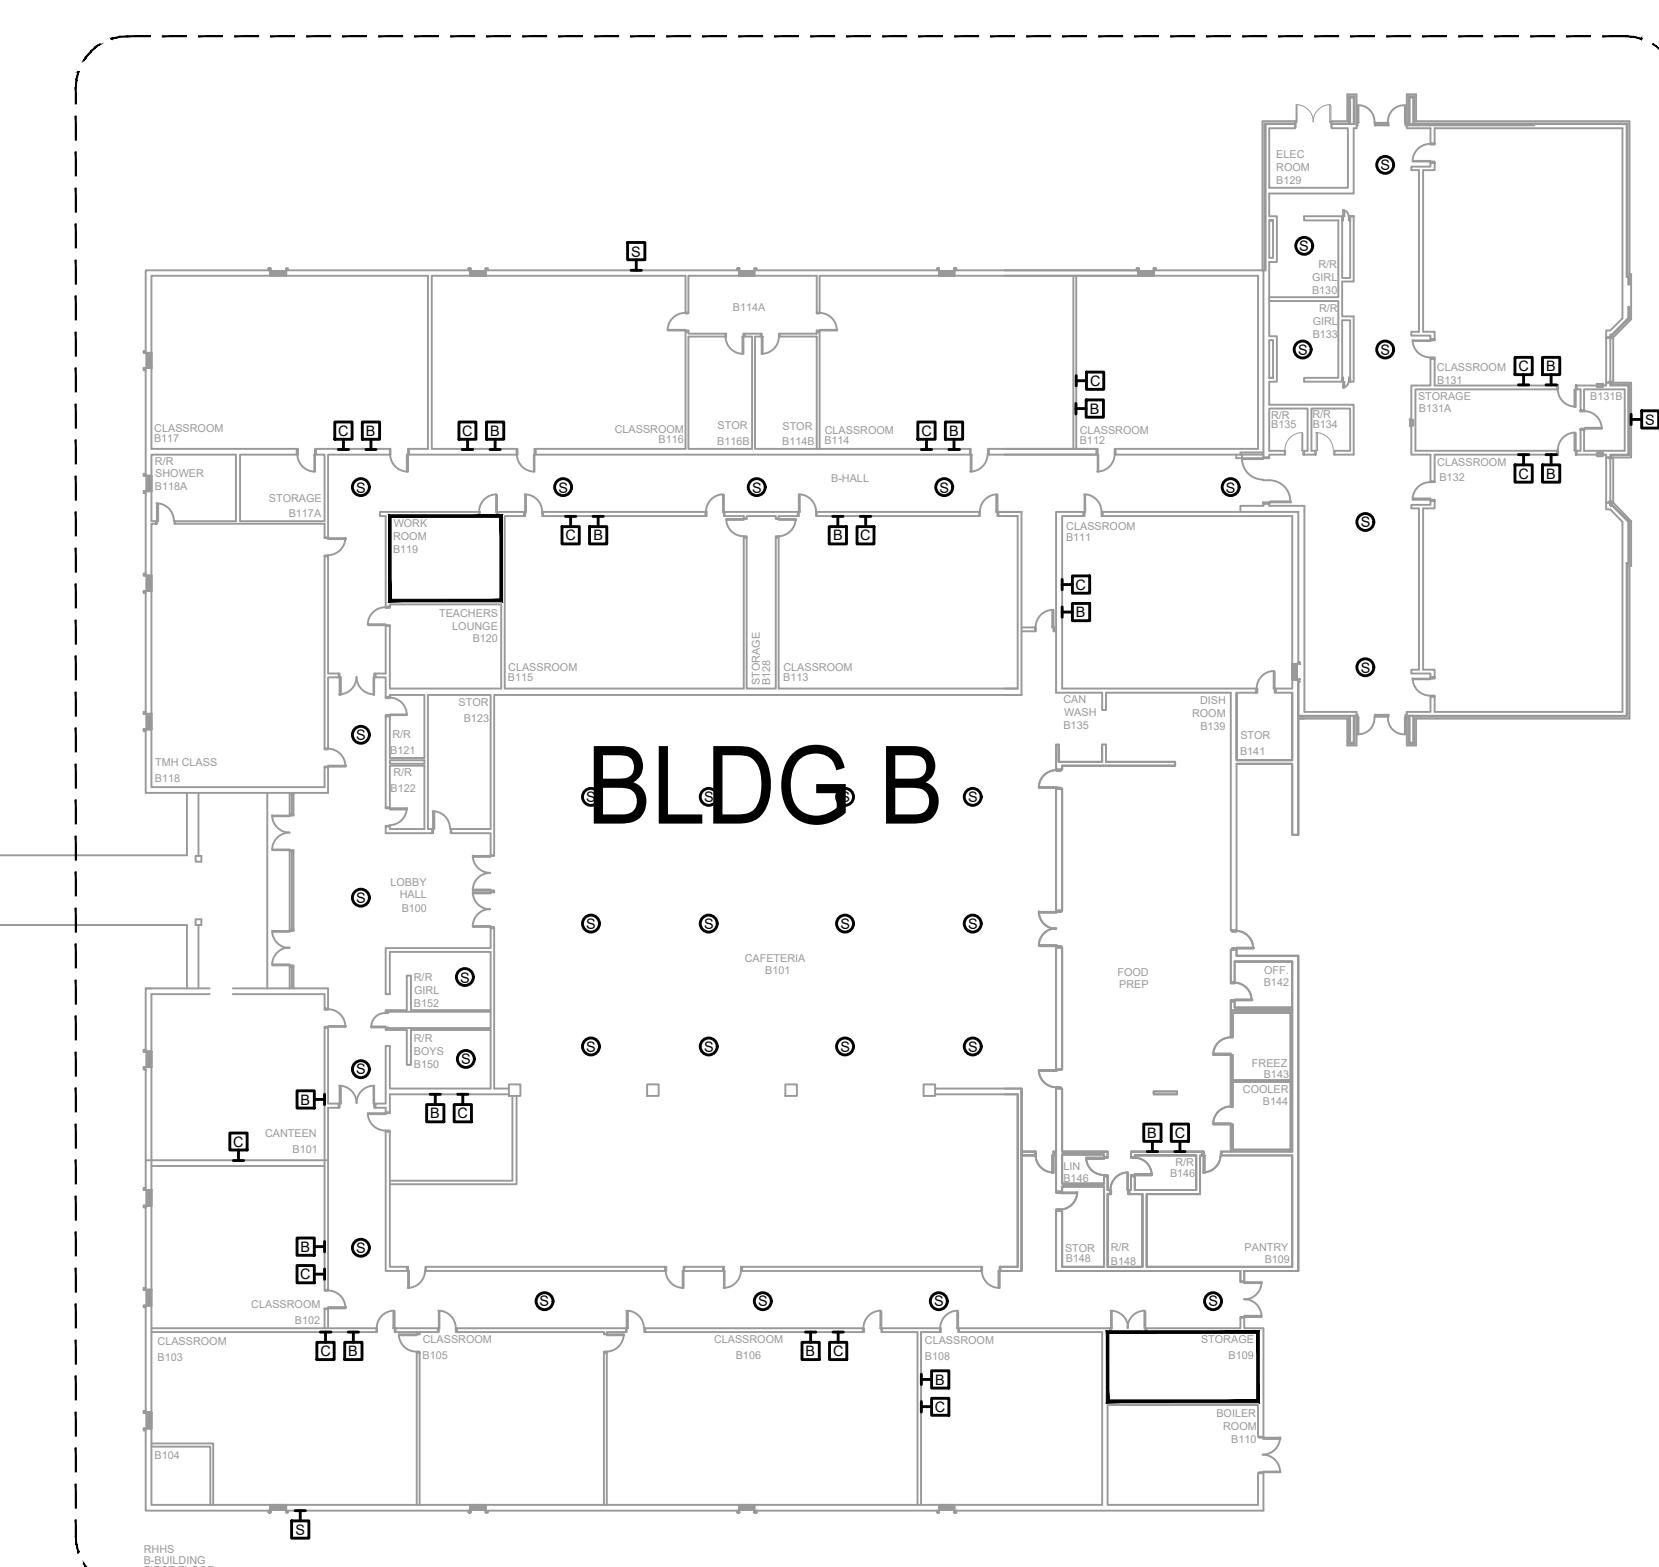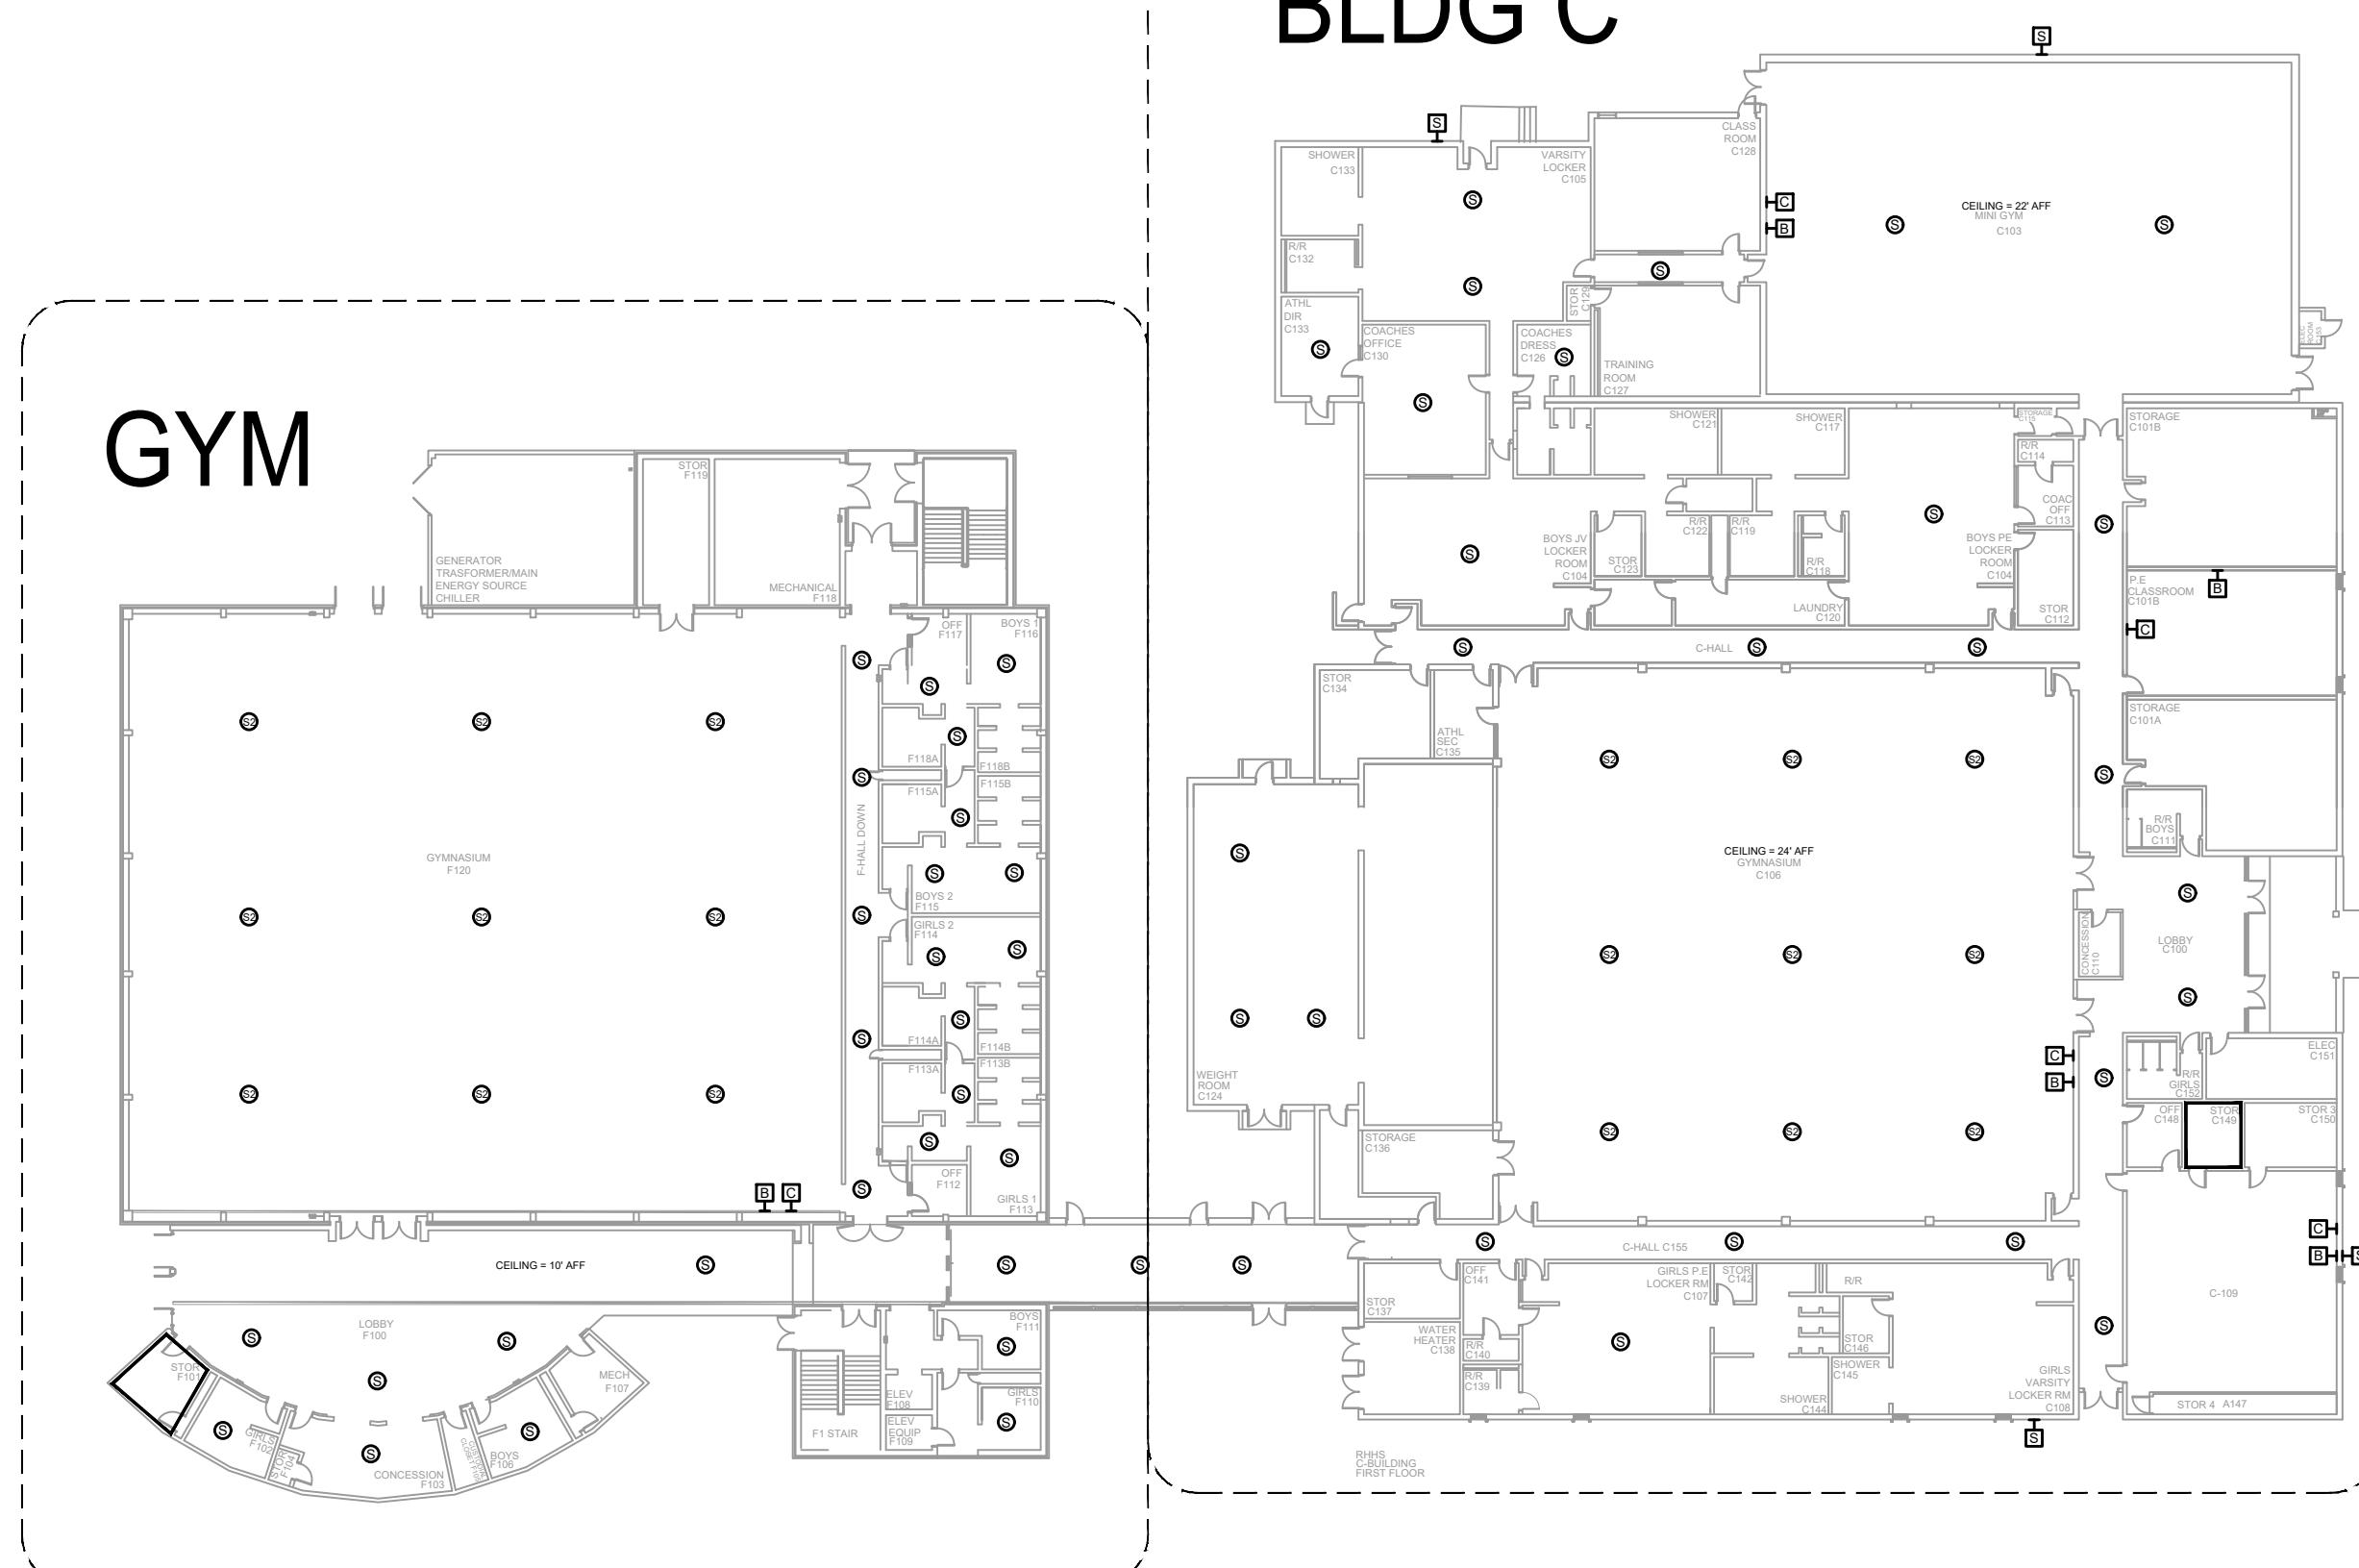


1 AV EQUIPMENT LAYOUT - OVERALL

SCALE: NTS

REV.	DESCRIPTION	DATE	REVISIONS	
			ENGINEER APPROVAL	DRAWING NAME
			WM	TA-1-27-100N
			CAD	PROJECT NUMBER
			AK	AR20245
			PROJECT MANAGER	APPROVED DRAWING DATE
			SD	07-23-2021
				RELEASE NUMBER
				1



A B C D E F G H J K

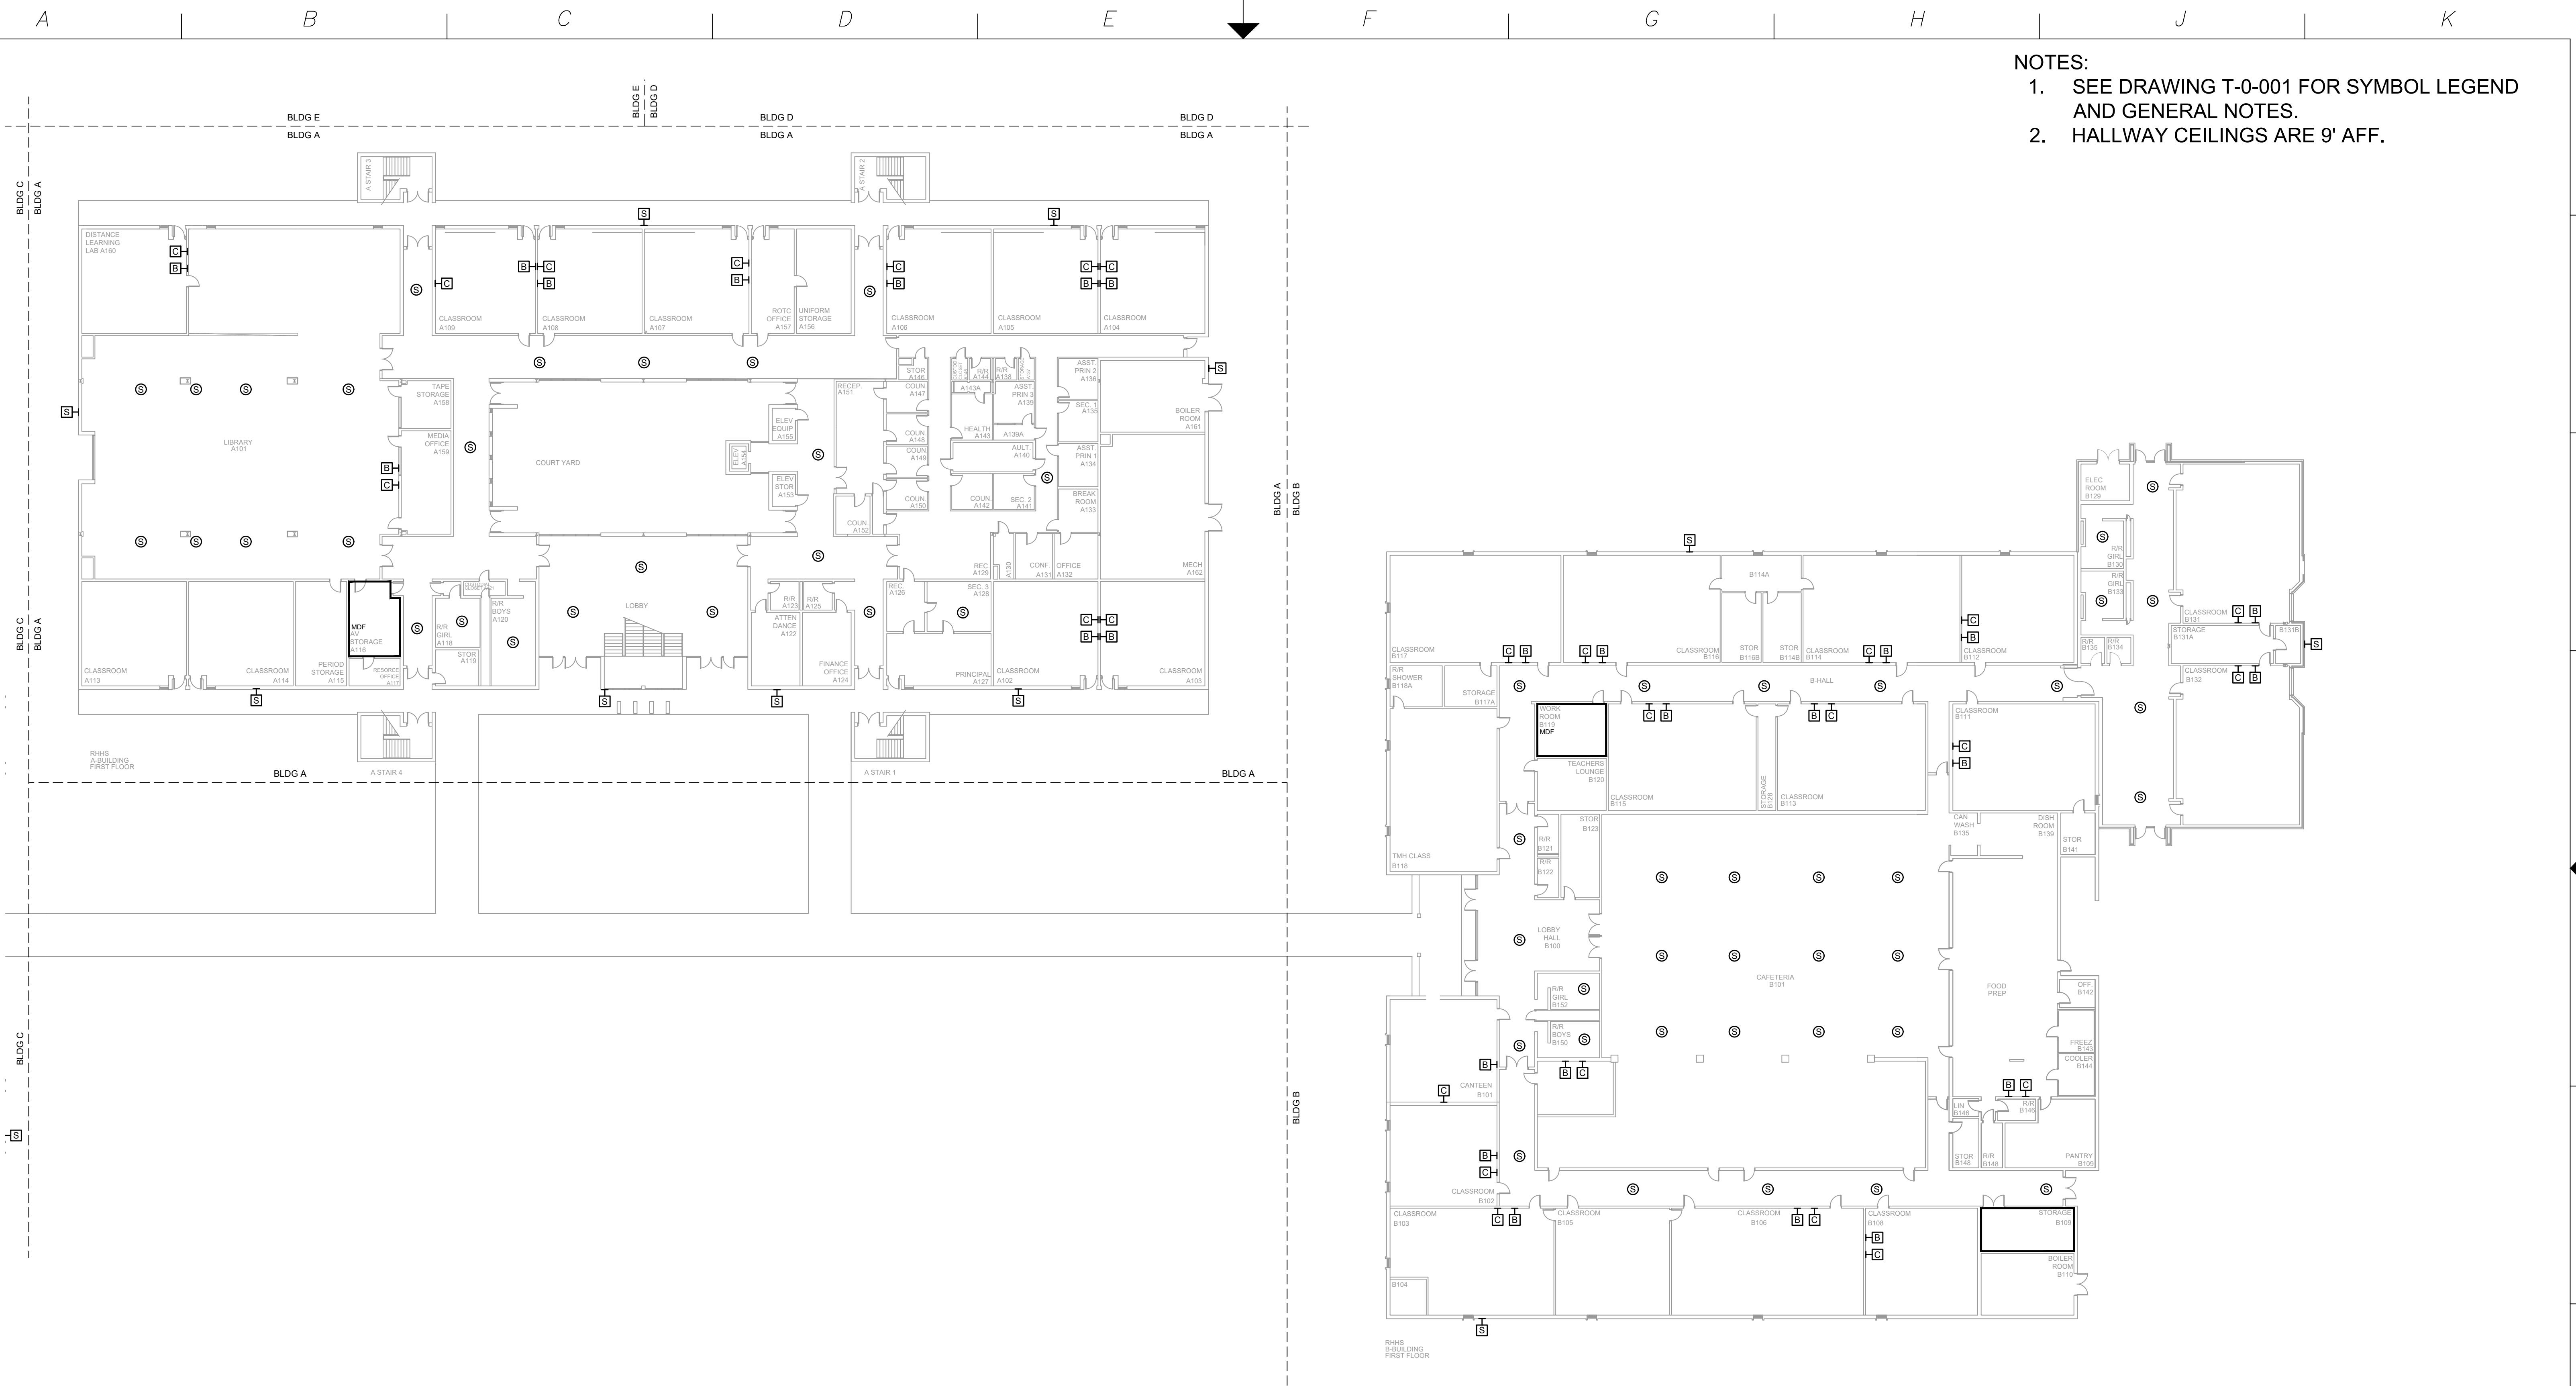

1 AV EQUIPMENT LAYOUT - BLDG A & BLDG B

SCALE: NTS

REVISIONS			ENGINEER APPROVAL	ENGINEER WM	DRAWING NAME TA-1-27-101N
REV.	DESCRIPTION	DATE			
				CAD AK	PROJECT NUMBER AR20245
				PROJECT MANAGER SD	APPROVED DRAWING DATE 07-23-2021
					RELEASE NUMBER 1

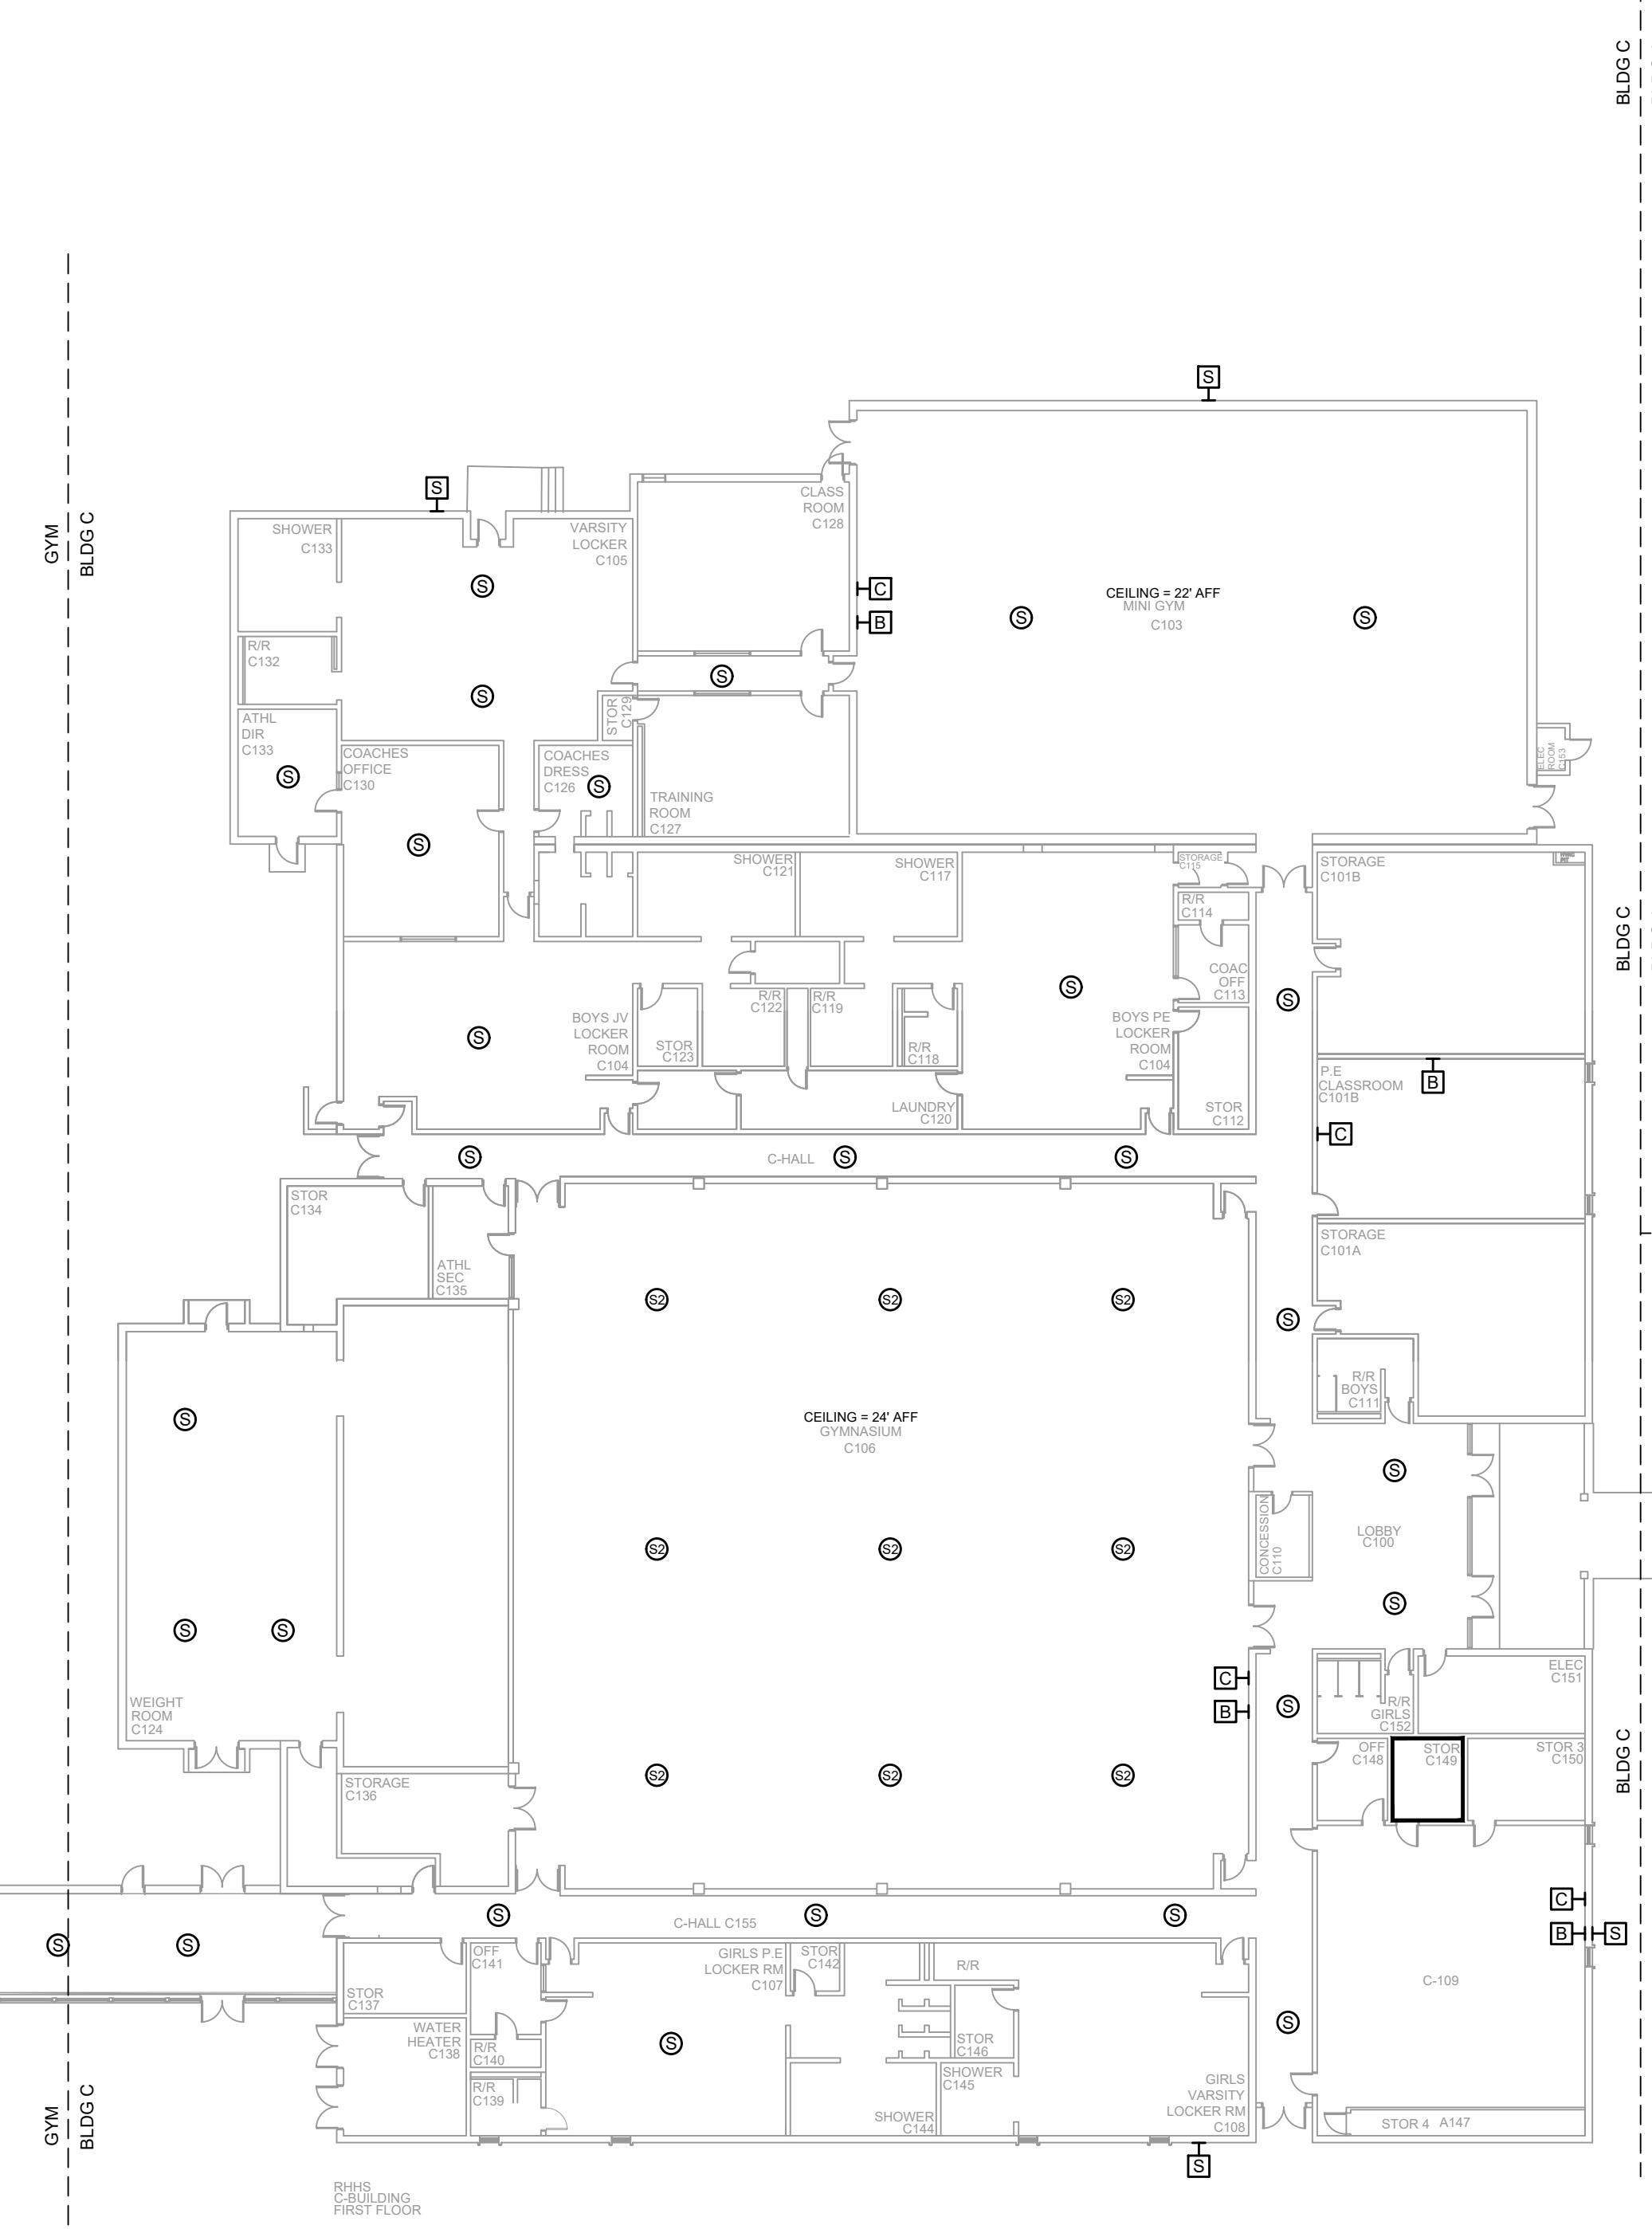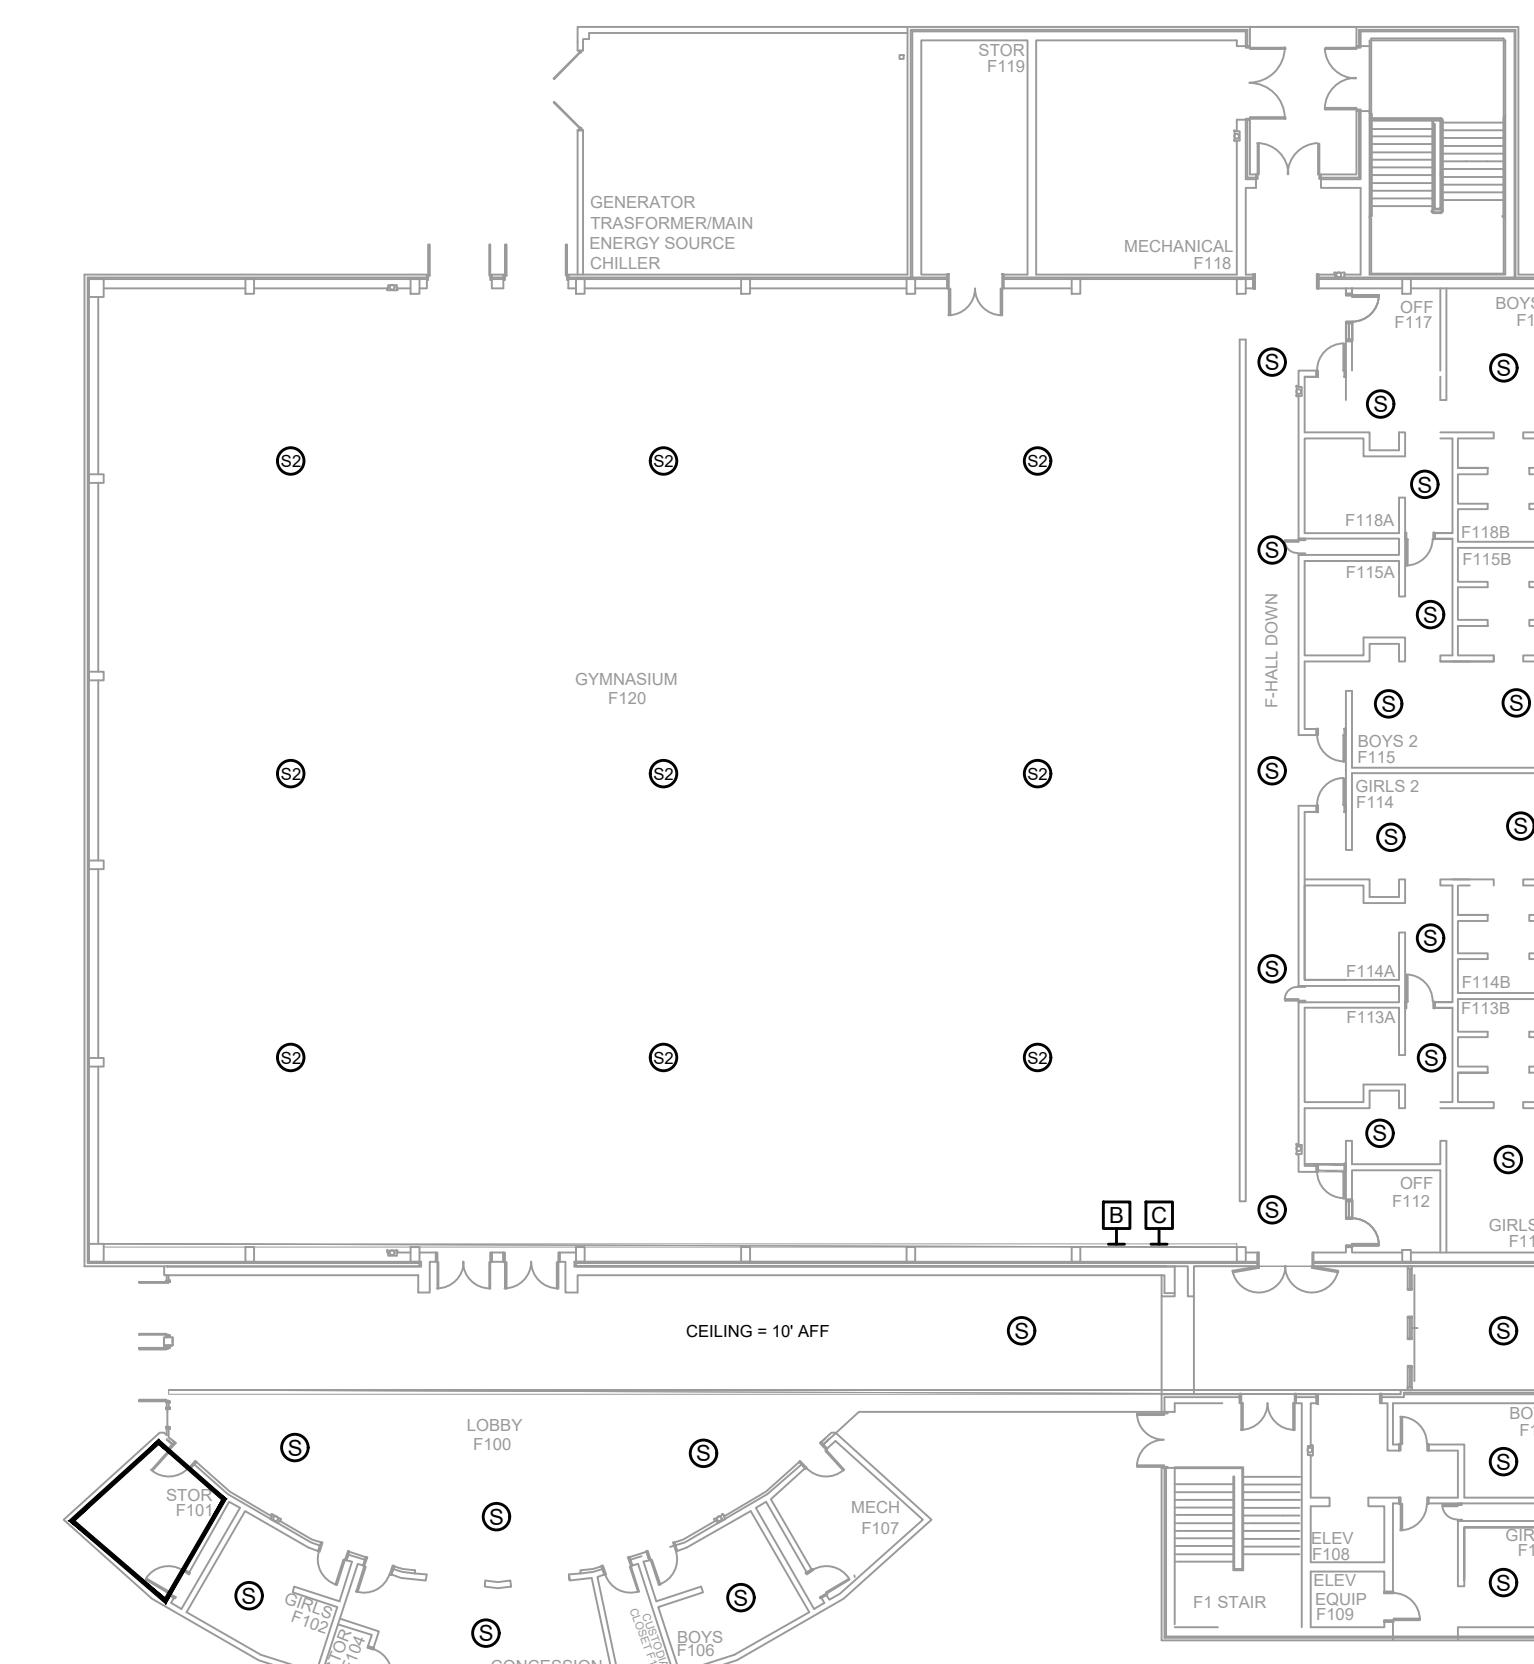

1 AV EQUIPMENT LAYOUT - BLDG C & GYM
SCALE: NTS

NOTES:
 1. SEE DRAWING T-0-001 FOR SYMBOL LEGEND AND GENERAL NOTES.
 2. HALLWAY CEILINGS ARE 9' AFF.

REVISIONS		
REV.	DESCRIPTION	DATE

ENGINEER APPROVAL	ENGINEER	DRAWING NAME
	WM	TA-1-27-102N
	AK	PROJECT NUMBER
AR20245	SD	APPROVED DRAWING DATE 07-23-2021
		RELEASE NUMBER 1

A

E

F

 

G

H

K


NOTES:

1. SEE DRAWING T-0-001 FOR SYMBOL LEGEND AND GENERAL NOTES.
 2. HALLWAY CEILINGS ARE 9' AFF.

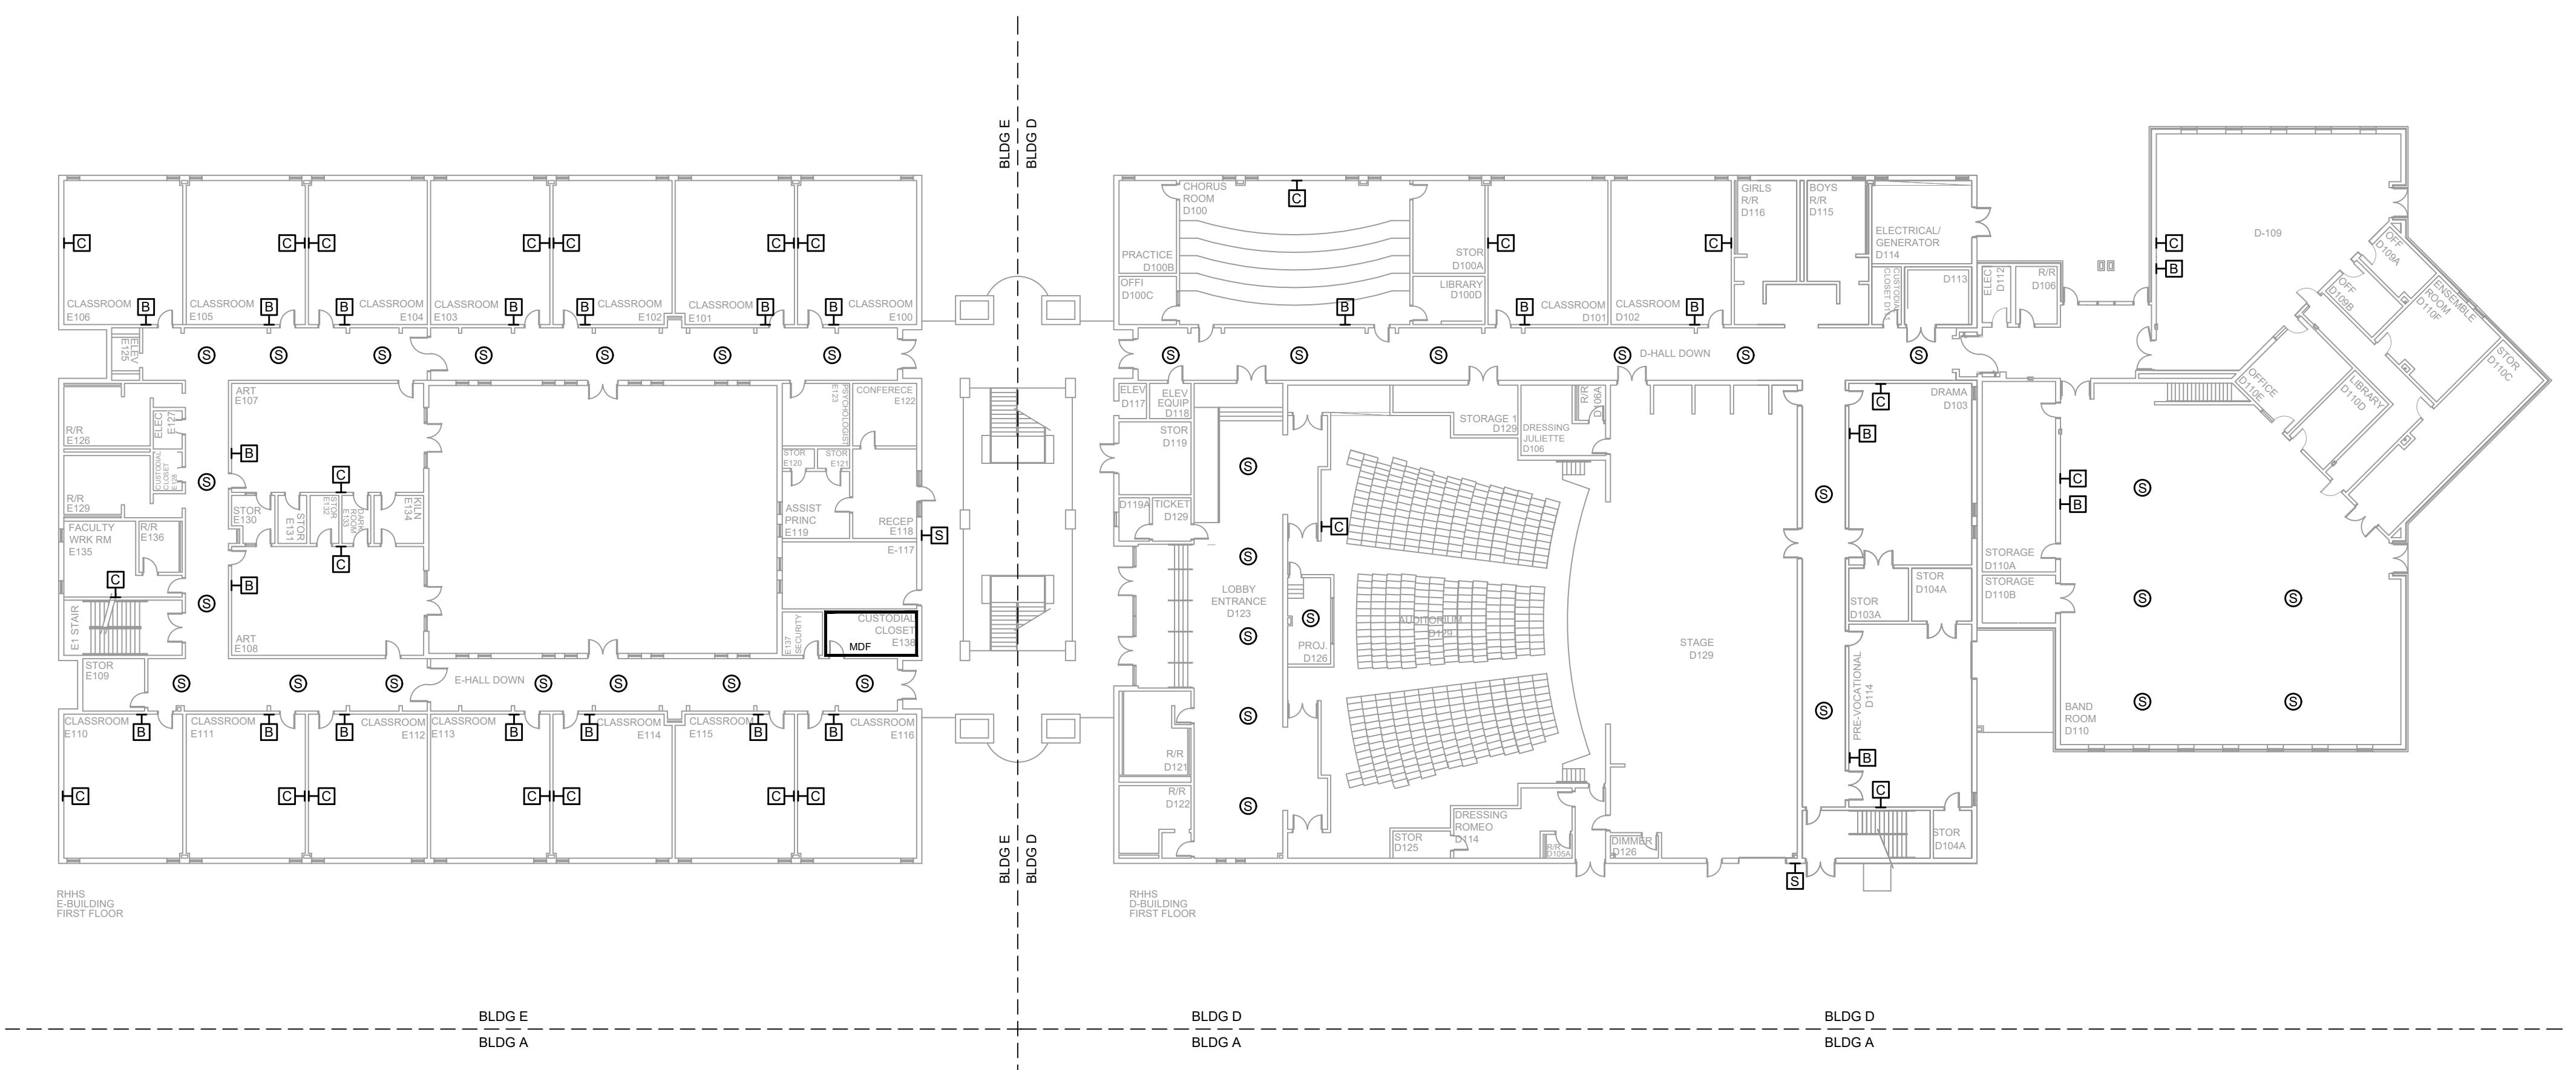

AV EQUIPMENT LAYOUT - BLDG E & D

SCALE: NTS

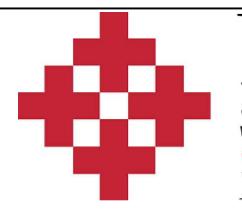

NetPlanner SYSTEMS, INC.[®]

Your Pathway to Connectivity
662-5482 Augusta, GA 706-364-4199
290-8010 Columbus, GA 706-571-9099
795-1975 Savannah, GA 912-748-8966
www.netjourner.com

CLIENT LOC

PROJECT INFO

ROCK HILL SCHOOLS ROCK HILL, SC

SHEET INFO


INTERCOM & NOTIFICATIONS

**ROCK HILL HS - 1ST FLR BLDG D & E - NEW
DEVICES**

REVISIONS			ENGINEER APPROVAL	ENGINEER WM	DRAWING NAME
REV.	DESCRIPTION	DATE			TA-1-27-103N
				CAD	PROJECT NUMBER
				AK	AR20245
				PROJECT MANAGER	APPROVED DRAWING DATE
				SD	RELEASE NUMBER 1

A B C D E F G H J K

NOTES:
1. SEE DRAWING T-0-001 FOR SYMBOL LEGEND AND GENERAL NOTES.
2. HALLWAY CEILINGS ARE 9' AFF.

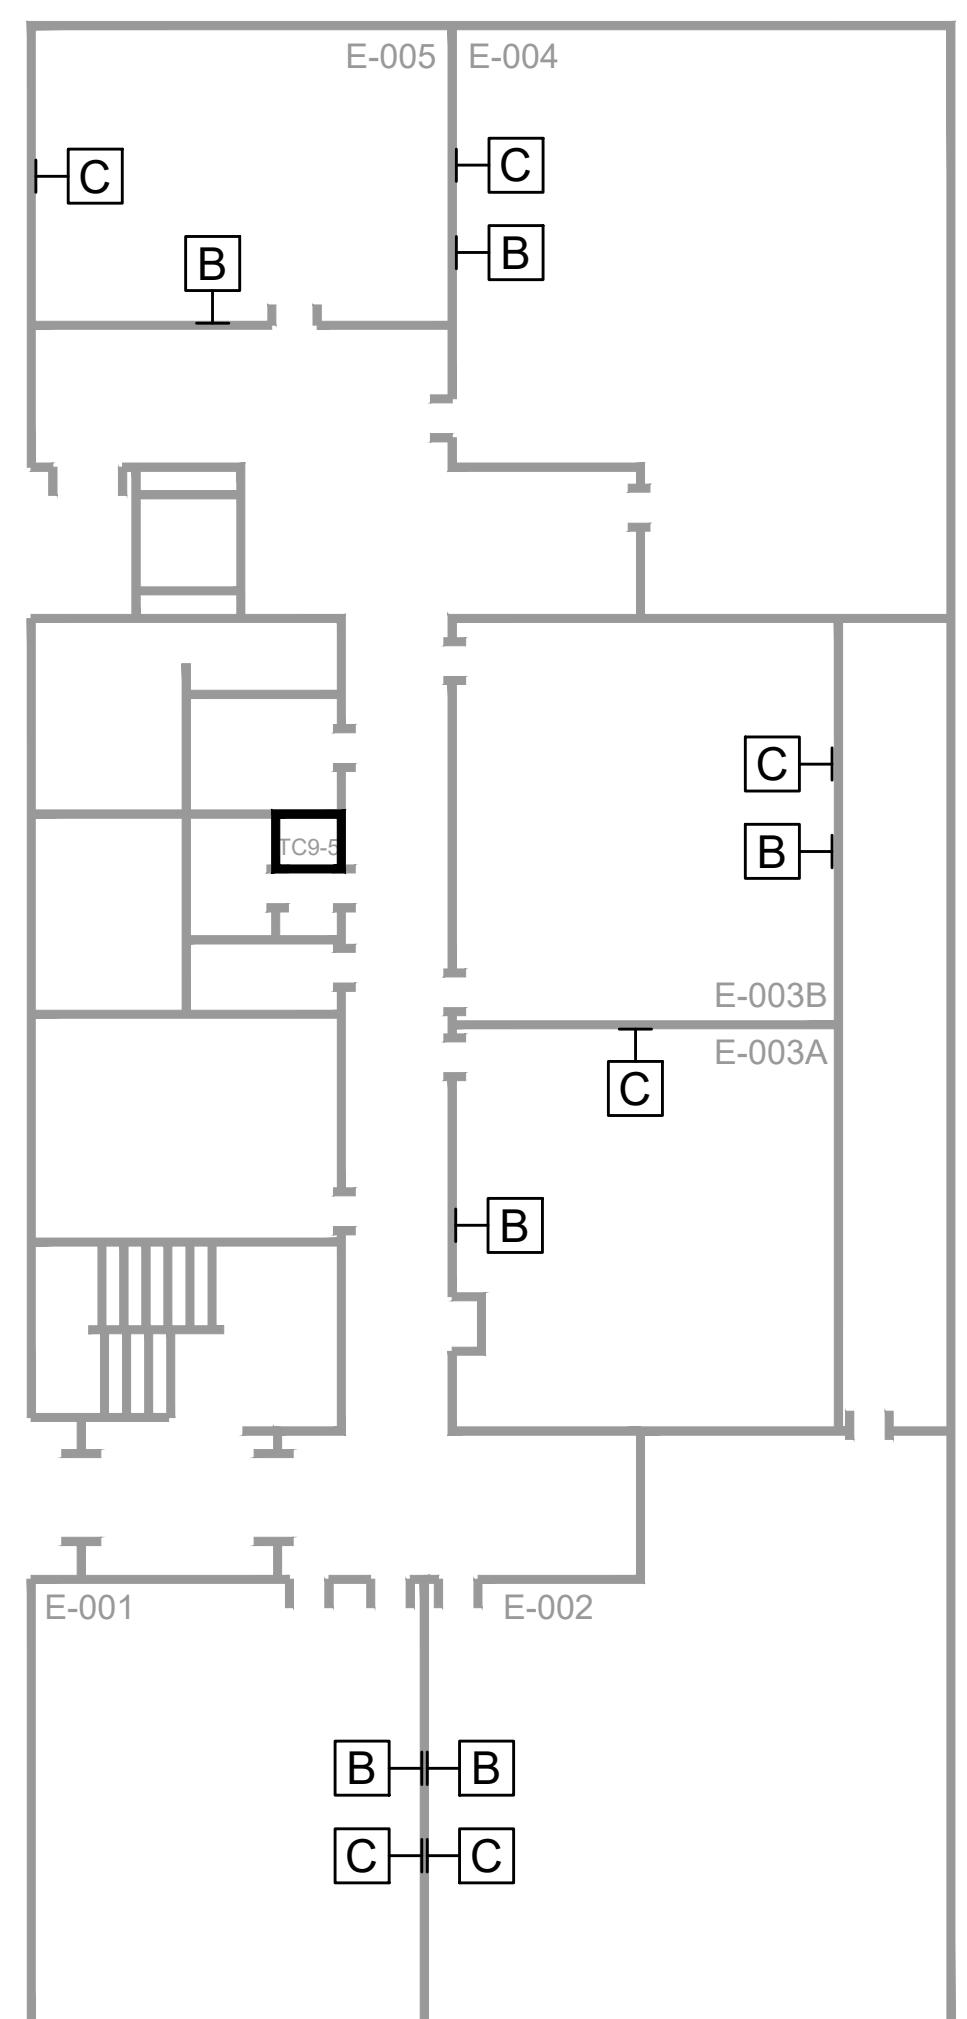


1 AV EQUIPMENT LAYOUT
SCALE: NTS



REV.	DESCRIPTION	DATE	REVISIONS	
			ENGINEER APPROVAL	ENGINEER DRAWING NAME
			WM	TA-1-27-104N
			CAD	PROJECT NUMBER
			AK	AR20245
			SD	PROJECT MANAGER APPROVED DRAWING DATE RELEASE NUMBER
				07-23-2021 1

A B C D E F G H J K

NOTES:
 1. SEE DRAWING T-0-001 FOR SYMBOL LEGEND AND GENERAL NOTES.
 2. HALLWAY CEILINGS 9' AFF.

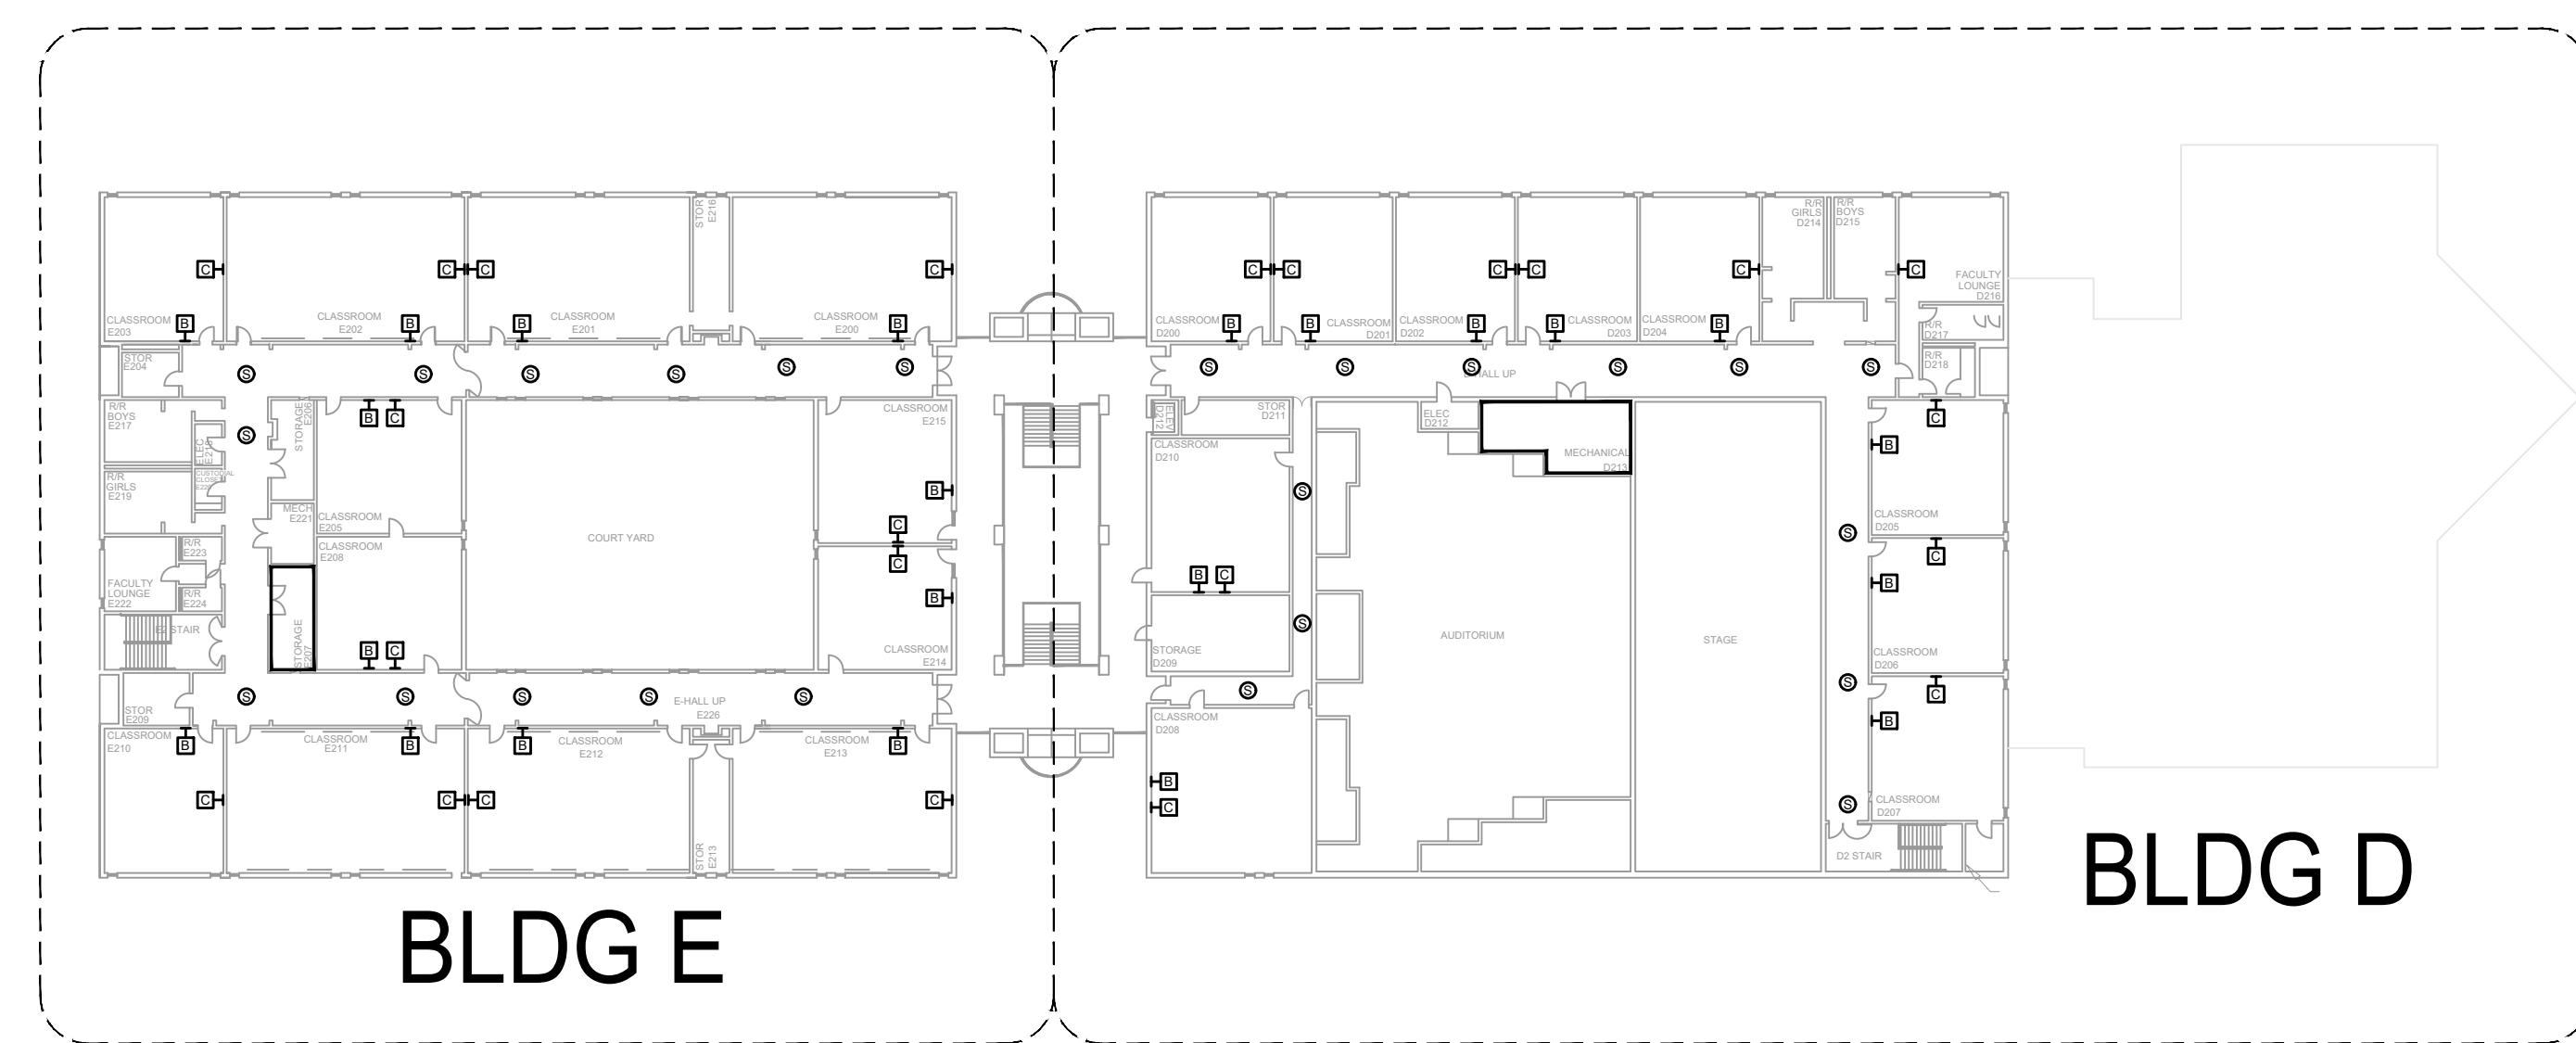

BLDG D

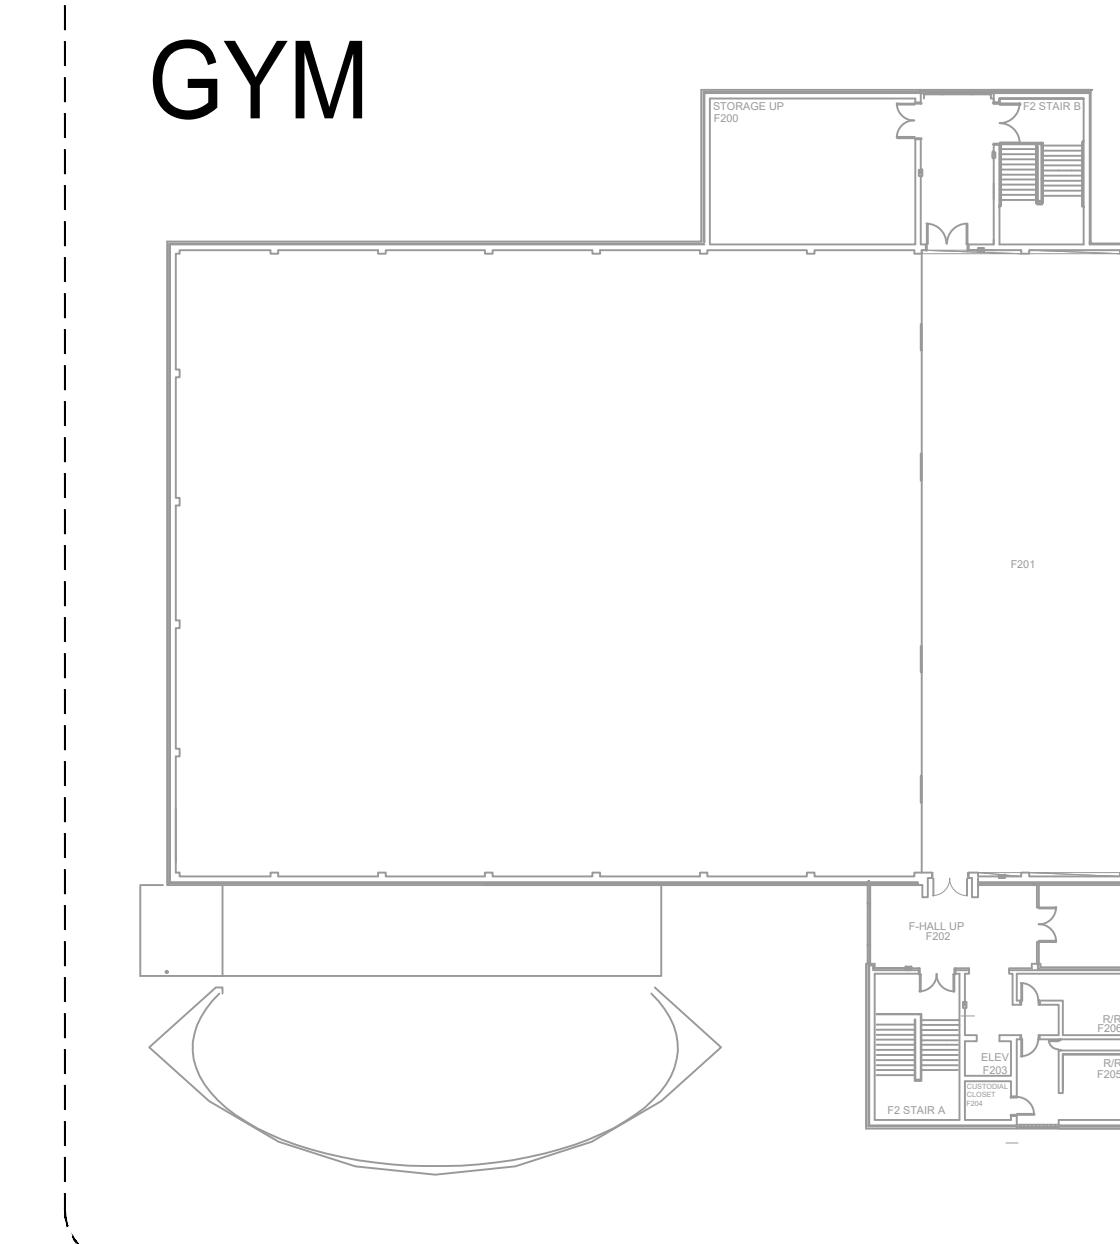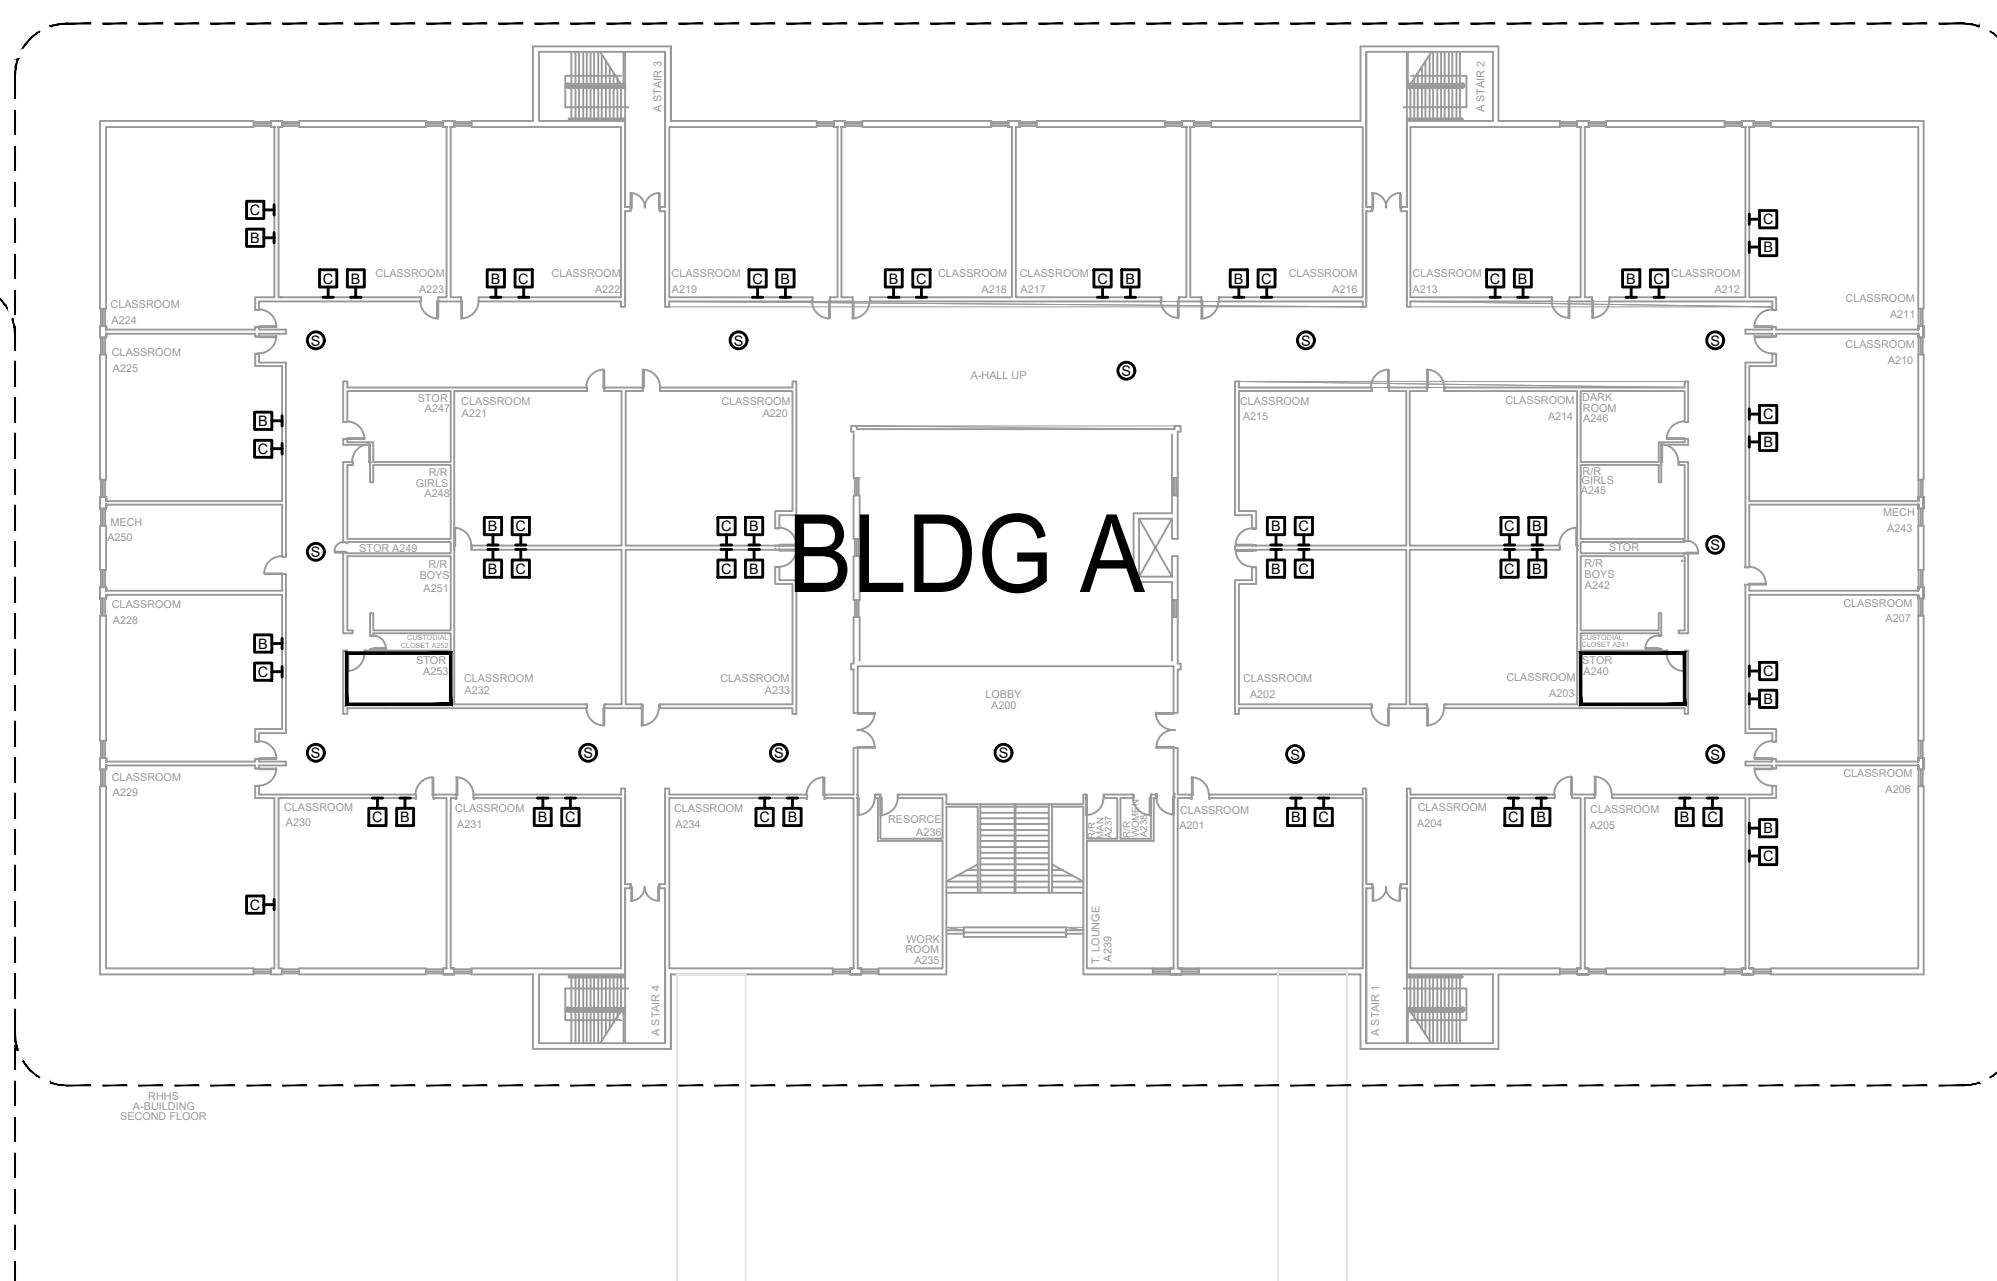

**BLDG C
ROOF BELOW**




1 AV EQUIPMENT LAYOUT - OVERALL

SCALE: NTS



REVISIONS			ENGINEER APPROVAL	ENGINEER WM	DRAWING NAME TA-1-27-200N
REV.	DESCRIPTION	DATE			
				CAD AK	PROJECT NUMBER AR20245
				PROJECT MANAGER SD	APPROVED DRAWING DATE 07-23-2021 RELEASE NUMBER 1

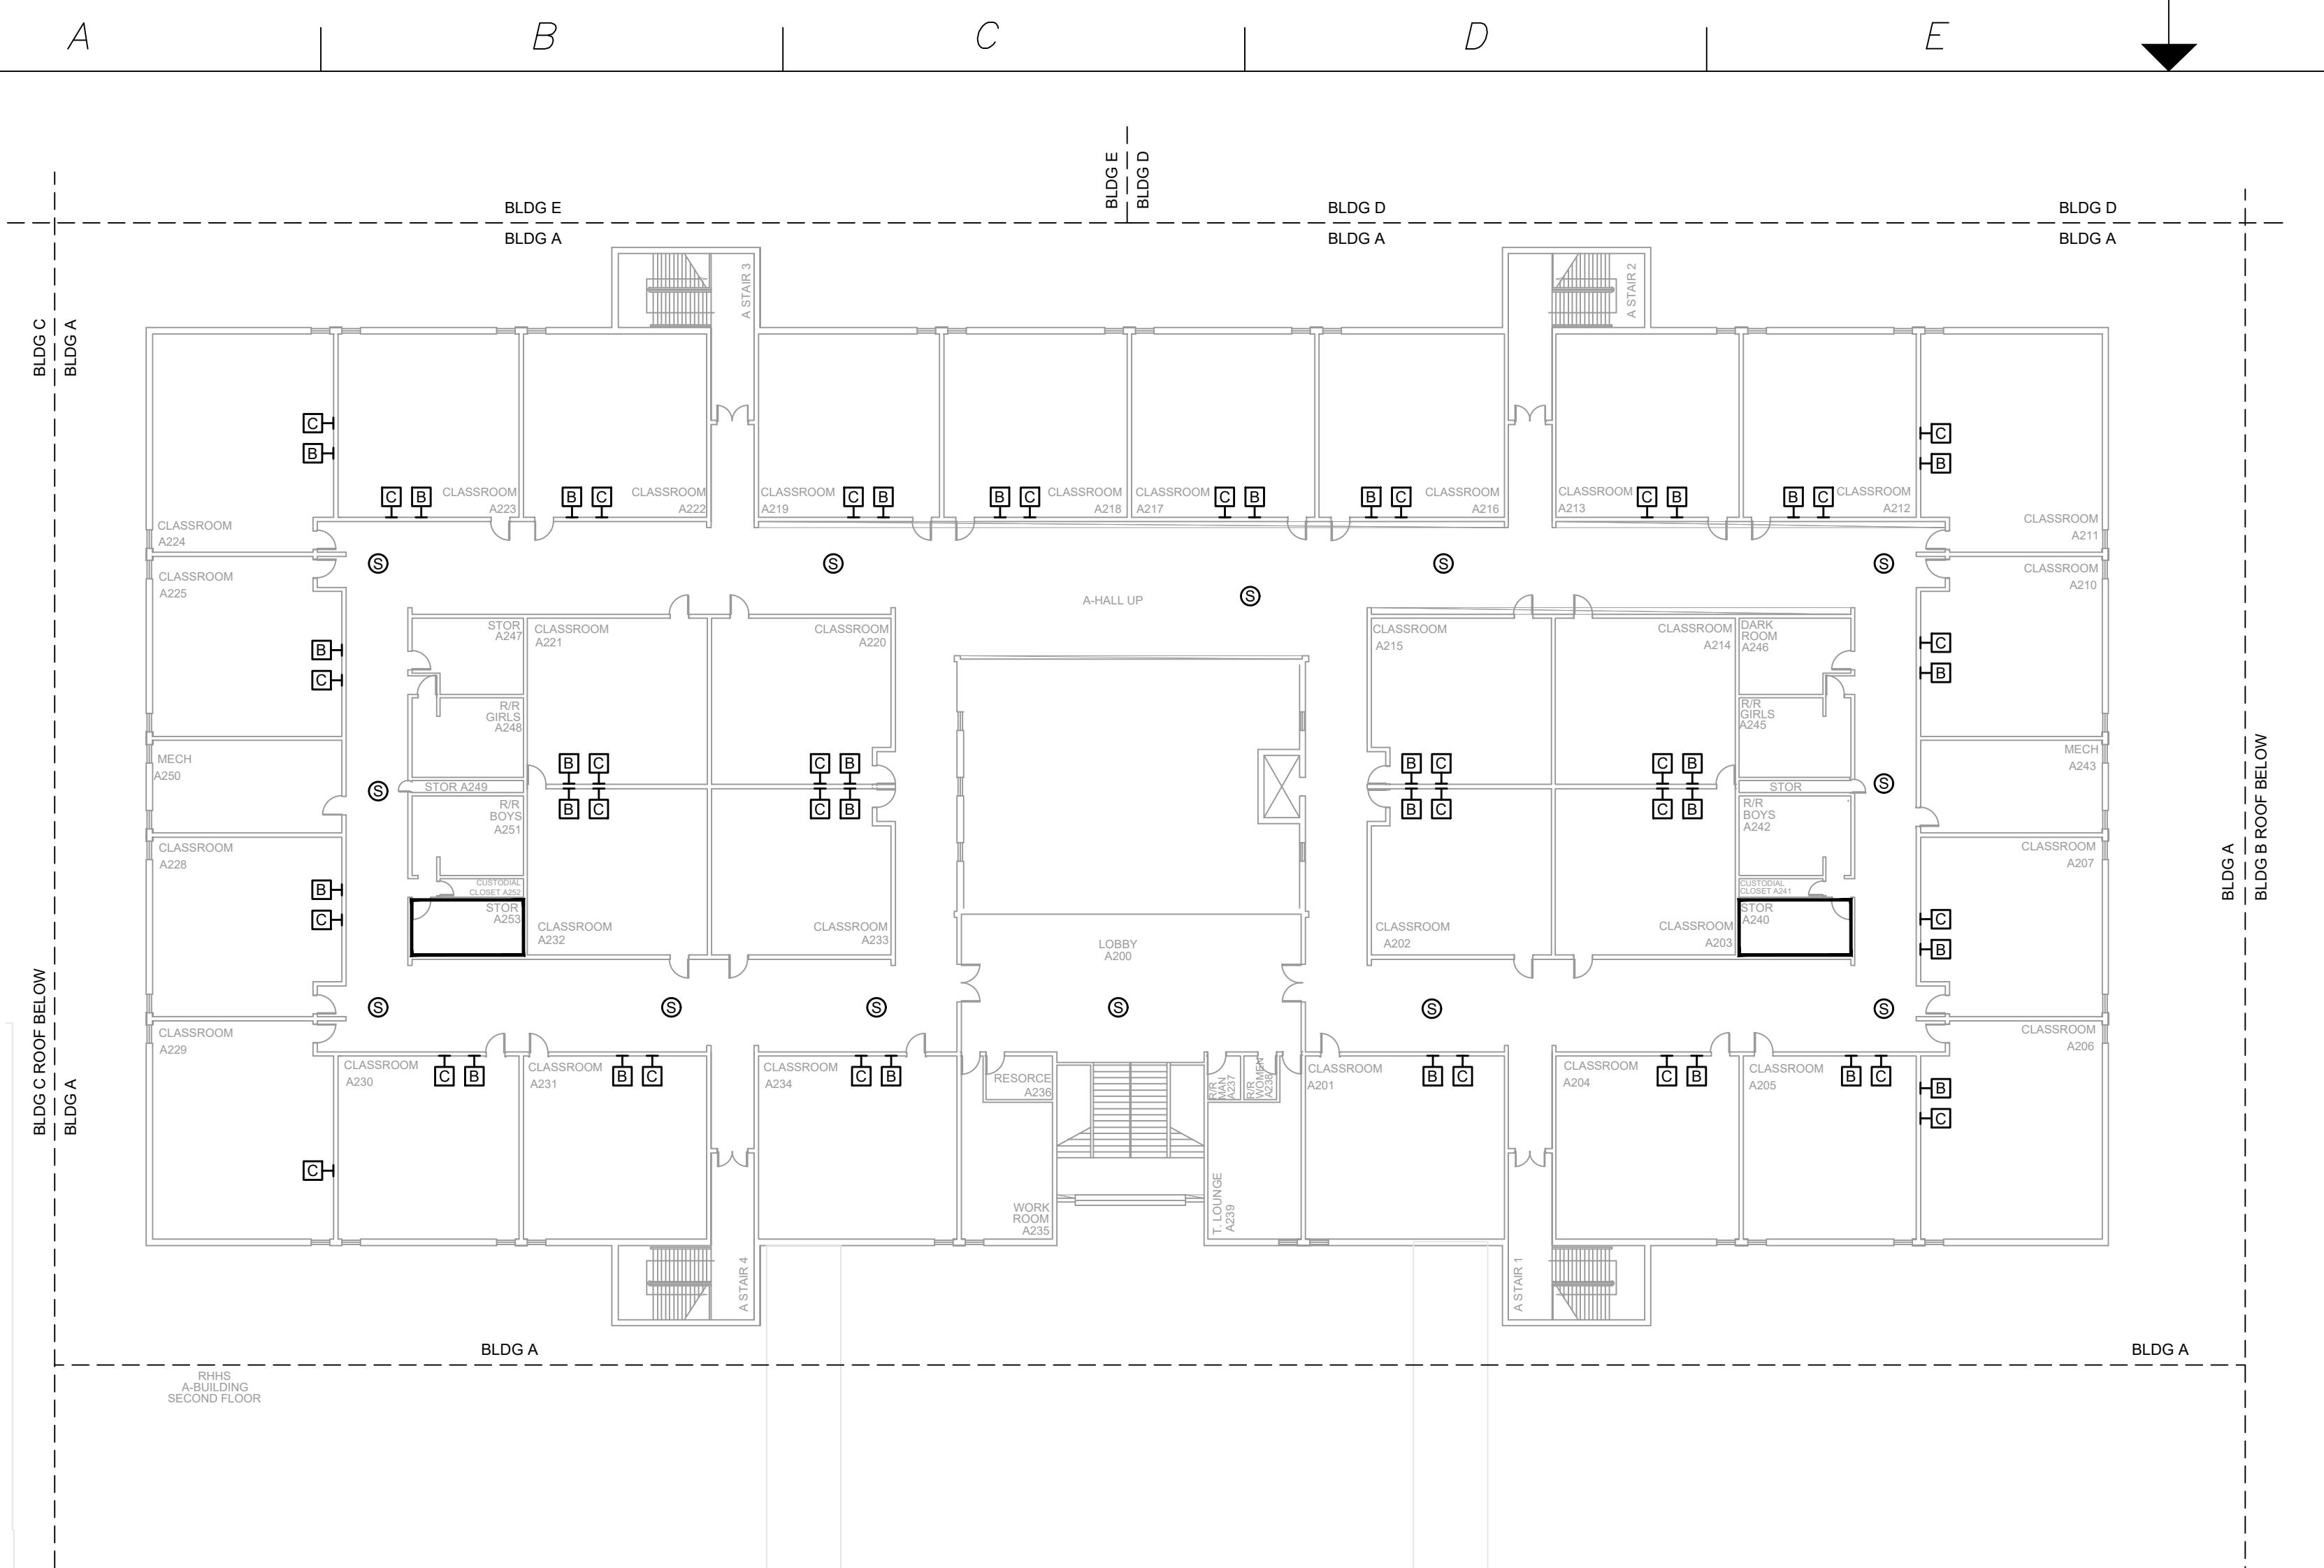

NOTES:

1. SEE DRAWING T-0-001 FOR SYMBOL LEGEND AND GENERAL NOTES.
2. HALLWAY CEILINGS 9' AFF.



SCALE: NTS



NetPlanner

Y S T E M S, I N C.[®]

our Pathway to Connectivity

62-5482	Augusta, GA	706-364-
0-8010	Columbus, GA	706-571-
5-1975	Savannah, GA	912-748-

CLIENT LOGO



PROJECT INFO

ROCK HILL SCHOOLS

ROCK HILL SC



SHEET INFO

INTERCOM & NOTIFICATIONS

ROCK HILL HS - 2ND FLR BLDG A - NEW DELICES

REVISIONS			ENGINEER APPROVAL	ENGINEER WM	DRAWING NAME
REV.	DESCRIPTION	DATE			TA-1-27-201N
				CAD AK	PROJECT NUMBER AR20245
				PROJECT MANAGER	
				APPROVED DRAWING DATE	
				RELEASE NUMBER 1	

 NOTES:
 1. SEE DRAWING T-0-001 FOR SYMBOL LEGEND AND GENERAL NOTES.
 2. HALLWAY CEILINGS 9' AFF.

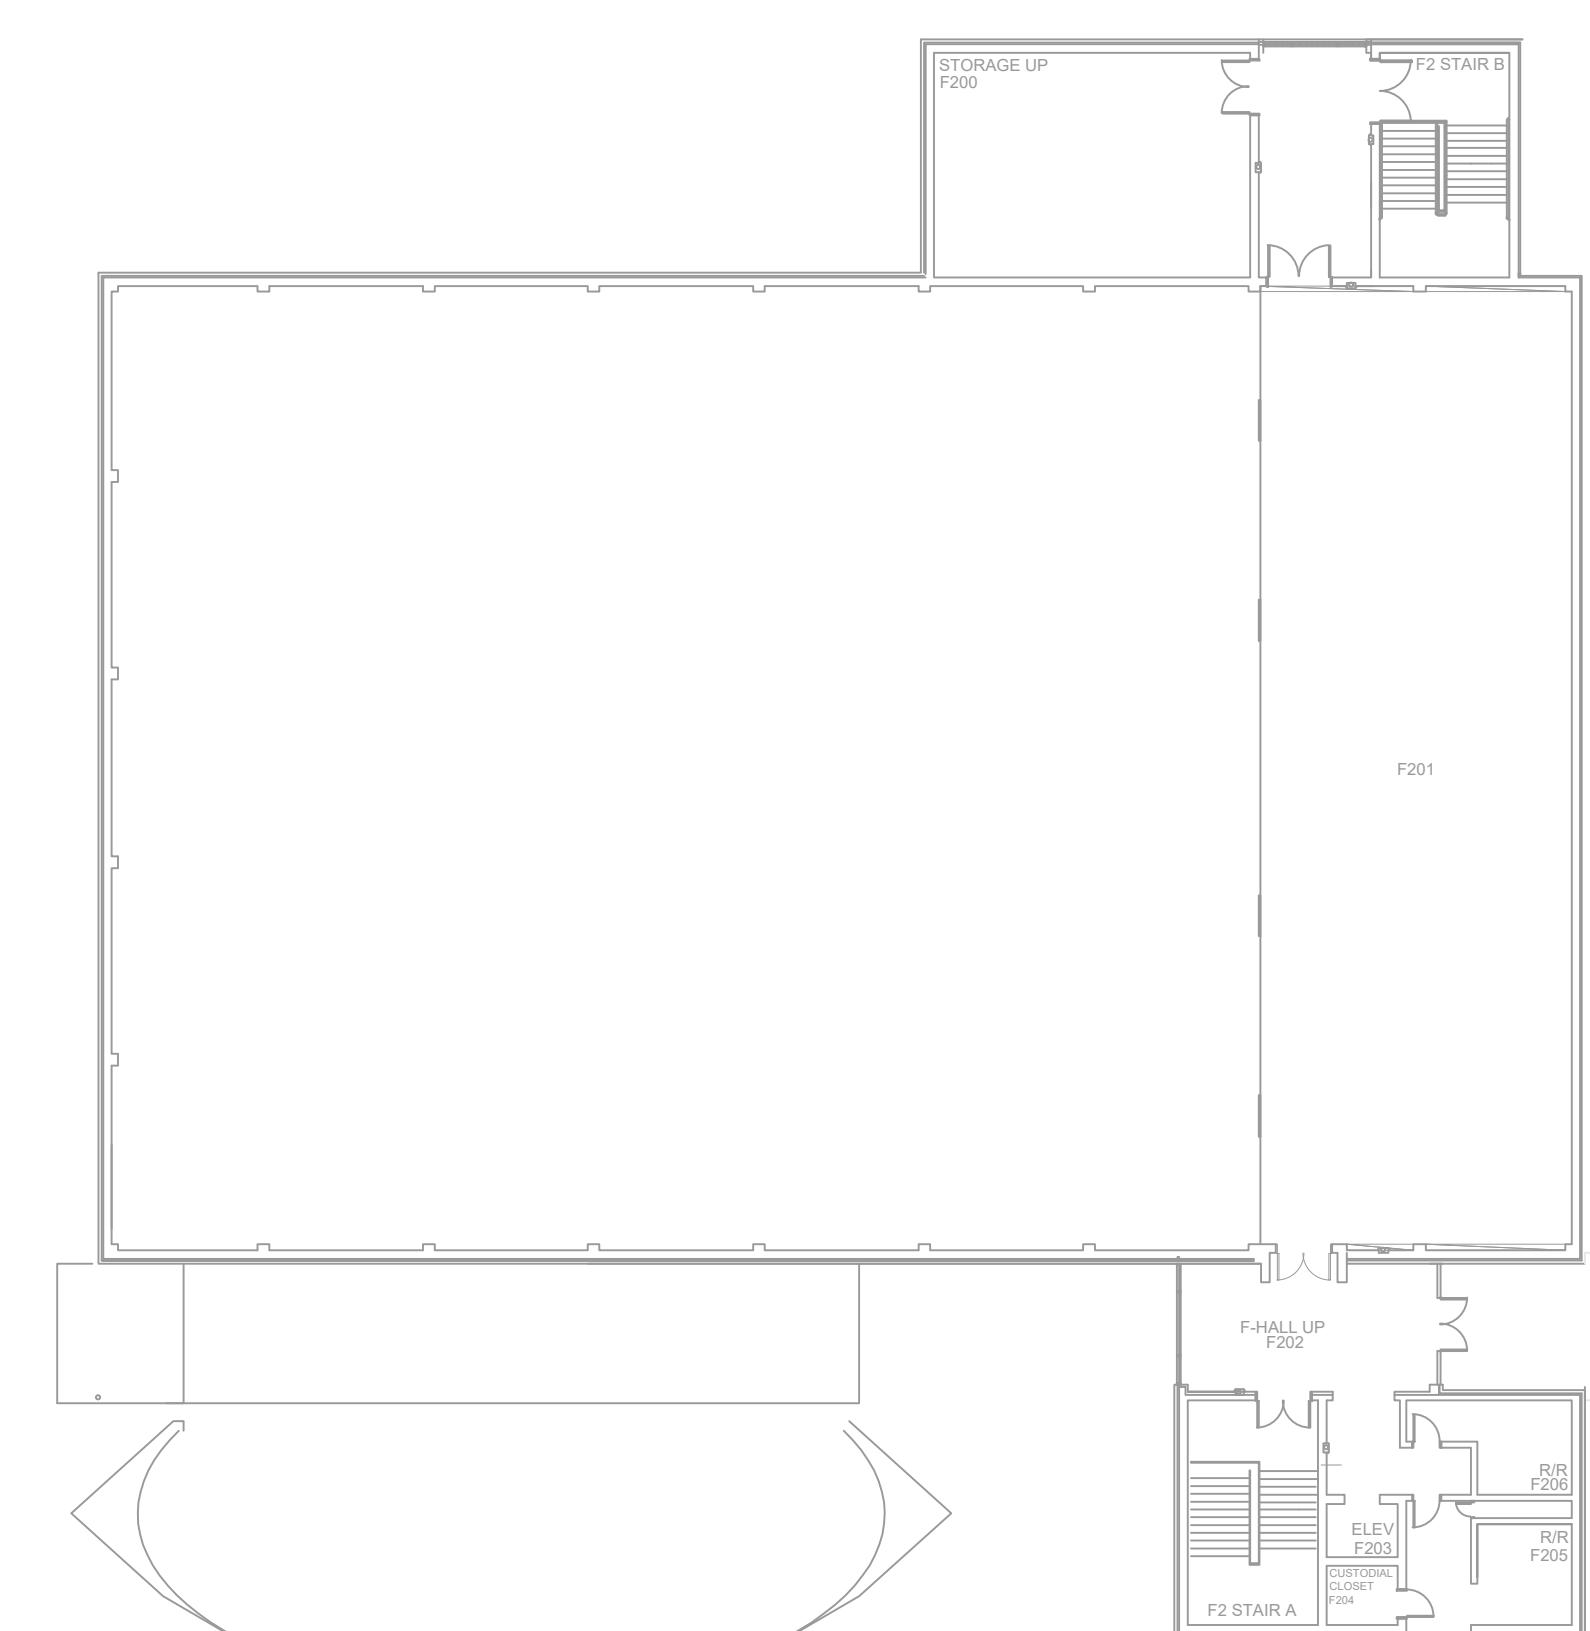


AV EQUIPMENT LAYOUT - BLDG C & GYM
SCALE: NTS

REVISIONS			ENGINEER APPROVAL	ENGINEER WM	DRAWING NAME
REV.	DESCRIPTION	DATE			

PROJECT NUMBER	APPROVED DRAWING DATE	RELEASE NUMBER	DRAWING NAME
			TA-1-27-202N
AR20245	07-23-2021	1	

A B C D E F G H J K


- NOTES:
- SEE DRAWING T-0-001 FOR SYMBOL LEGEND AND GENERAL NOTES.
 - HALLWAY CEILINGS 9' AFF.

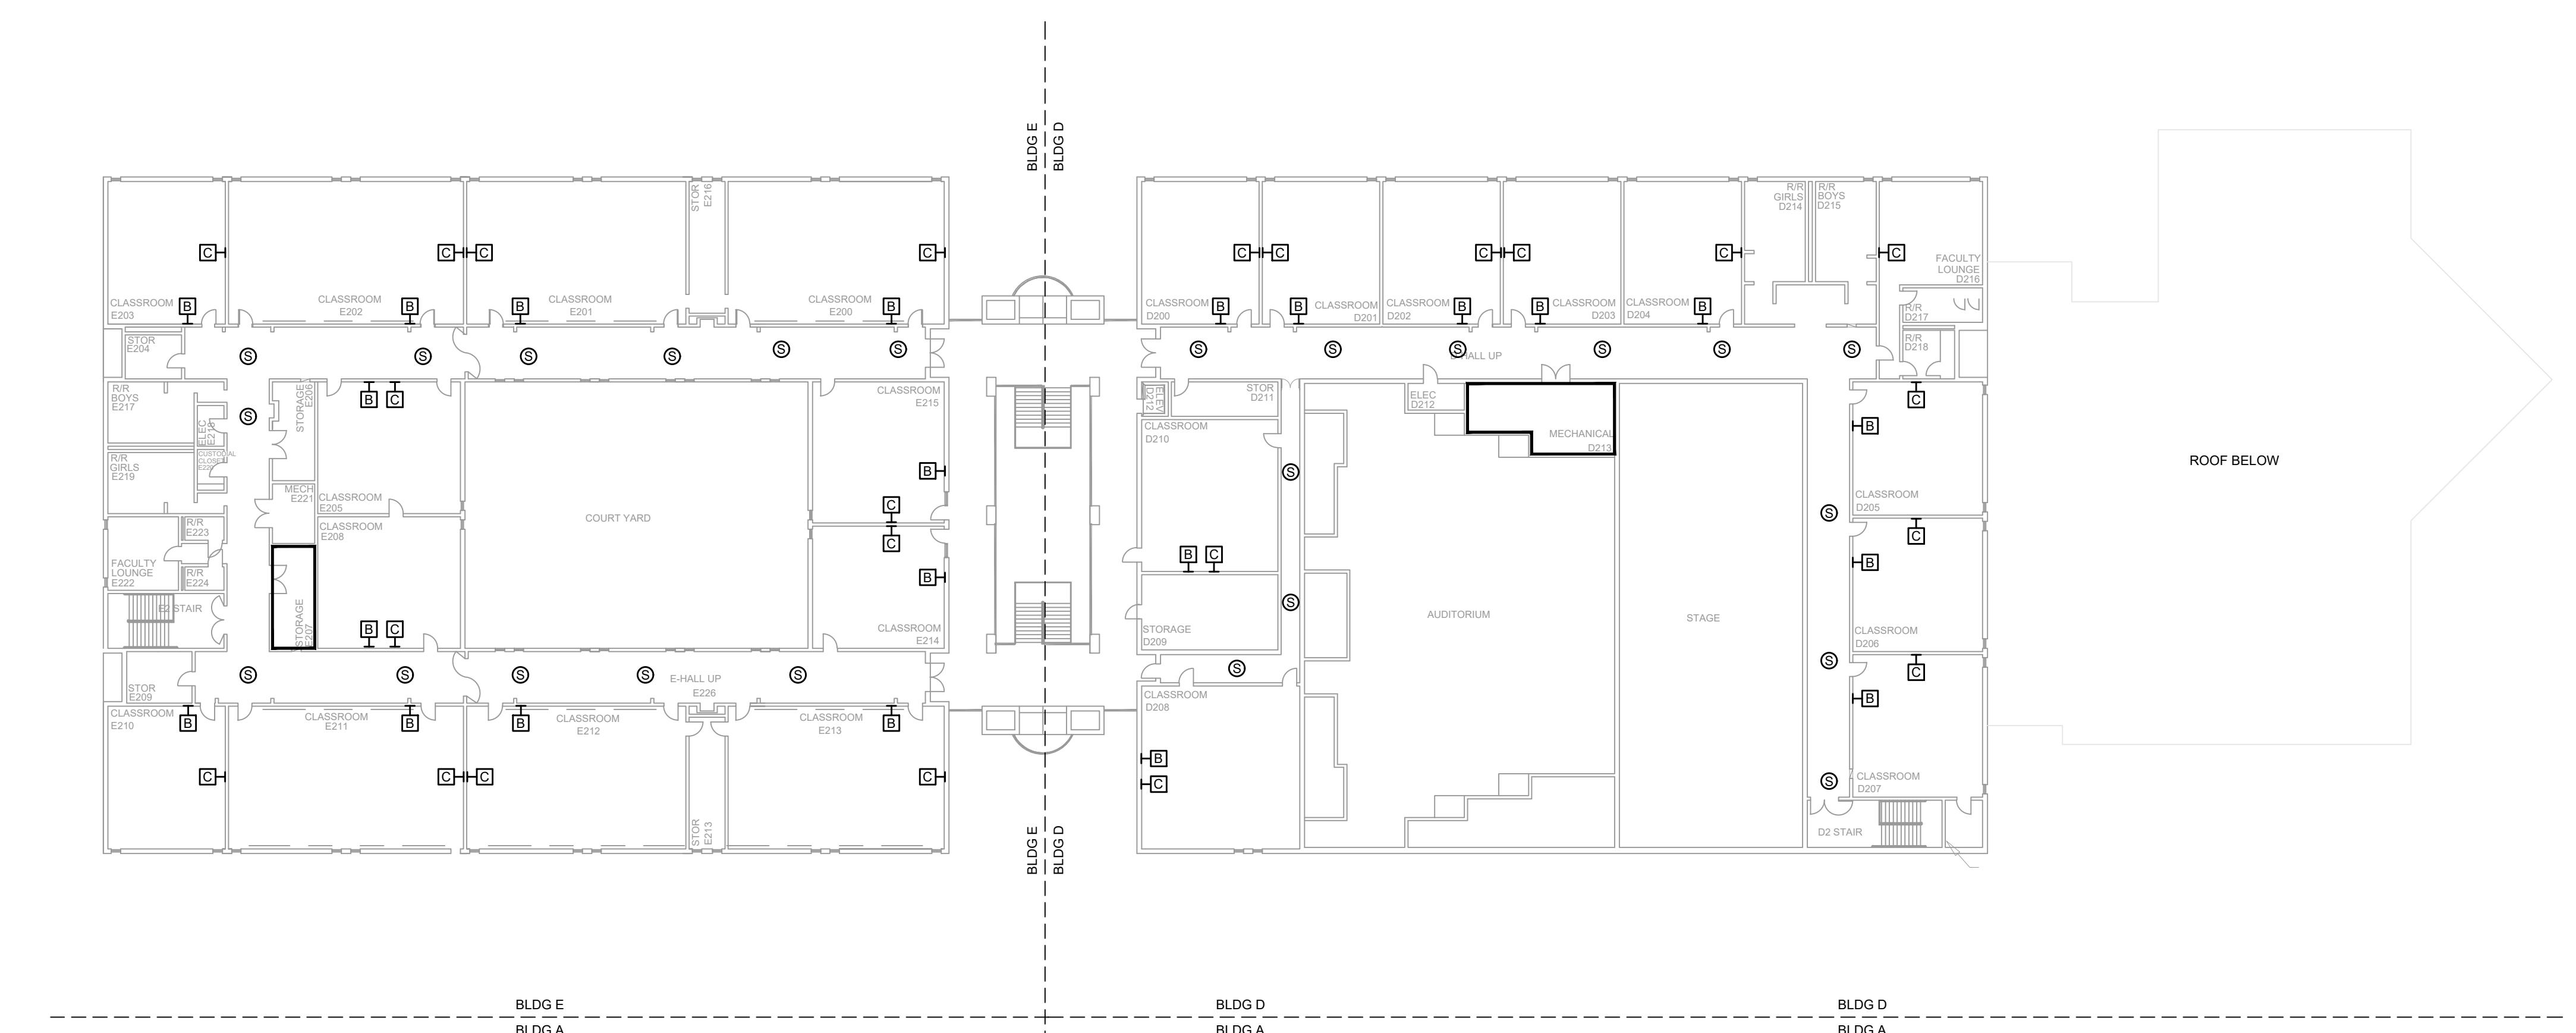

1 AV EQUIPMENT LAYOUT - BLDG E & D
SCALE: NTS

REVISIONS			ENGINEER APPROVAL	ENGINEER WM	DRAWING NAME TA-1-27-203N
REV.	DESCRIPTION	DATE			
				CAD AK	PROJECT NUMBER AR20245
				PROJECT MANAGER SD	APPROVED DRAWING DATE 07-23-2021
					RELEASE NUMBER 1

A B C D E F G H J K

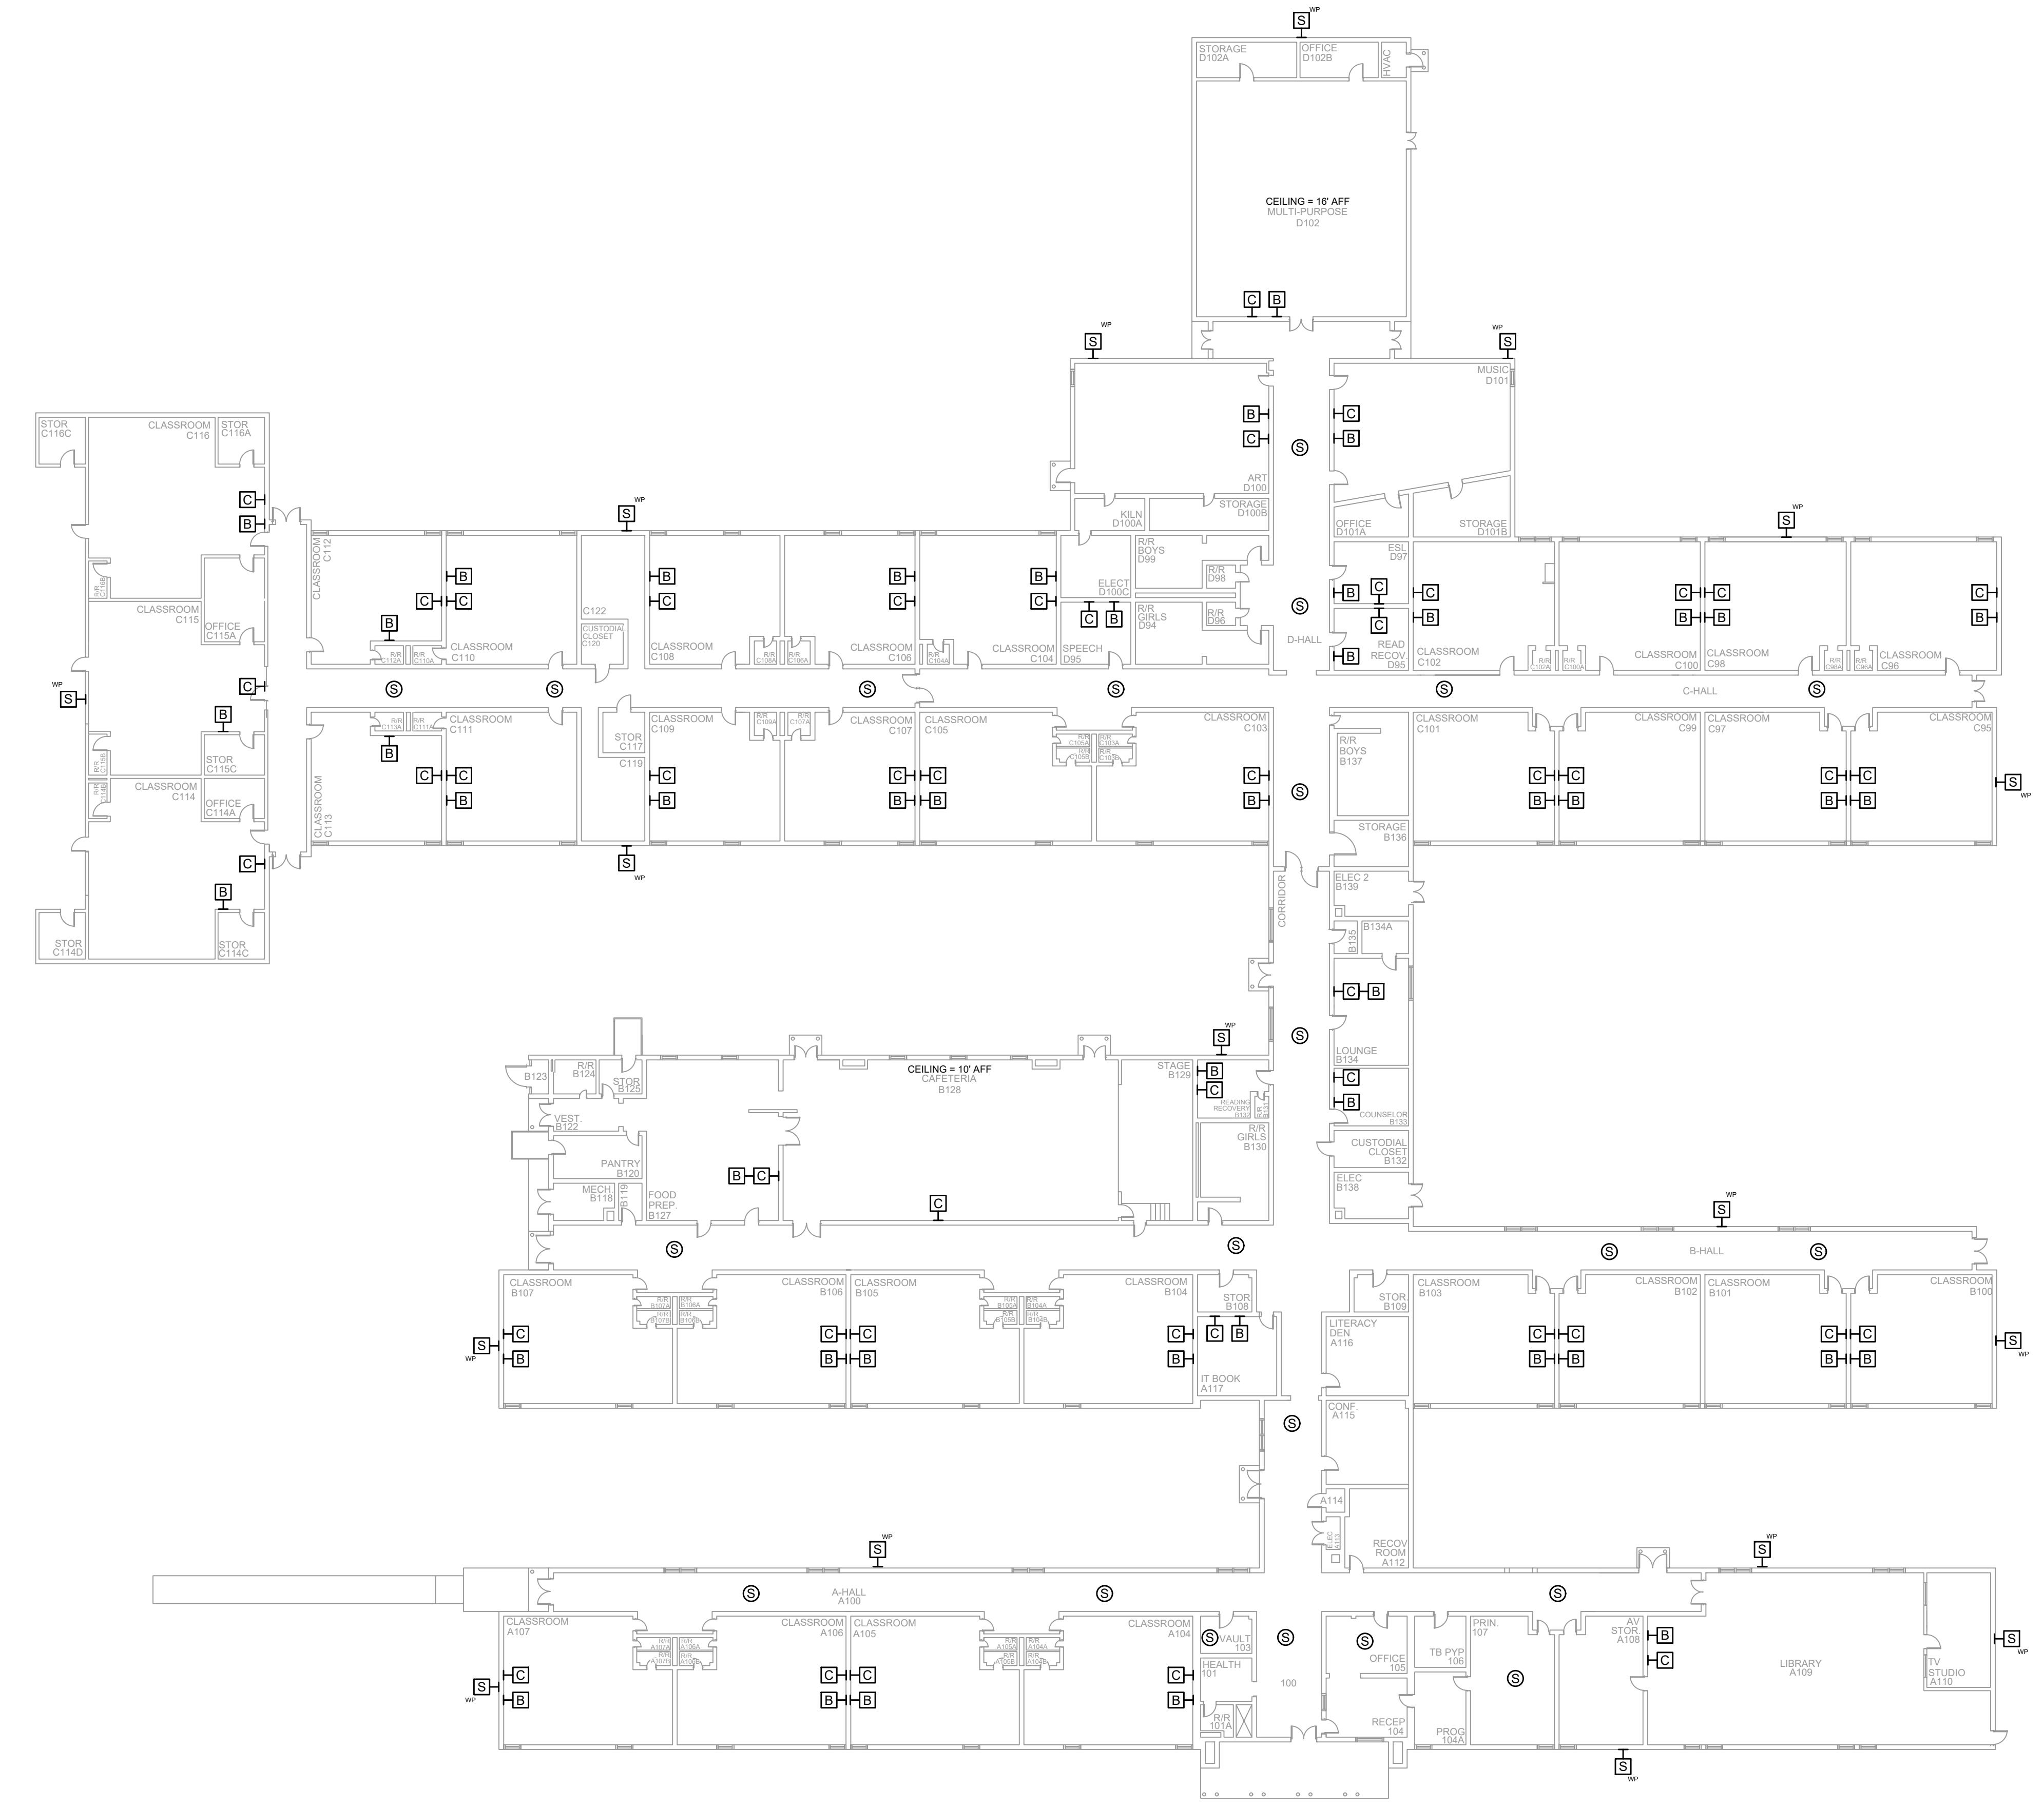

NOTES:

1. SEE DRAWING T-0-001 FOR SYMBOL LEGEND AND GENERAL NOTES.
2. HALLWAY CEILINGS ARE 8' - 9' AFF.



NetPlanner SYSTEMS, INC.[®]

Your Pathway to Connectivity

Atlanta, GA	770-662-5482	Augusta, GA	706-364-4190
Raleigh, NC	919-290-8010	Columbus, GA	706-571-9090
Toll Free	800-795-1975	Savannah, GA	912-748-8960

www.netplanner.com



CLIENT LOGO

PROJECT INFO

ROCK HILL SCHOOLS


ROCK HILL, SC

SHEET INFO

INTERCOM & NOTIFICATIONS

ROSEWOOD ELEMENTARY - NEW DEVICES

REVISIONS			ENGINEER APPROVAL	ENGINEER WM	DRAWING NAME
REV.	DESCRIPTION	DATE			TA-1-28-101N
				CAD AK	PROJECT NUMBER
					AR20245
				PROJECT MANAGER SD	APPROVED DRAWING DATE
					07-23-2021
					RELEASE NUMBER
					1

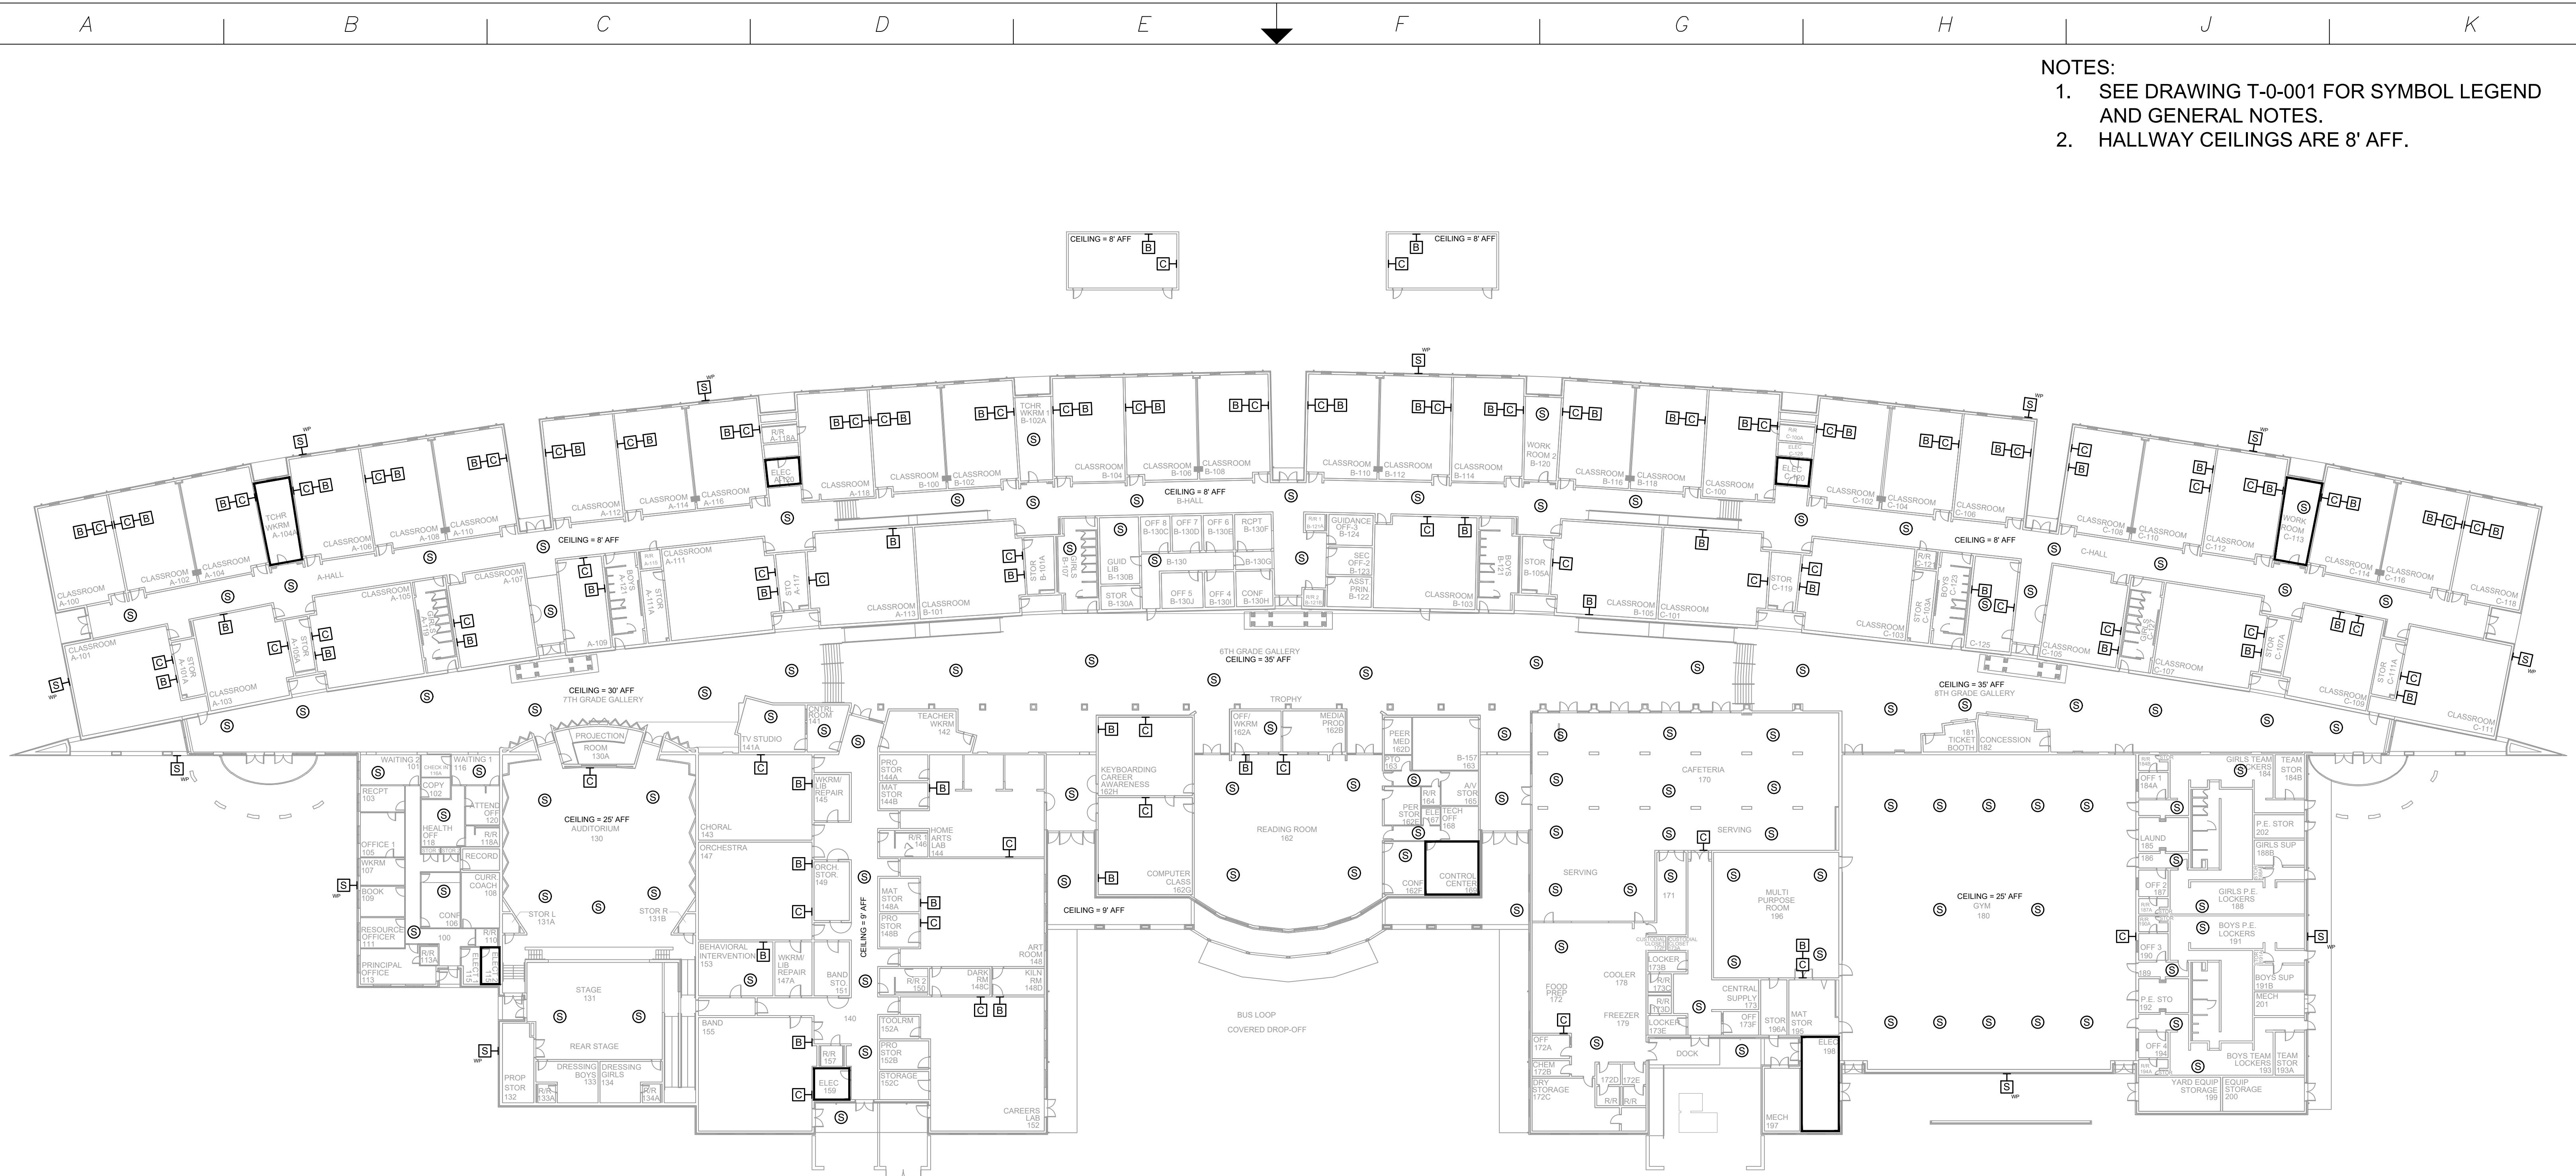


1 AV EQUIPMENT LAYOUT

SCALE: NTS


REV.	DESCRIPTION	DATE	REVISIONS	
			ENGINEER APPROVAL	DRAWING NAME
			WM	TA-1-29-101N
			AK	PROJECT NUMBER
				AR20245
			SD	PROJECT MANAGER
				APPROVED DRAWING DATE
				07-23-2021
				RELEASE NUMBER
				1

A B C D E F G H J K

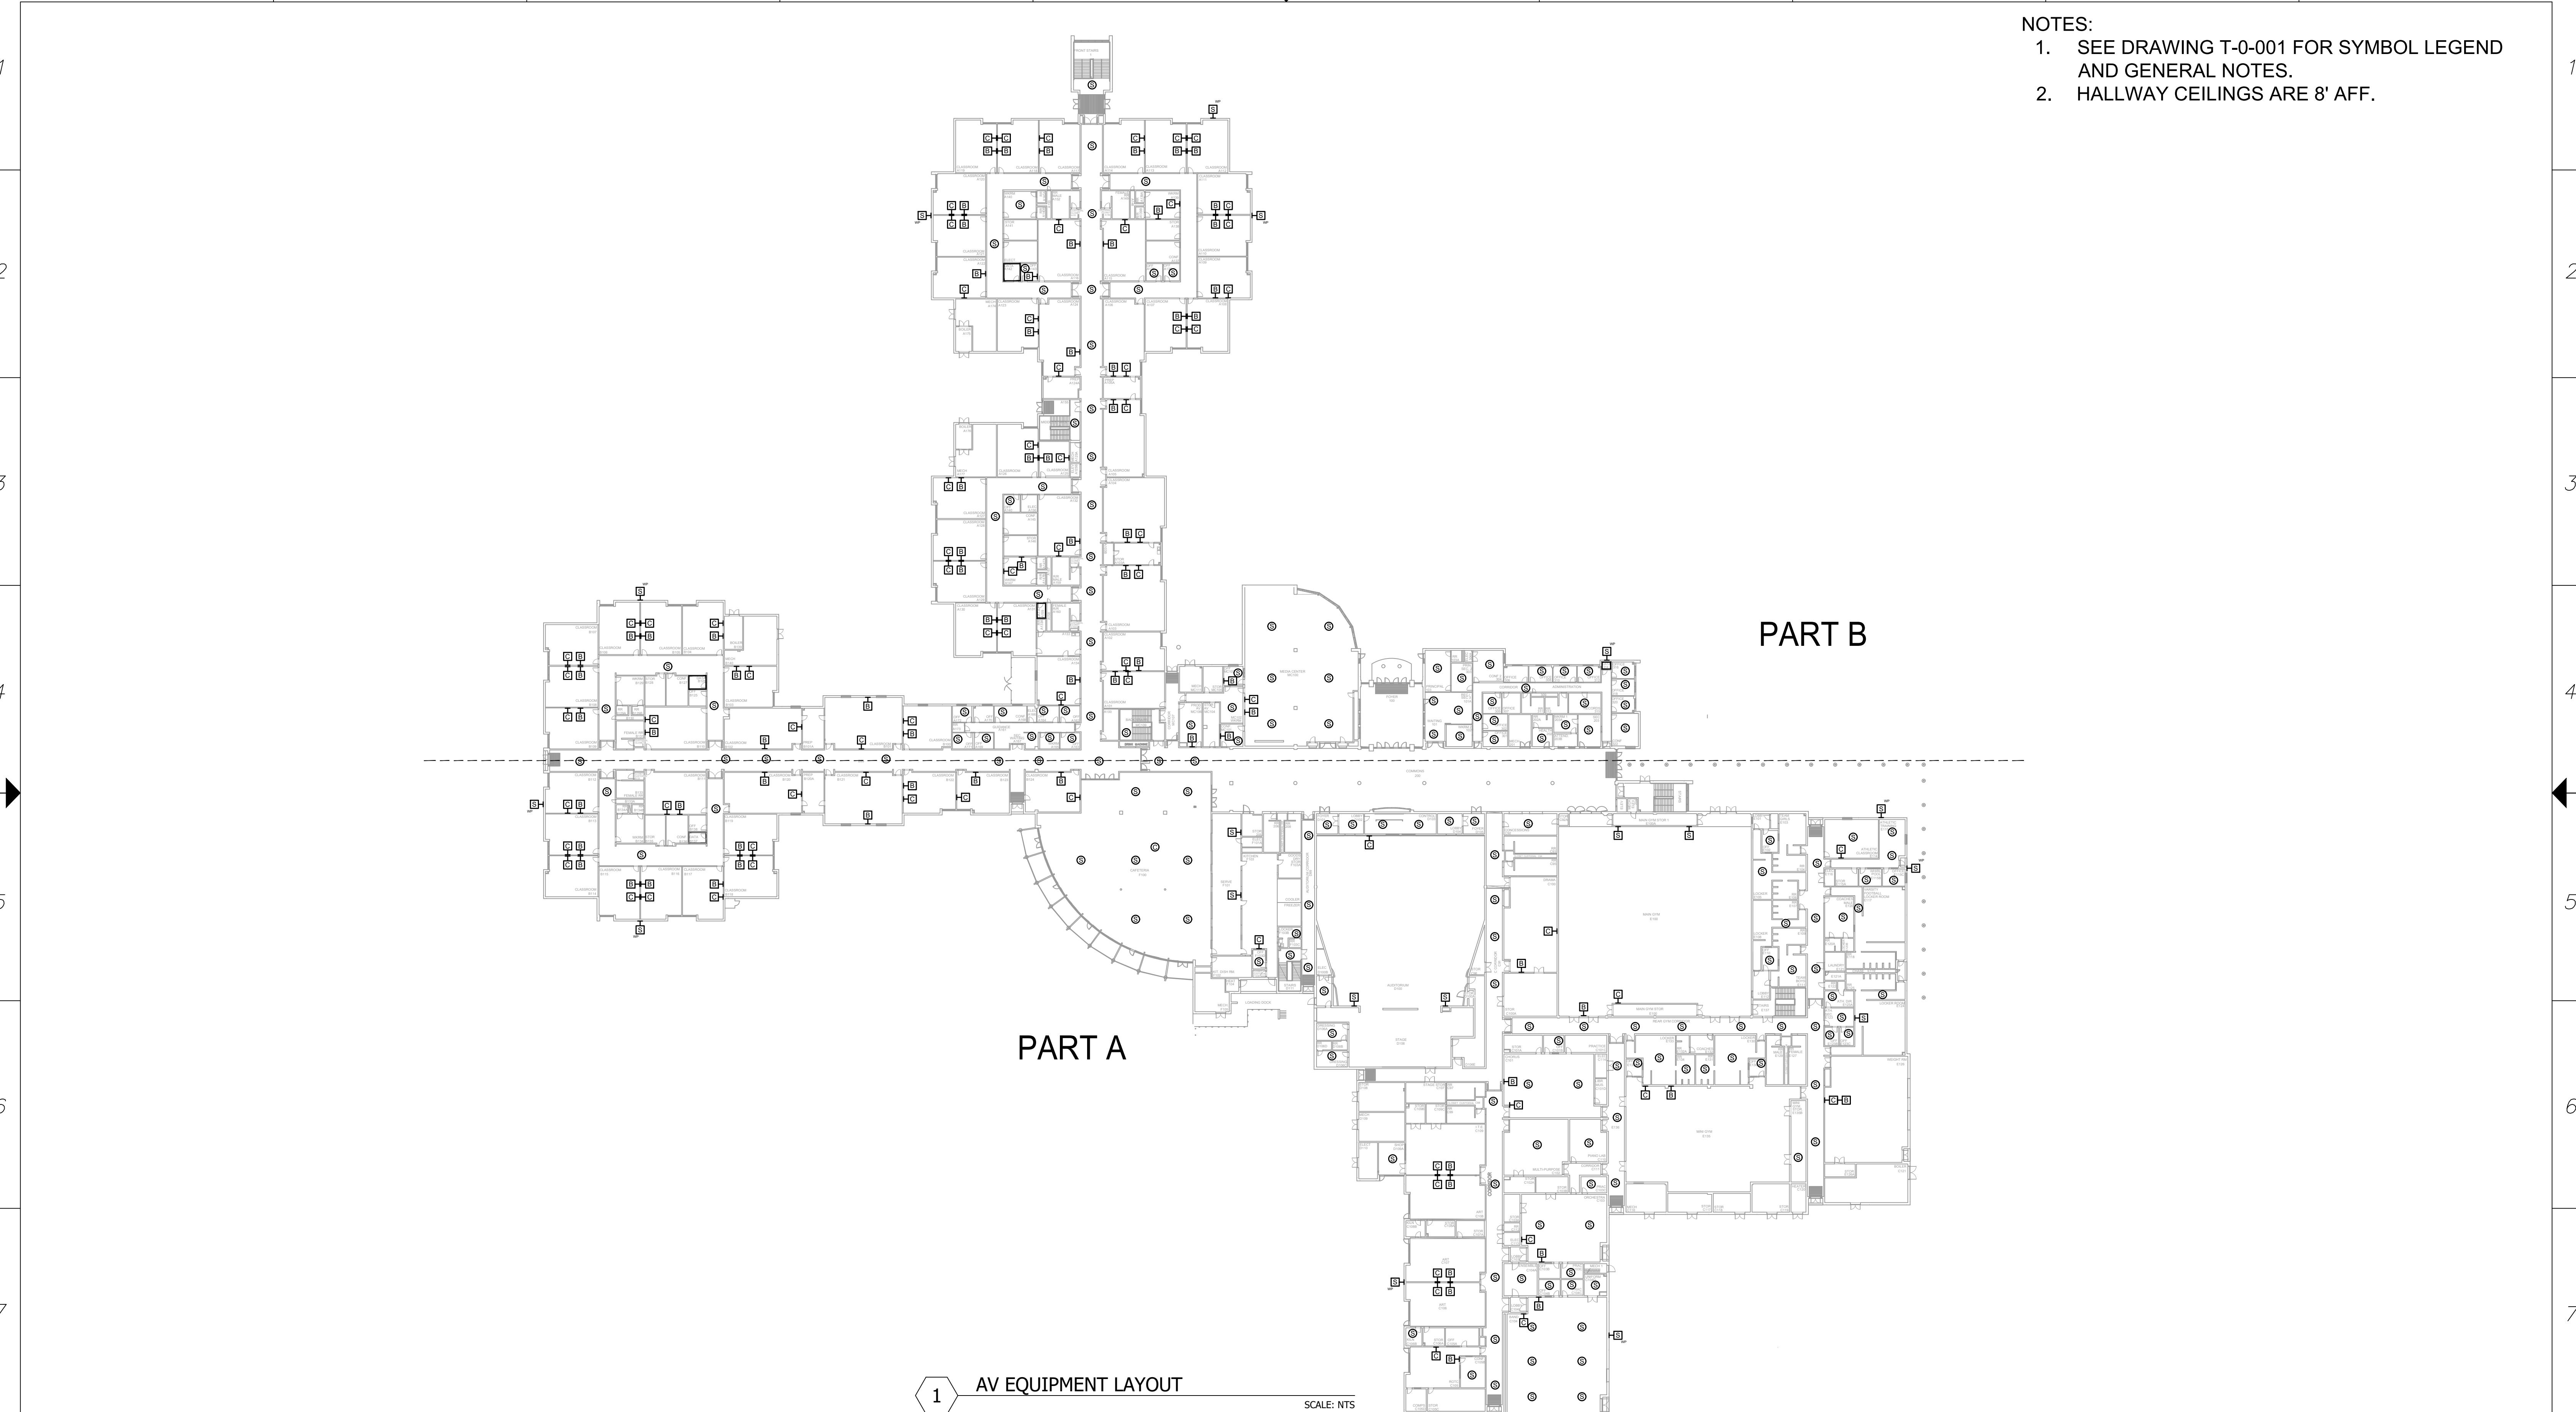

A B C D E F G H J K

NOTES:
1. SEE DRAWING T-0-001 FOR SYMBOL LEGEND AND GENERAL NOTES.

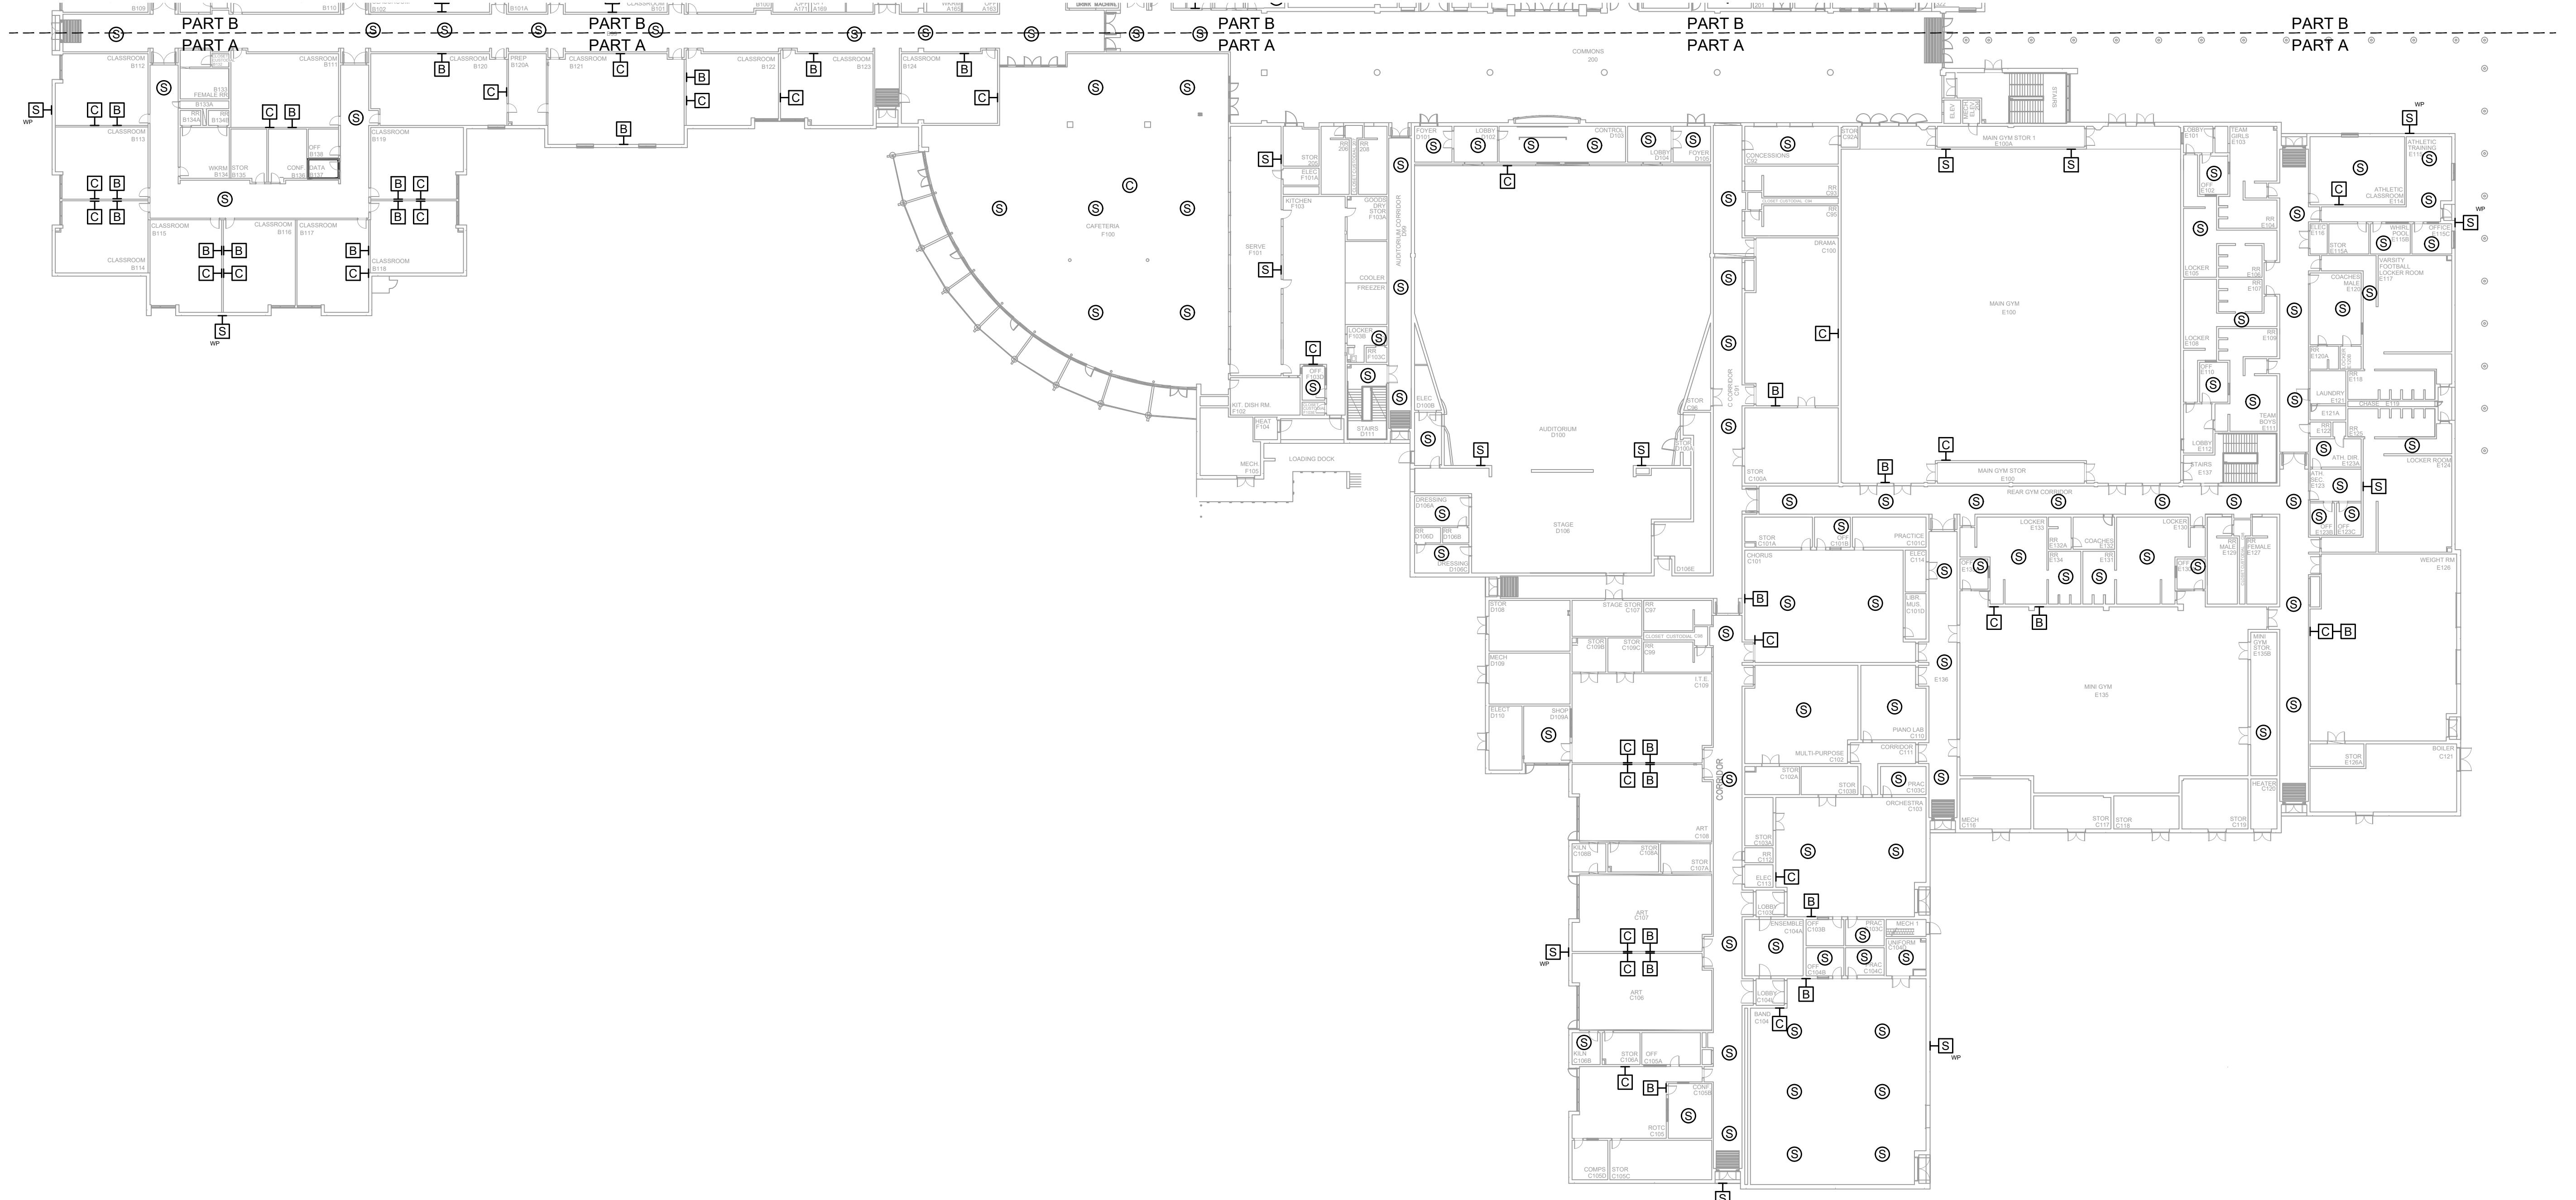

1 AV EQUIPMENT LAYOUT - PART A

SCALE: NTS



CLIENT LOGO

PROJECT INFO
ROCK HILL SCHOOLS
ROCK HILL, SC

SHEET INFO
INTERCOM & NOTIFICATIONS
SOUTH POINT HS - 1ST FLR PART A -
NEW DEVICES


REVISIONS			ENGINEER APPROVAL	ENGINEER WM	DRAWING NAME TA-1-30-101N
REV.	DESCRIPTION	DATE			
				CAD AK	PROJECT NUMBER AR20245
				PROJECT MANAGER SD	APPROVED DRAWING DATE 07-23-2021
					RELEASE NUMBER 1

A B C D E F G H J K

A | *B* | *C* | *D* | *E* | *F* | *G* | *H* | *J* | *K*


NOTES:

1. SEE DRAWING T-0-001 FOR SYMBOL LEGEND AND GENERAL NOTES.

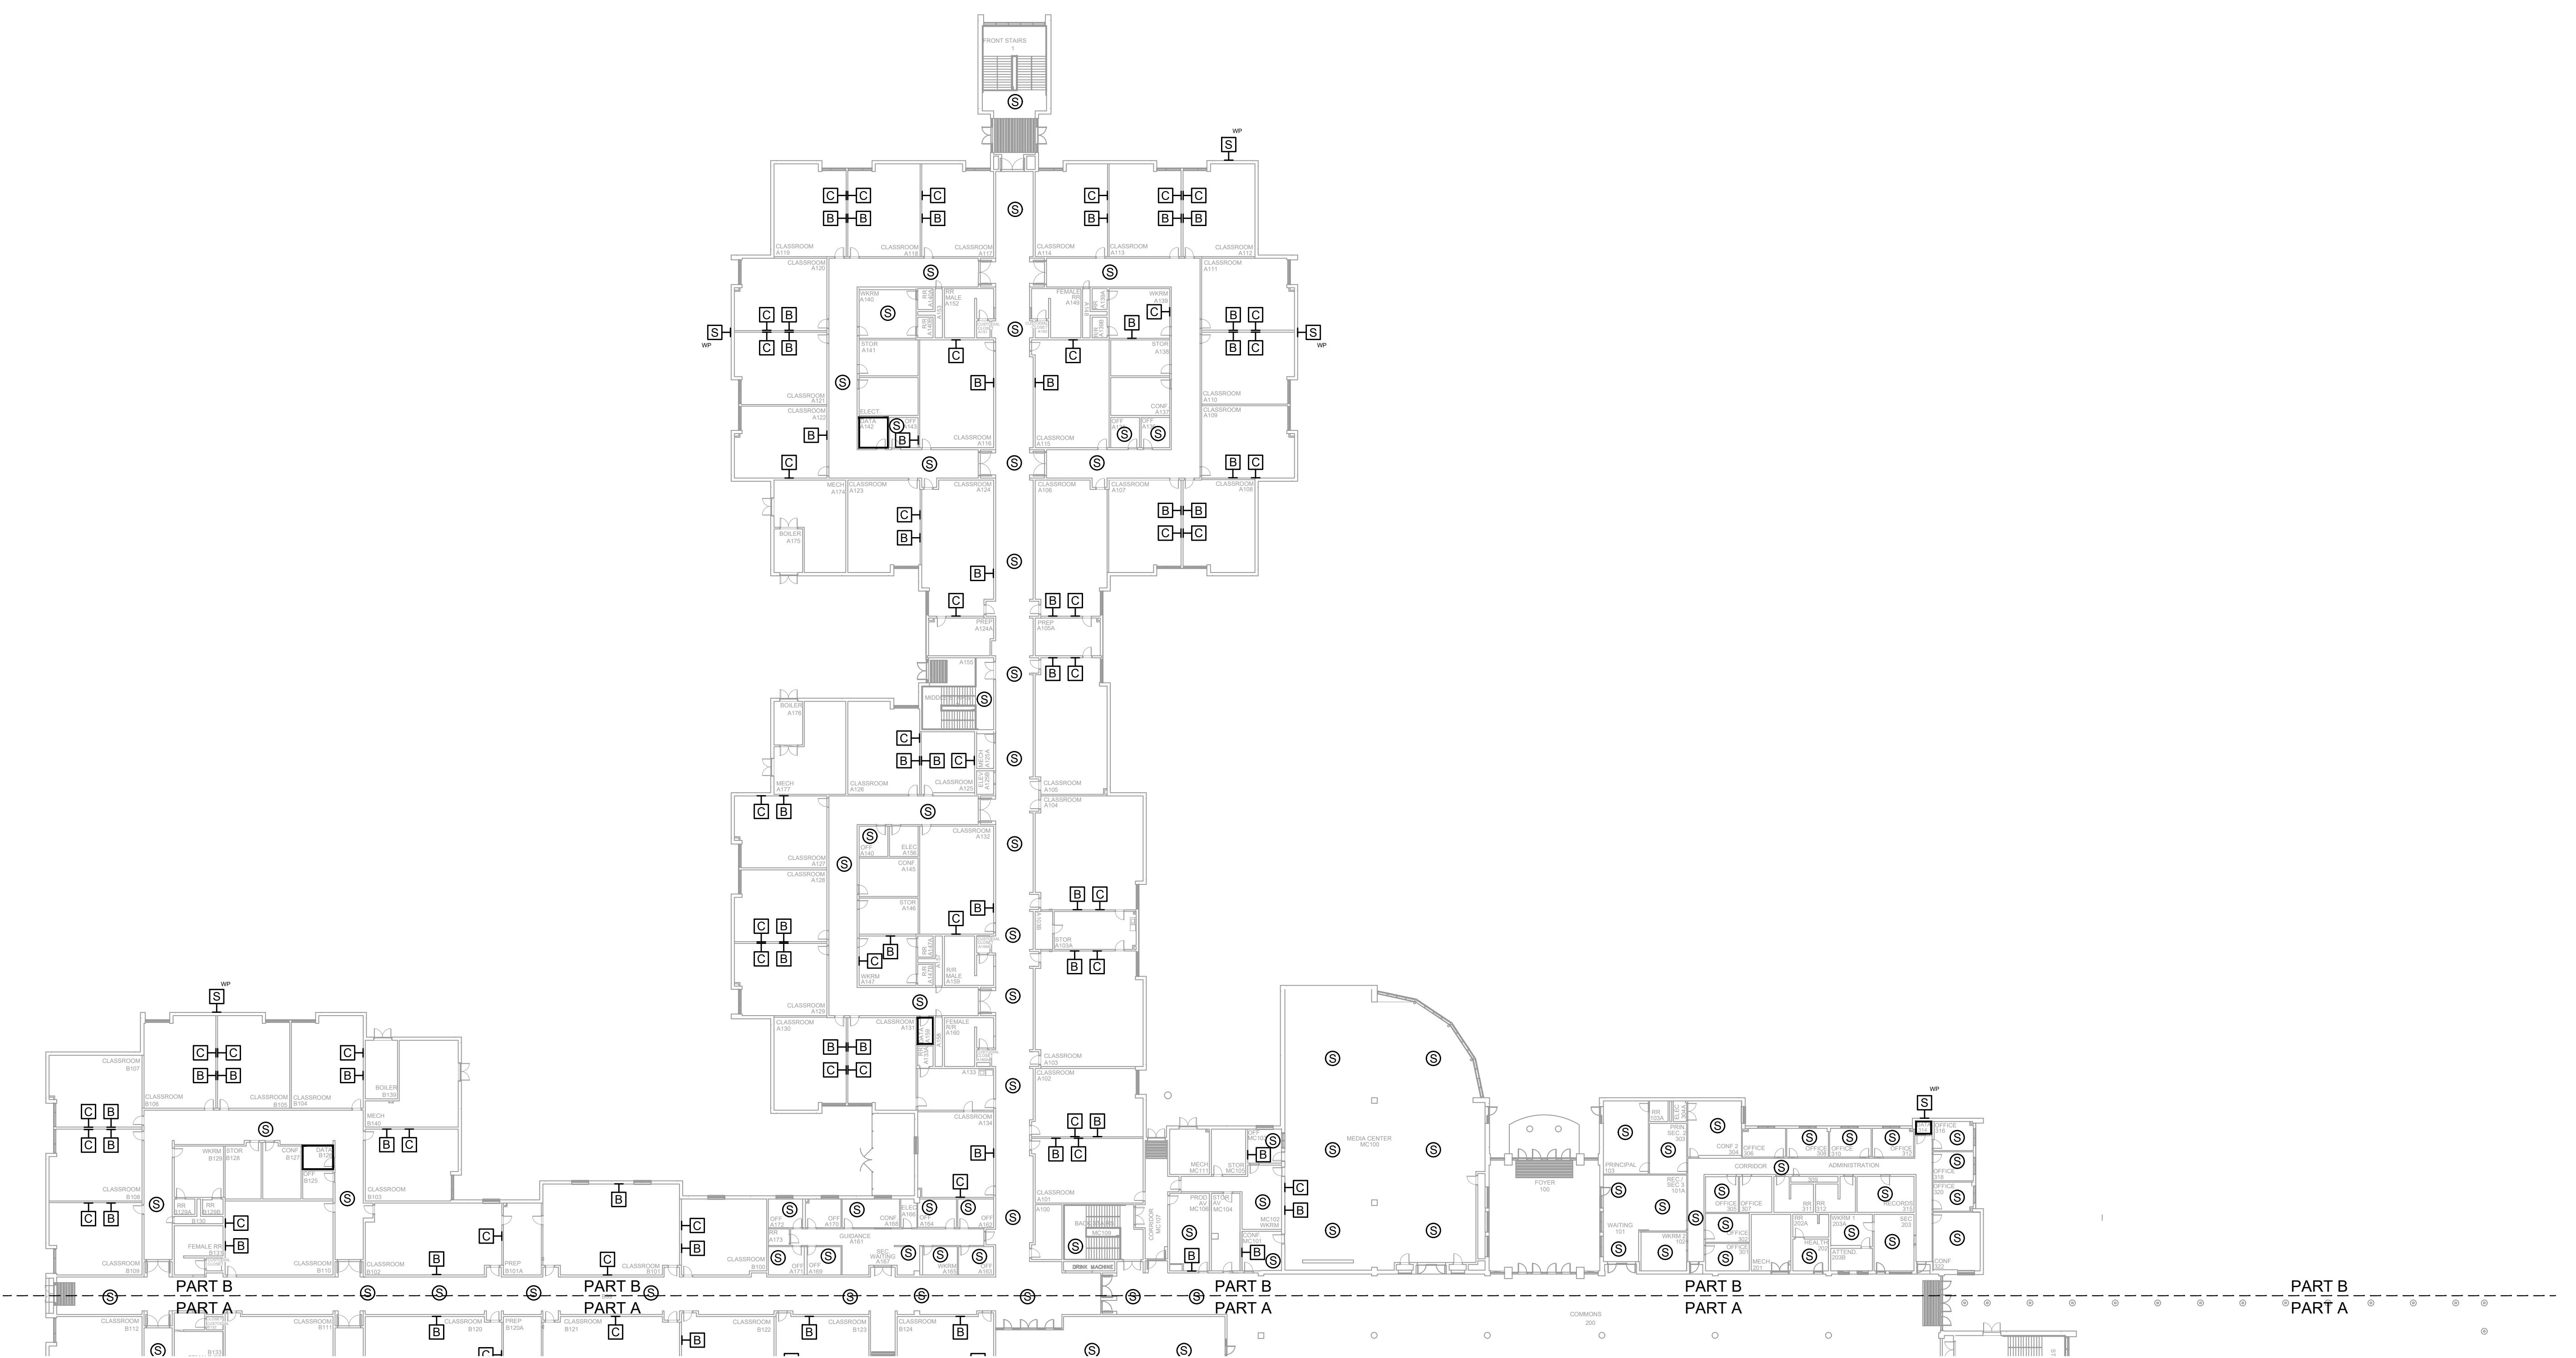

AV EQUIPMENT LAYOUT - PART B

SCALE: NTS

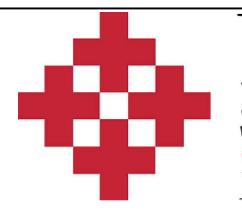

NetPlanner

S Y S T E M S, I N C.[®]
Your Pathway to Connectivity
662-5482 Augusta, GA 706-364-
290-8010 Columbus, GA 706-571-
795-1975 Savannah, GA 912-748-
www.netplanner.com

CLIENT LOGO



PROJECT INFO

ROCK HILL SCHOOLS ROCK HILL, SC


SHEET INFO
INTERCOM & NOTIFICATIONS
SOUTH POINT HS - 1ST FLR PART B -
NEW DEVICES

REVISIONS		
REV.	DESCRIPTION	DATE

**ENGINEER
APPROVAL**

ENGINEERING
WM
CAD
AK
PROJECT
SD

R	DRAWING NAME TA-1-30-102N
	PROJECT NUMBER AR20245
MANAGER	APPROVED DRAWING DATE 07-23-2021

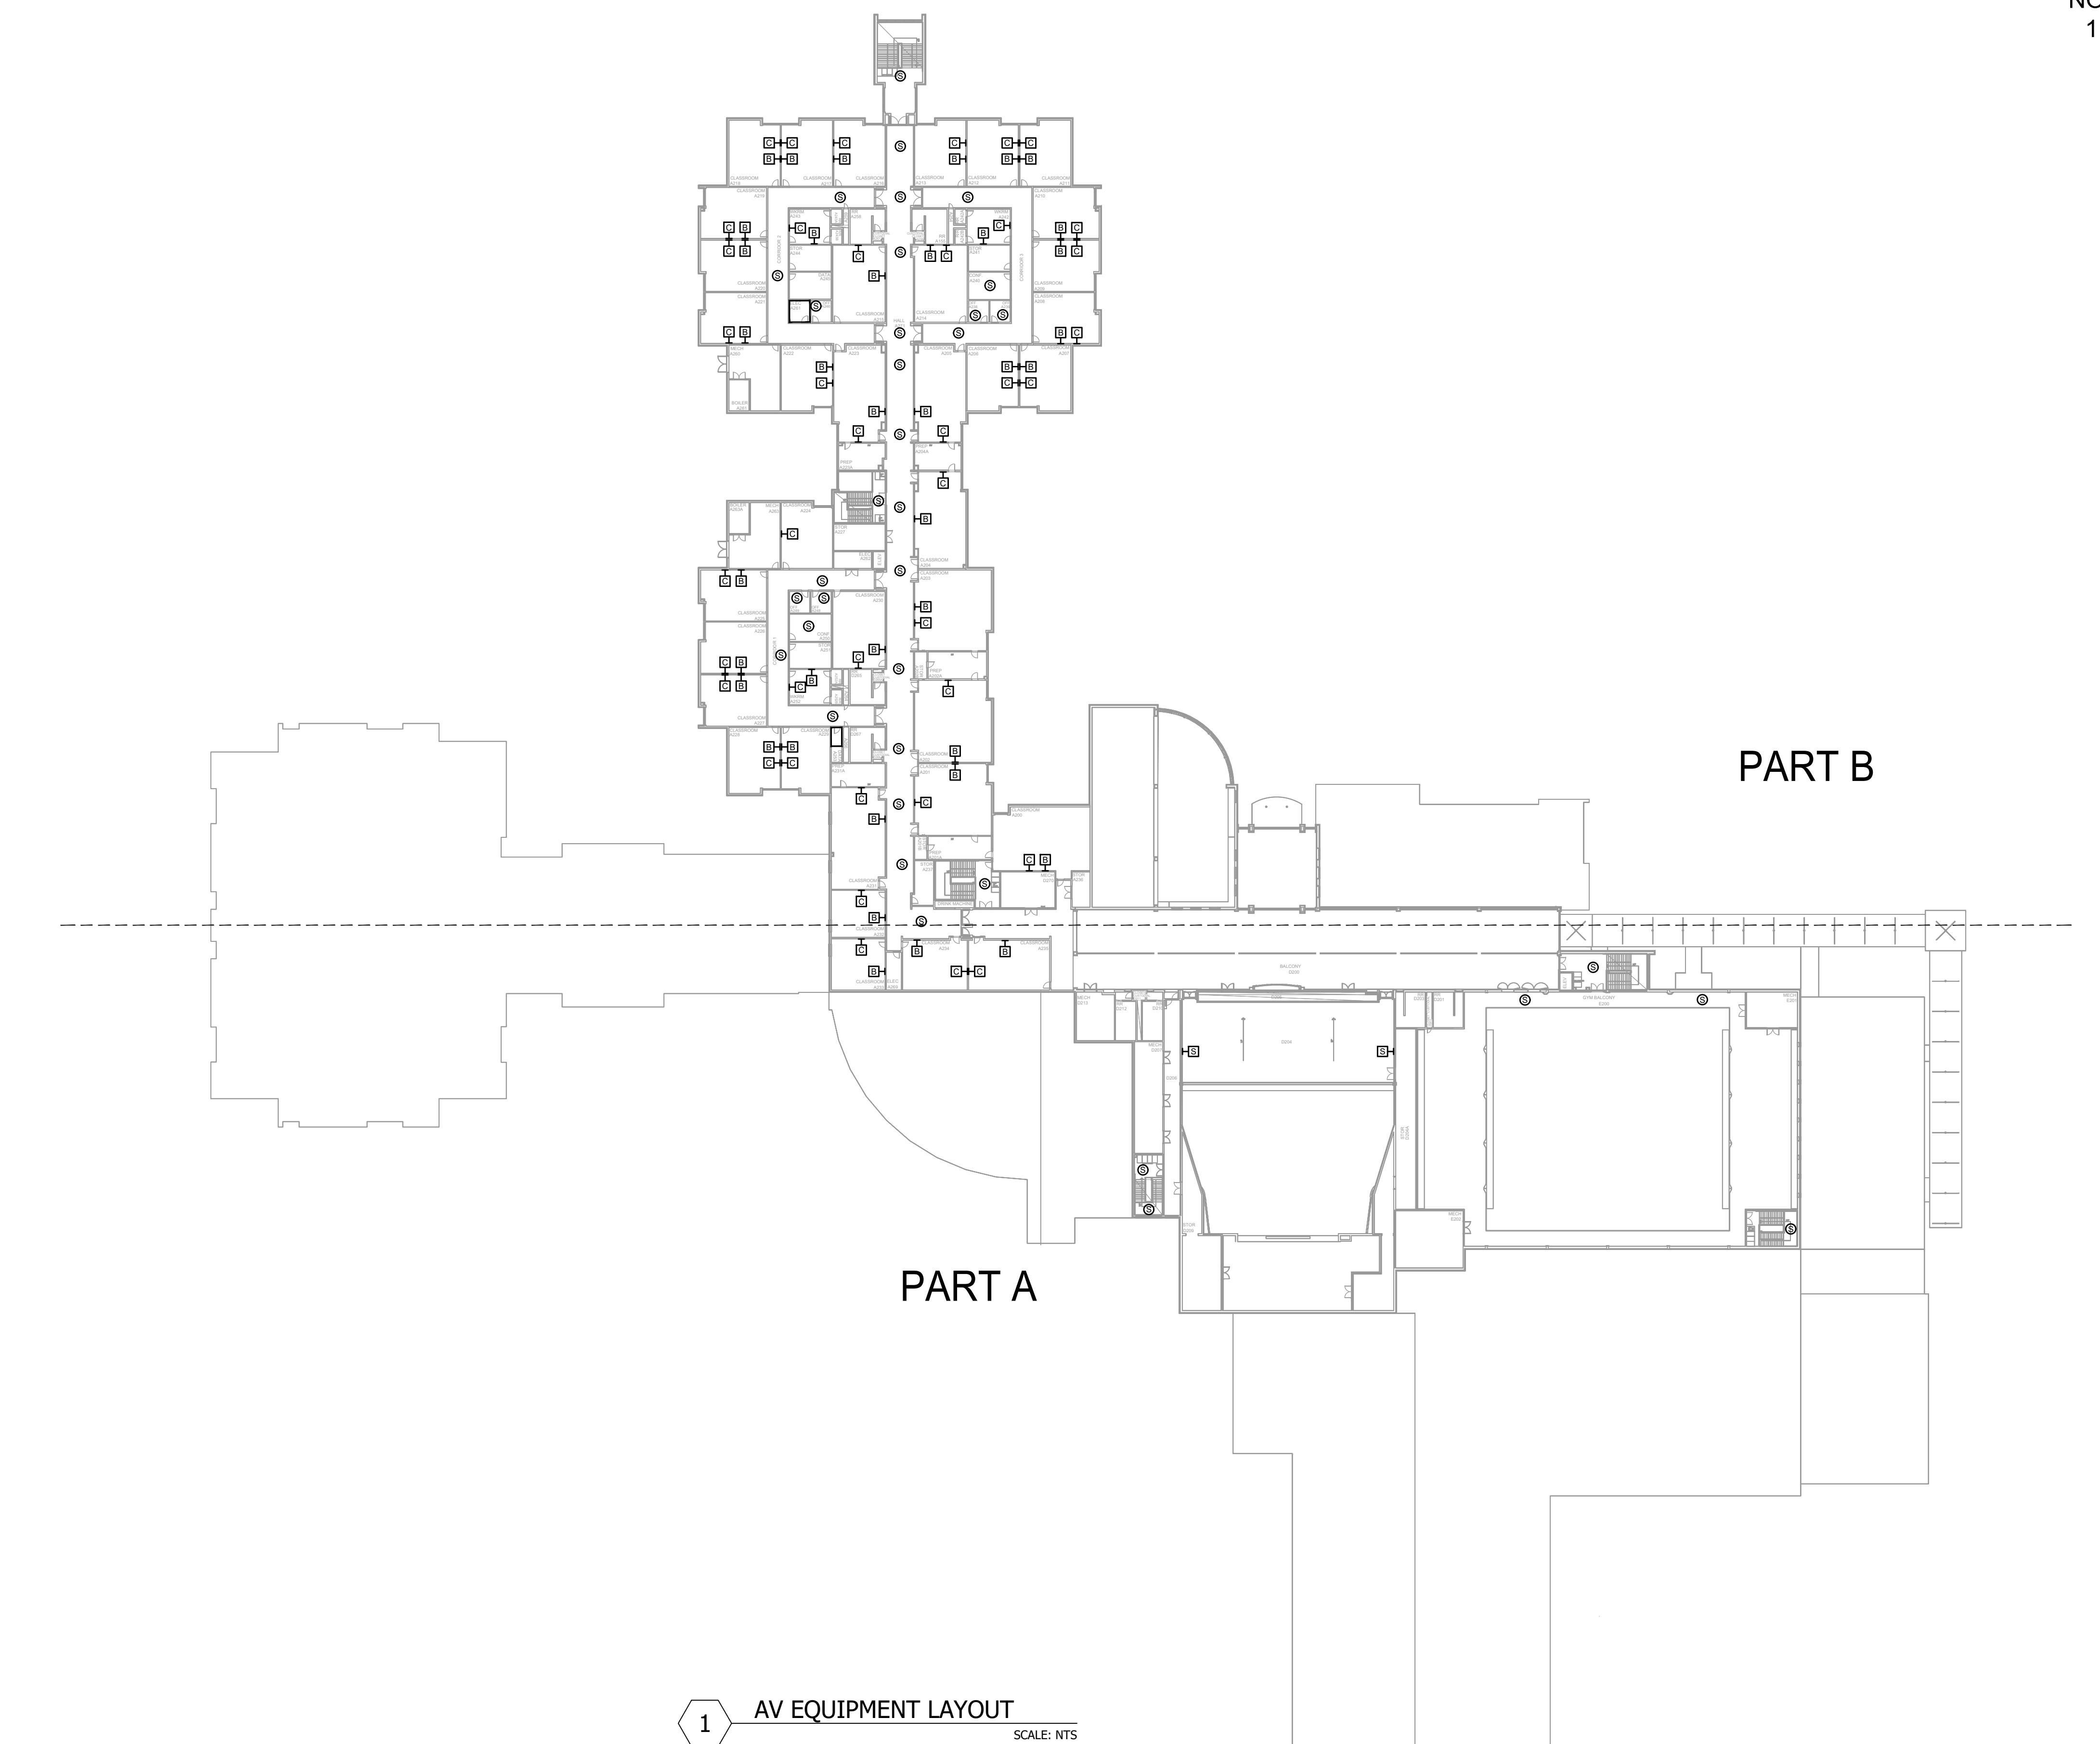

NOTES:

1. SEE DRAWING T-0-001 FOR SYMBOL LEGEND AND GENERAL NOTES.



Your Pathway to Connectivity

Atlanta, GA	770-662-5482	Augusta, GA	706-364-4190
Raleigh, NC	919-290-8010	Columbus, GA	706-571-9090
Toll Free	800-795-1975	Savannah, GA	912-748-8960

www.netplanner.com

CLIENT LOG

PROJECT INFO

ROCK HILL SCHOOLS ROCK HILL, SC

SHEET INFO

INTERCOM & NOTIFICATIONS


SOUTH POINT HS - 2ND FLR OVERALL -

NEW DEVICES

REVISIONS			ENGINEER APPROVAL	ENGINEER WM	DRAWING NAME
REV.	DESCRIPTION	DATE			TA-1-30-200N
				CAD AK	PROJECT NUMBER
					AR20245
				PROJECT MANAGER SD	APPROVED DRAWING DATE
					07-23-2021
					RELEASE NUMBER
					1

A B C D E F G H J K

NOTES:
1. SEE DRAWING T-0-001 FOR SYMBOL LEGEND
AND GENERAL NOTES.

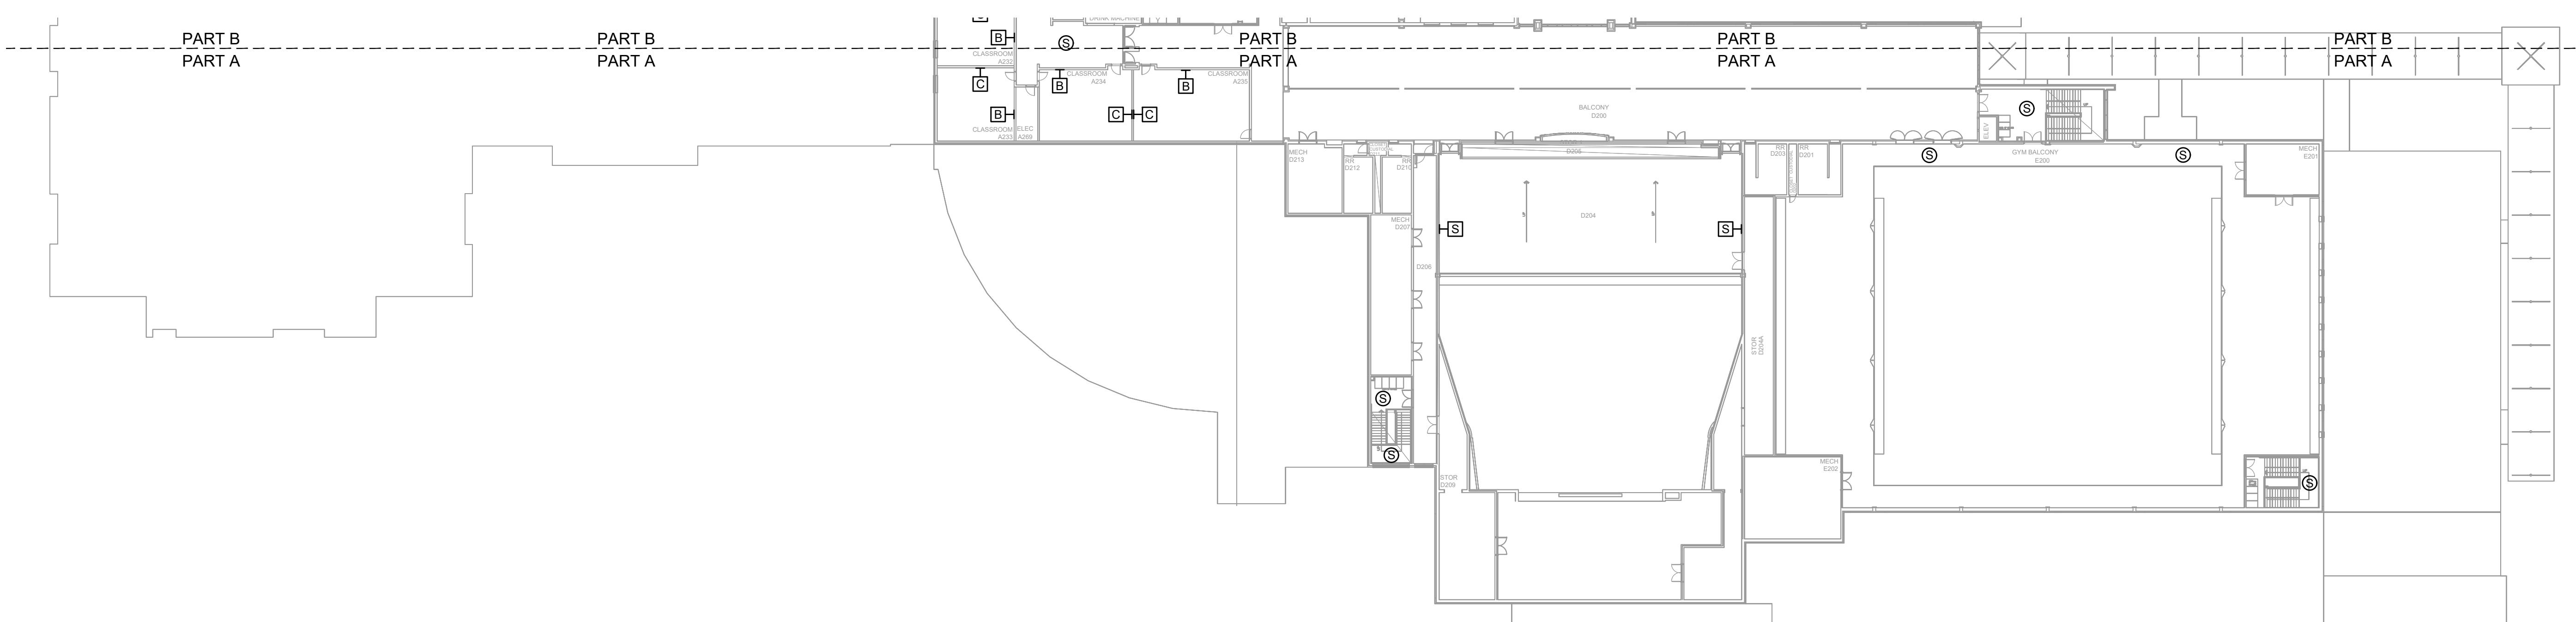

AV EQUIPMENT LAYOUT - PART A

SCALE: NTS



CLIENT LOGO

PROJECT INFO
ROCK HILL SCHOOLS
ROCK HILL, SC

SHEET INFO
INTERCOM & NOTIFICATIONS
SOUTH POINT HS - 2ND FLR PART A -
NEW DEVICES


REV.	DESCRIPTION	DATE	REVISIONS	
			ENGINEER APPROVAL	ENGINEER DRAWING NAME
			WM	TA-1-30-201N
			CAD	PROJECT NUMBER
			AK	AR20245
			SD	PROJECT MANAGER APPROVED DRAWING DATE RELEASE NUMBER
				07-23-2021 1

PROJECT NUMBER	APPROVED DRAWING DATE	RELEASE NUMBER
AR20245	07-23-2021	1

A B C D E F G H J K

A B C D E F G H J K

NOTES:
1. SEE DRAWING T-0-001 FOR SYMBOL LEGEND AND GENERAL NOTES.

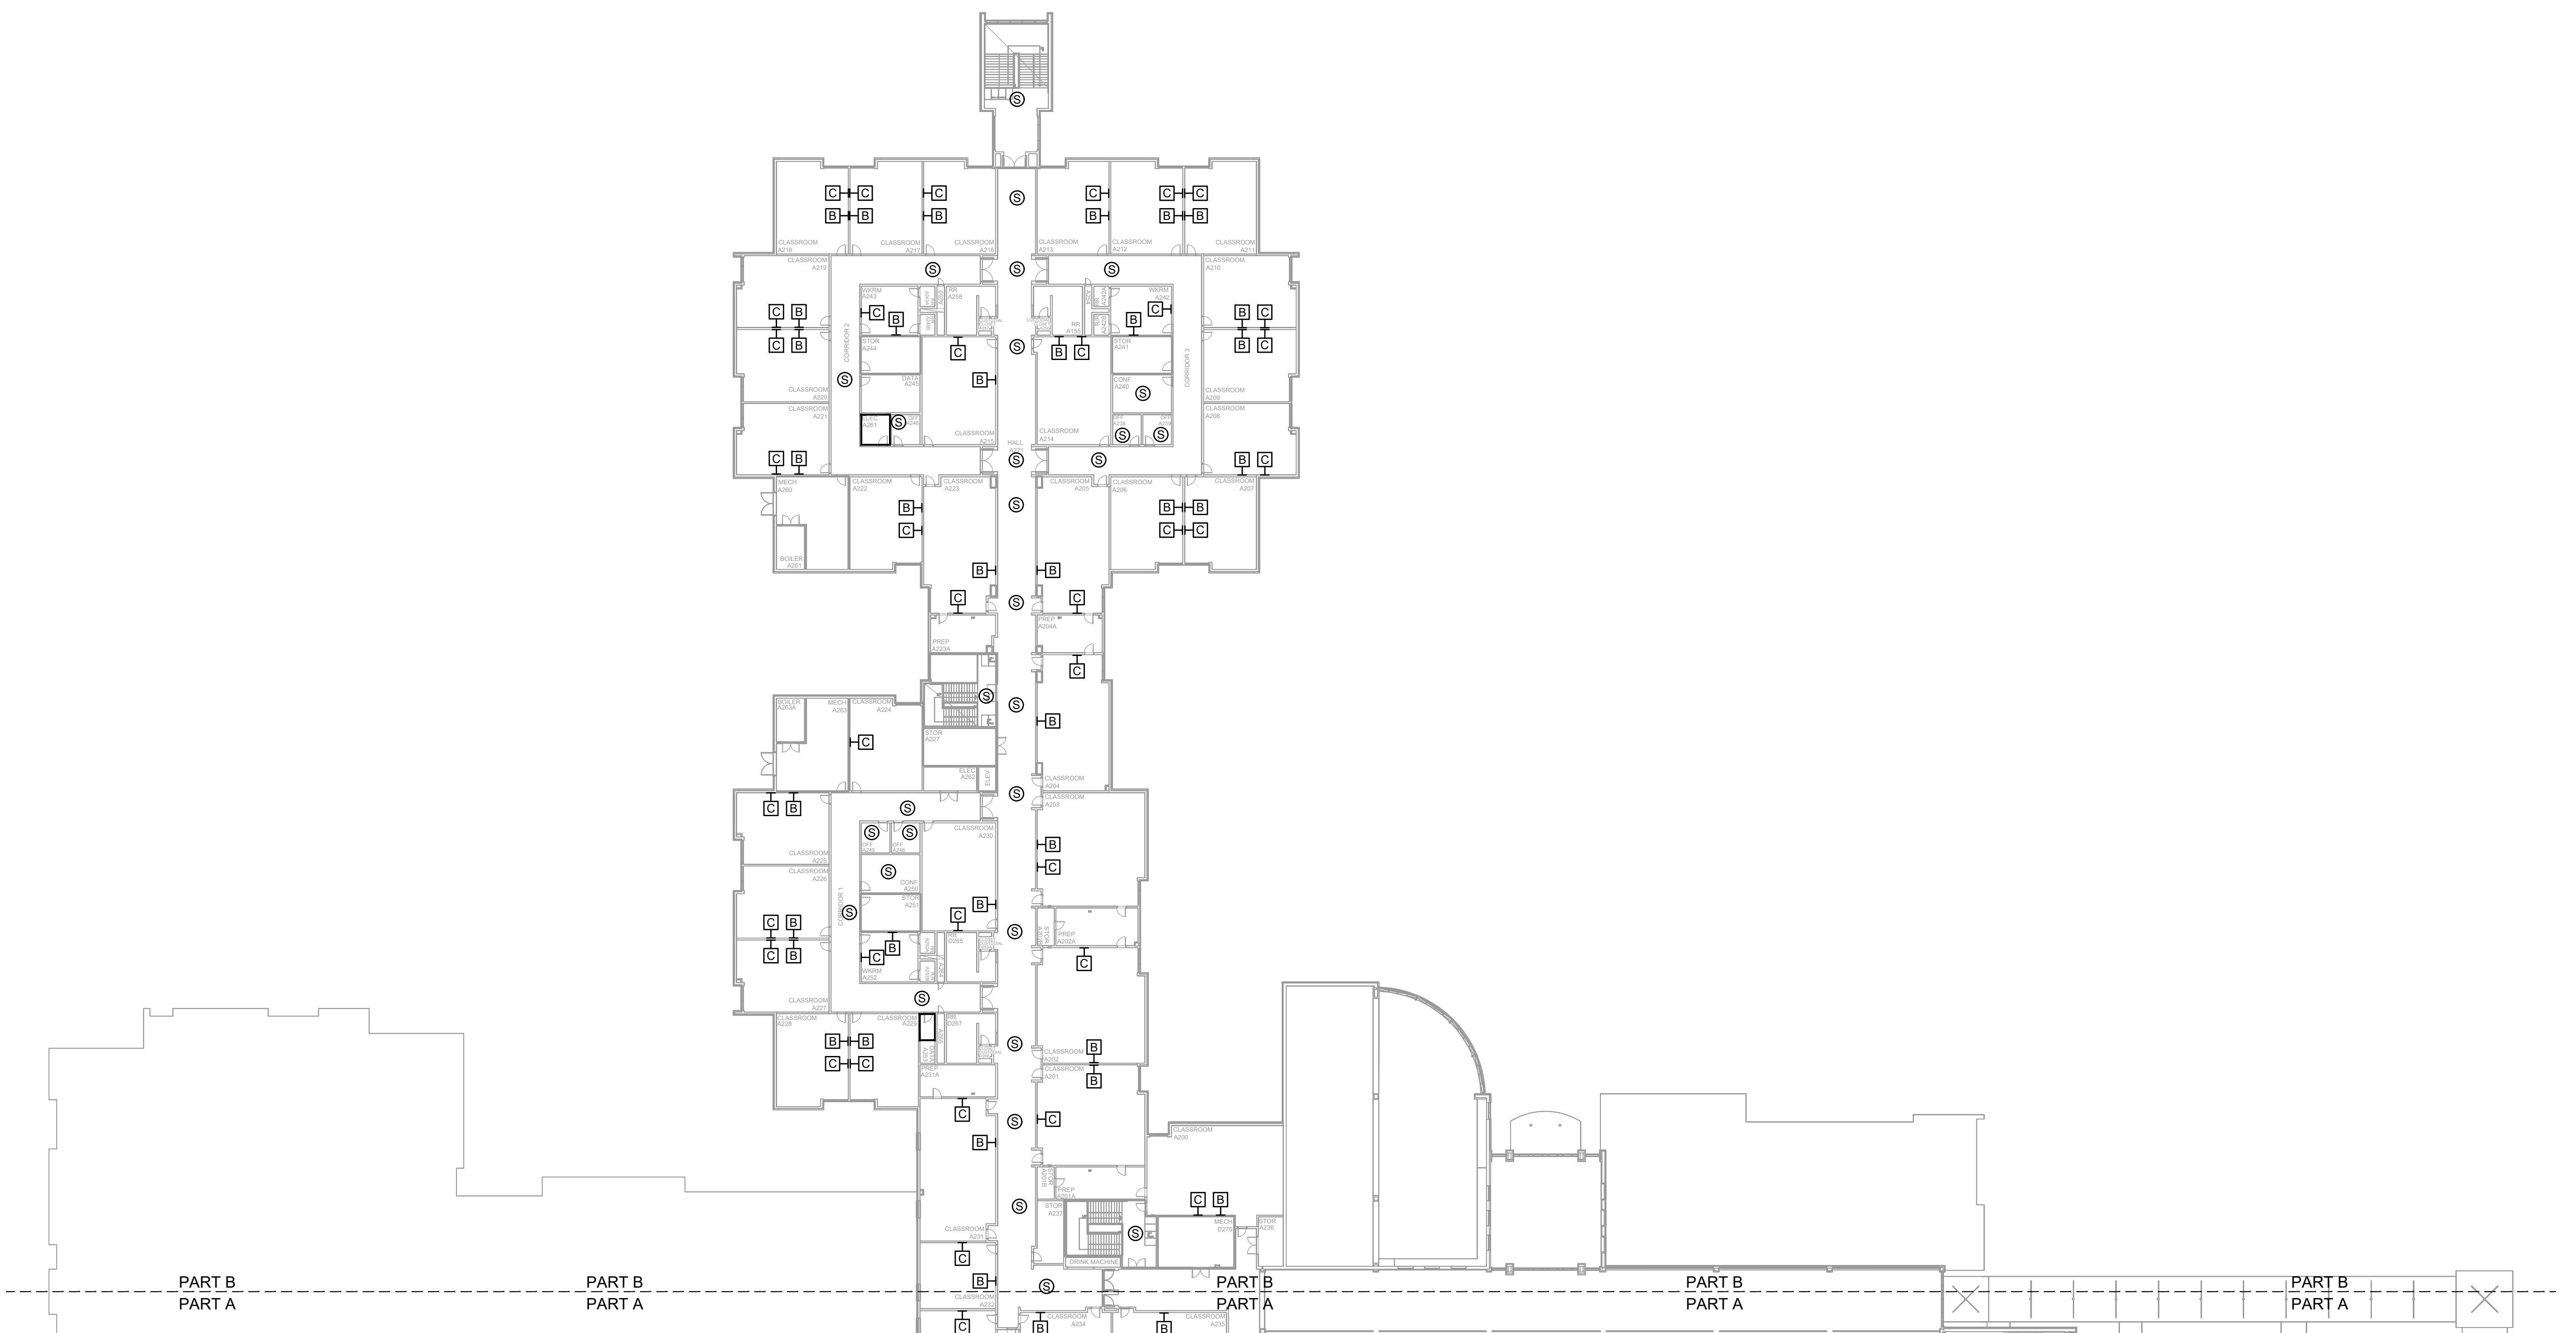


AV EQUIPMENT LAYOUT - PART B

SCALE: NTS


REV.	DESCRIPTION	DATE	REVISIONS	
			ENGINEER APPROVAL	DRAWING NAME
			WM	TA-1-30-202N
			CAD	PROJECT NUMBER
			AK	AR20245
			SD	PROJECT MANAGER
				APPROVED DRAWING DATE
				07-23-2021
				RELEASE NUMBER
				1


NOTES:
 1. SEE DRAWING T-0-001 FOR SYMBOL LEGEND AND GENERAL NOTES.
 2. HALLWAY CEILINGS ARE 8'-10' AFF.


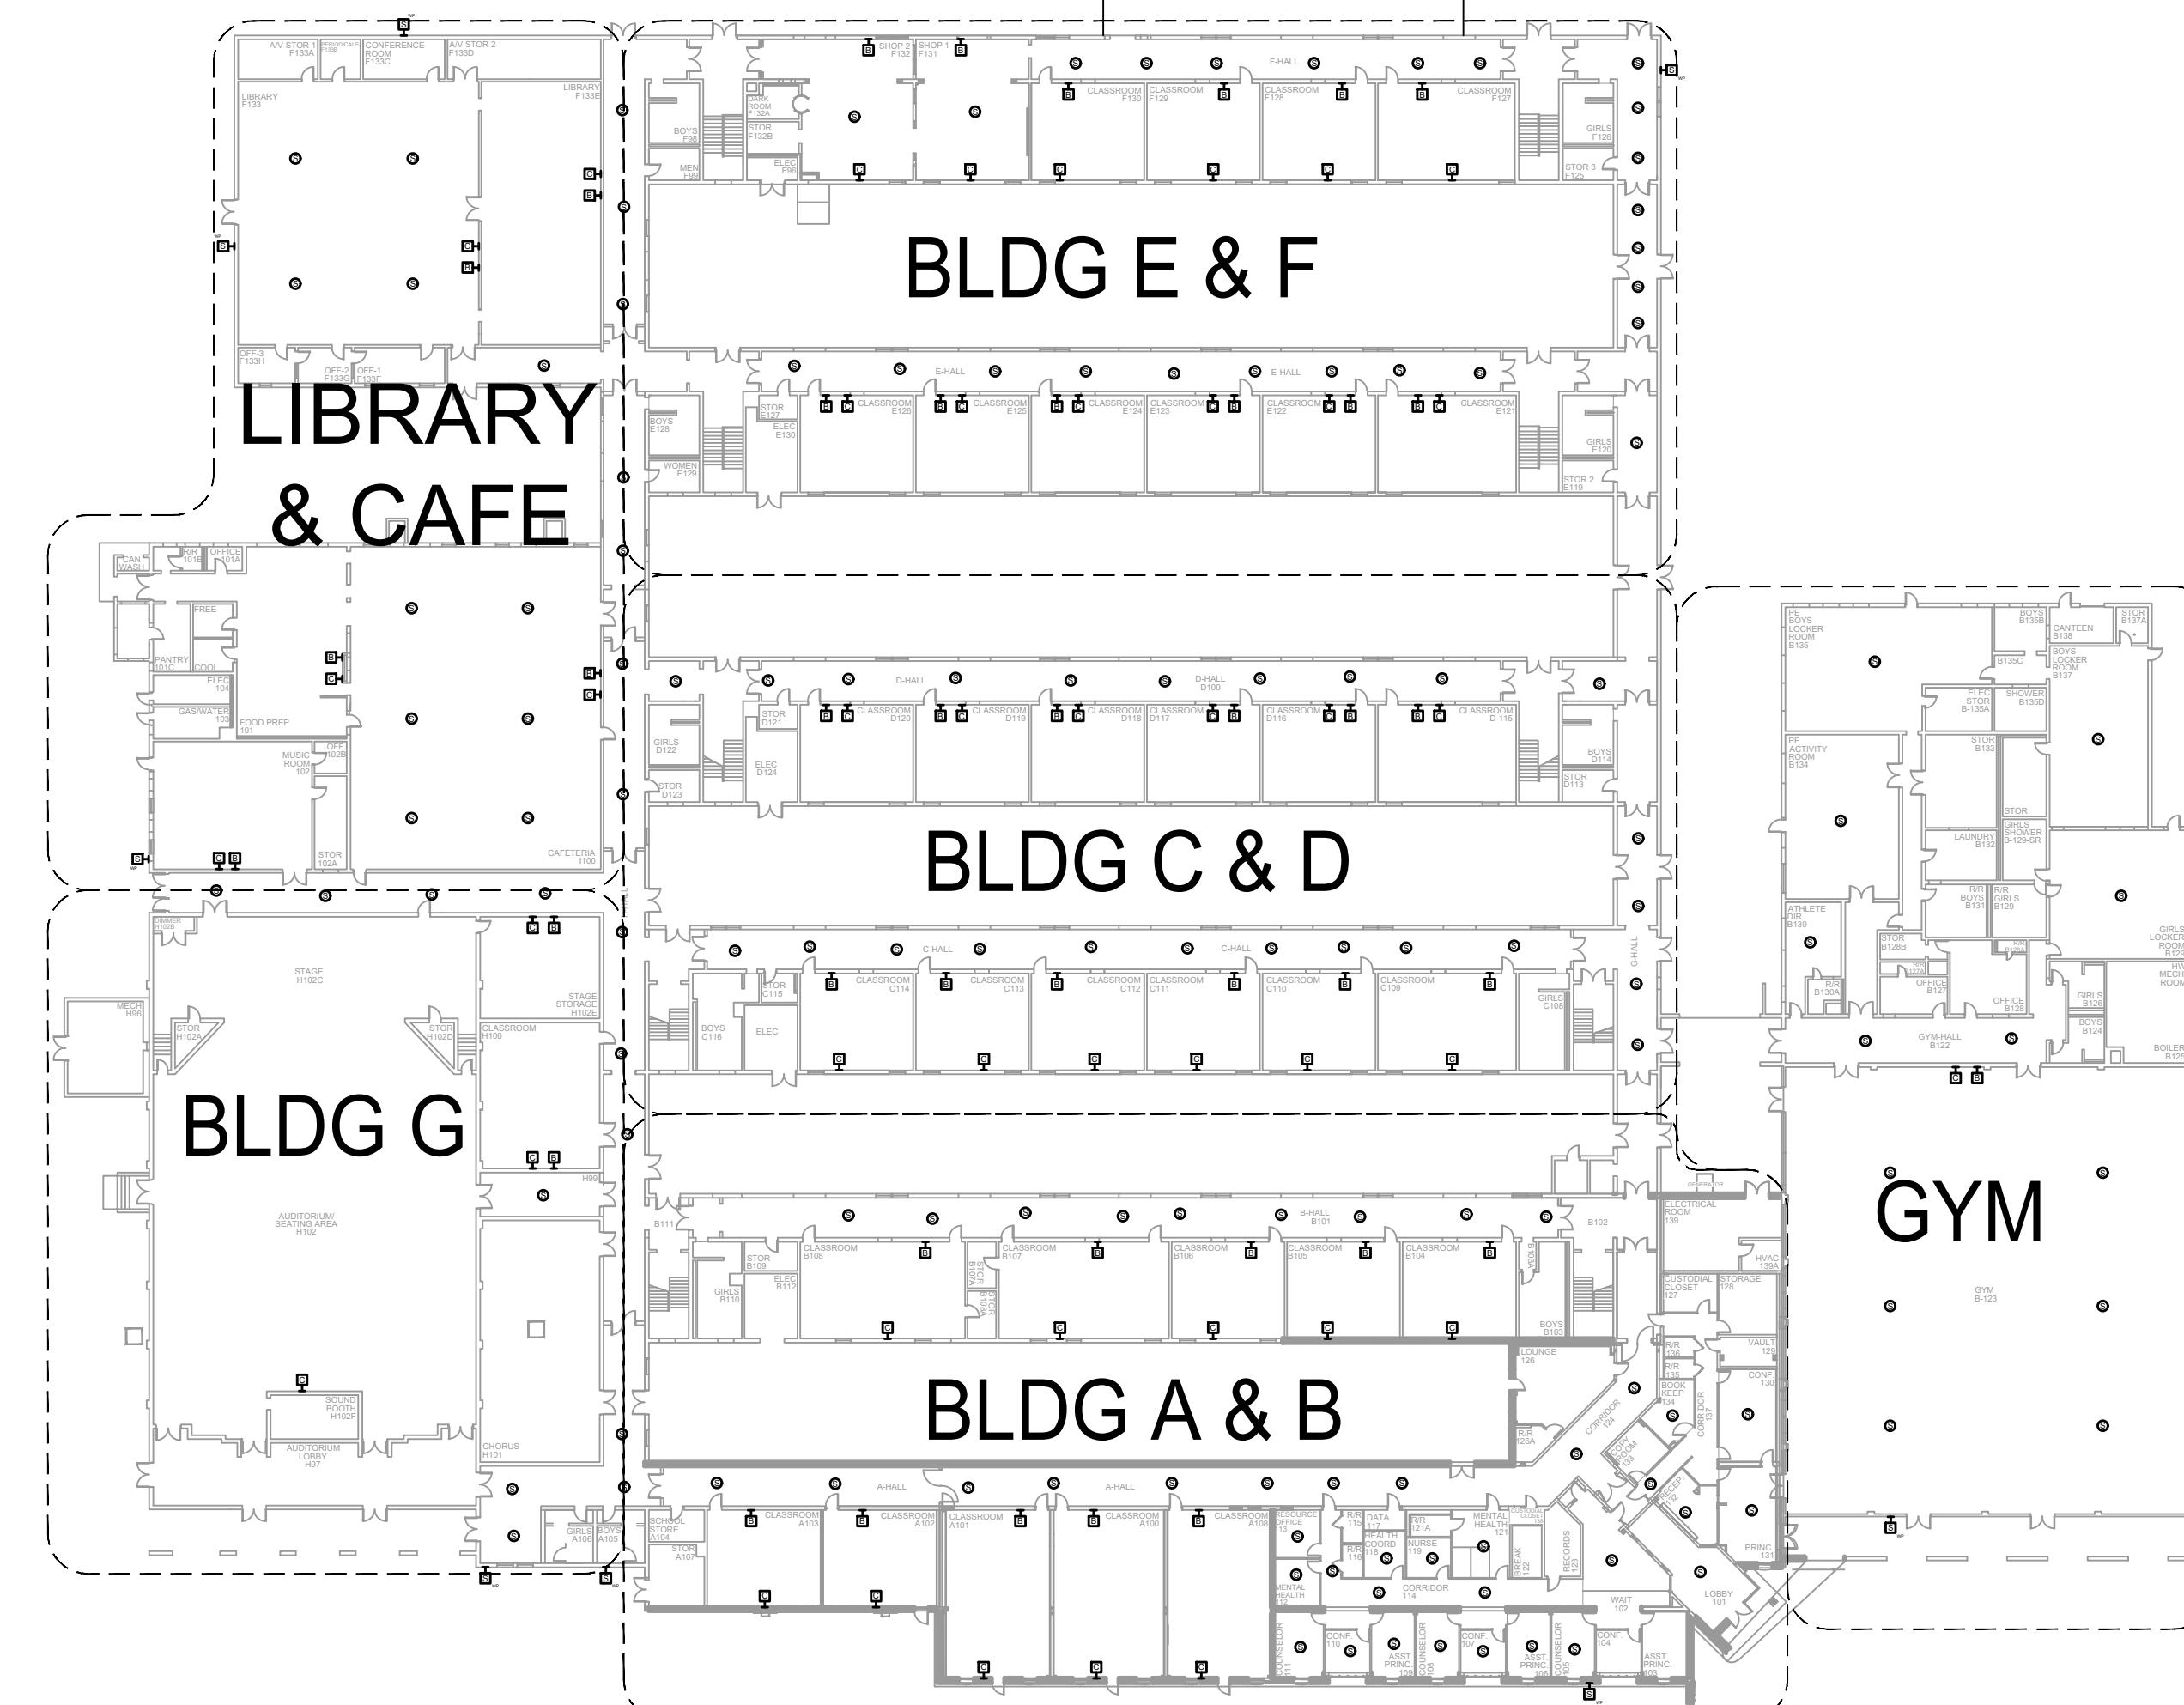


1 AV EQUIPMENT LAYOUT - OVERALL

SCALE: NTS

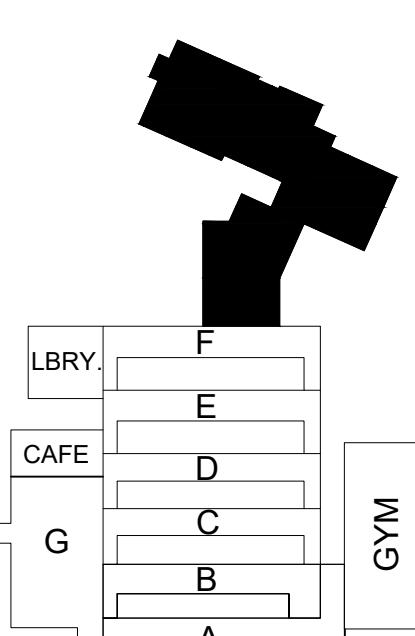

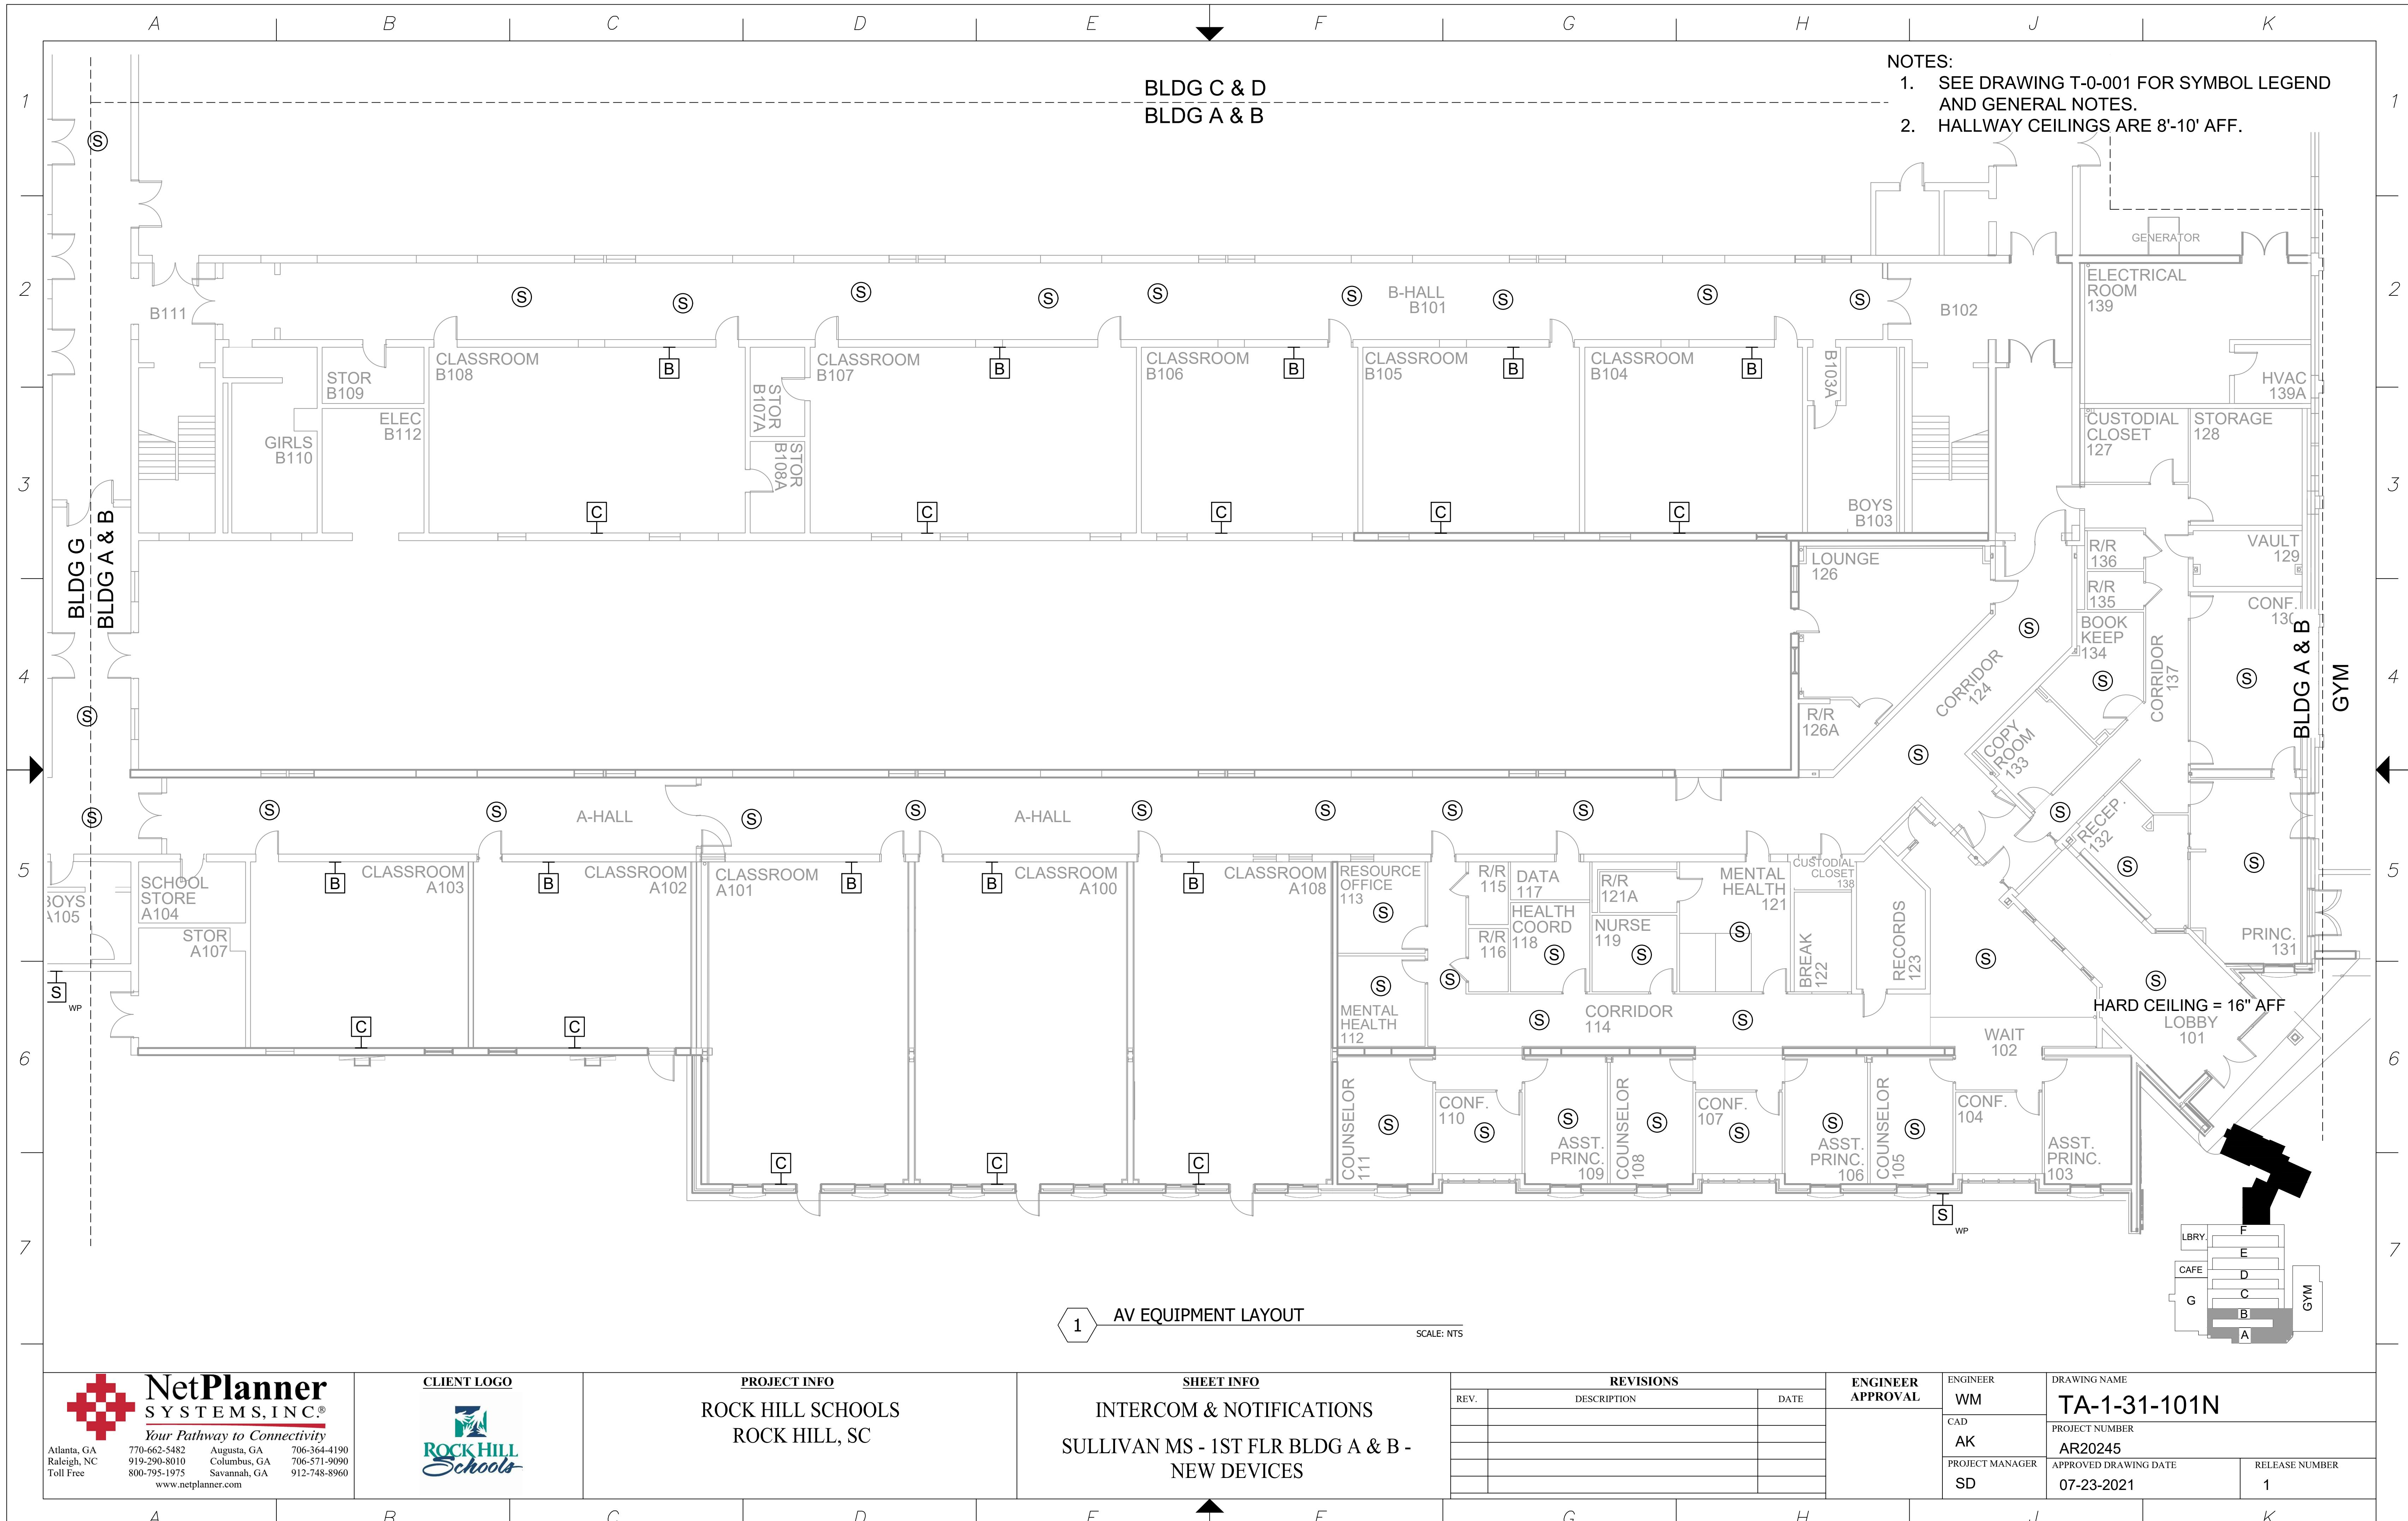

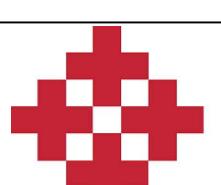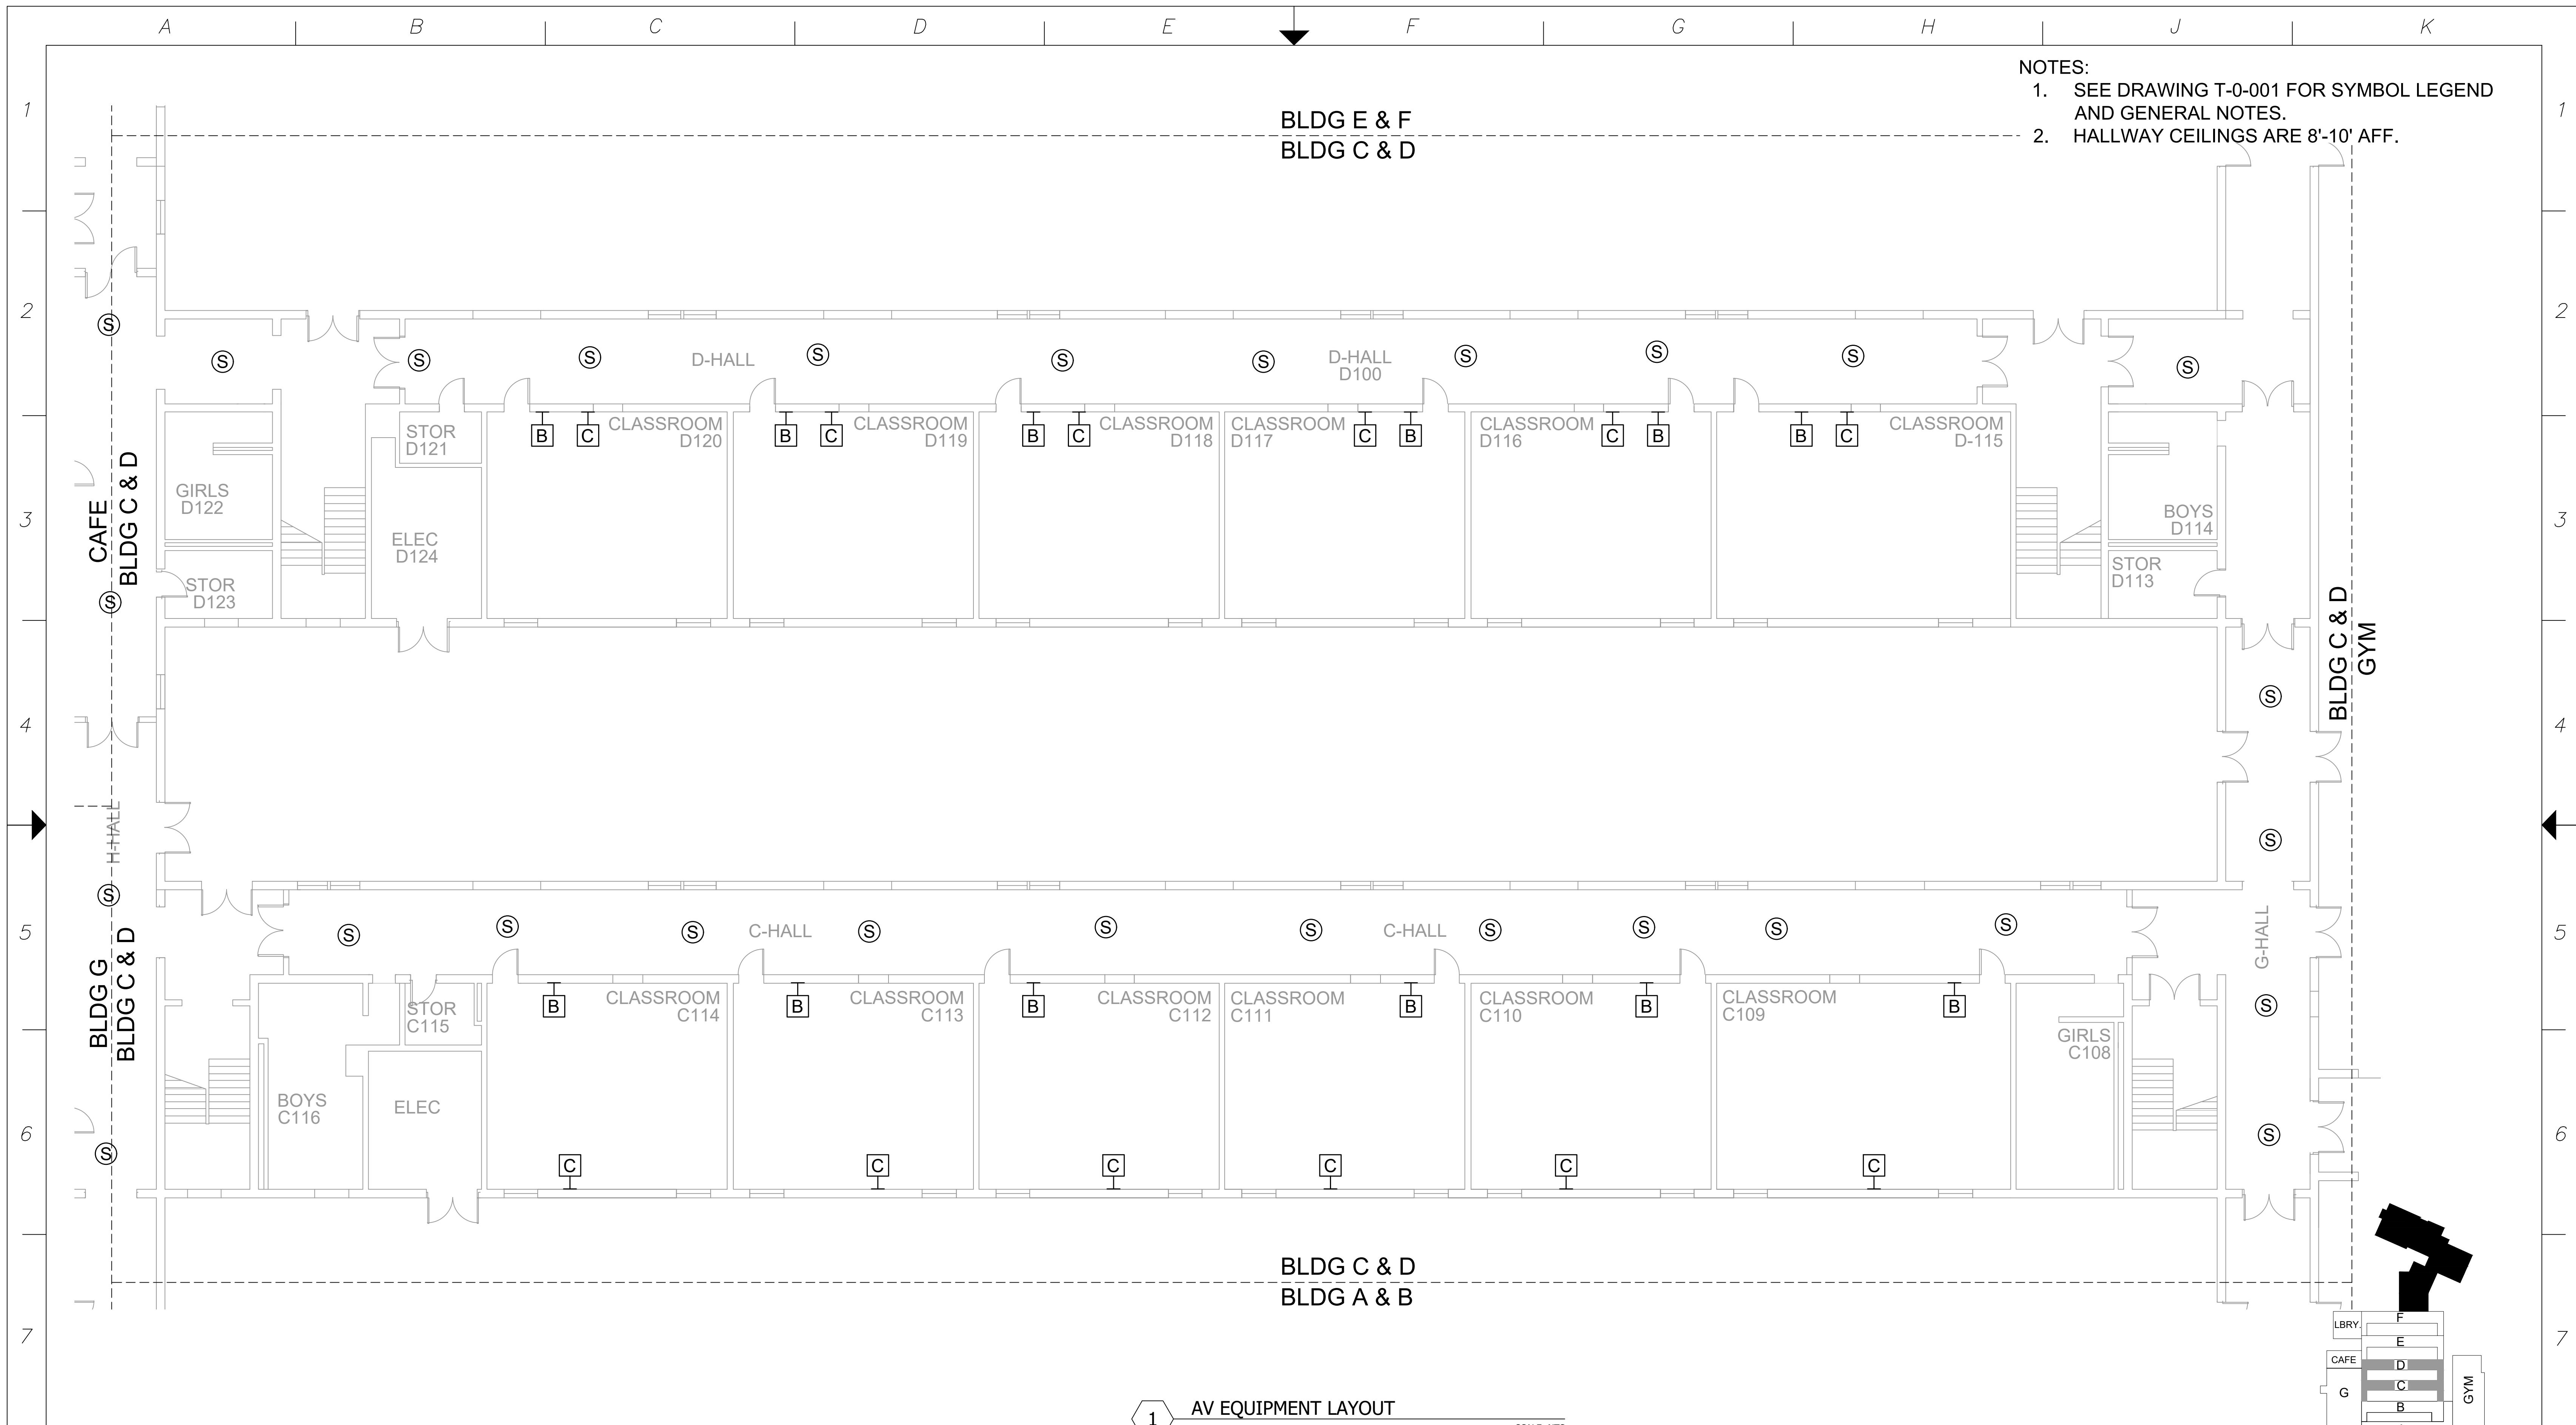

NetPlanner SYSTEMS, INC.[®]

Your Pathway to Connectivity
662-5482 Augusta, GA 706-364-
290-8010 Columbus, GA 706-571-
795-1975 Savannah, GA 912-748-
www.netplanner.com

CLIENT LOGO

PROJECT INFO

ROCK HILL SCHOOLS

ROCK HILL, SC


SHEET INFO

INTERCOM & NOTIFICATIONS

**SULLIVAN MS - 1ST FLR BLDG C & D -
NEW DEVICES**



NOTES:

1. SEE DRAWING T-0-001 FOR SYMBOL LEGEND AND GENERAL NOTES.
- 2. HALLWAY CEILINGS ARE 8'-10' AFF.

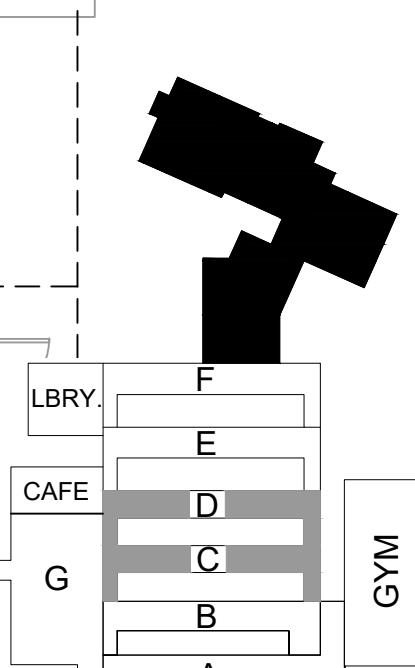



REFER TO CHERRY ELEMENTARY - 1ST FLOOR

NOTES:
 1. SEE DRAWING T-0-001 FOR SYMBOL LEGEND AND GENERAL NOTES.
 2. HALLWAY CEILINGS ARE 8'-10' AFF.

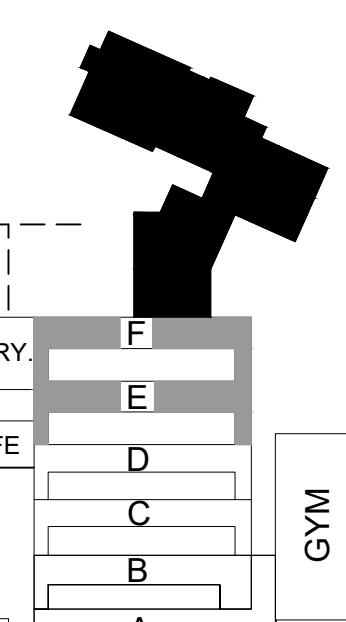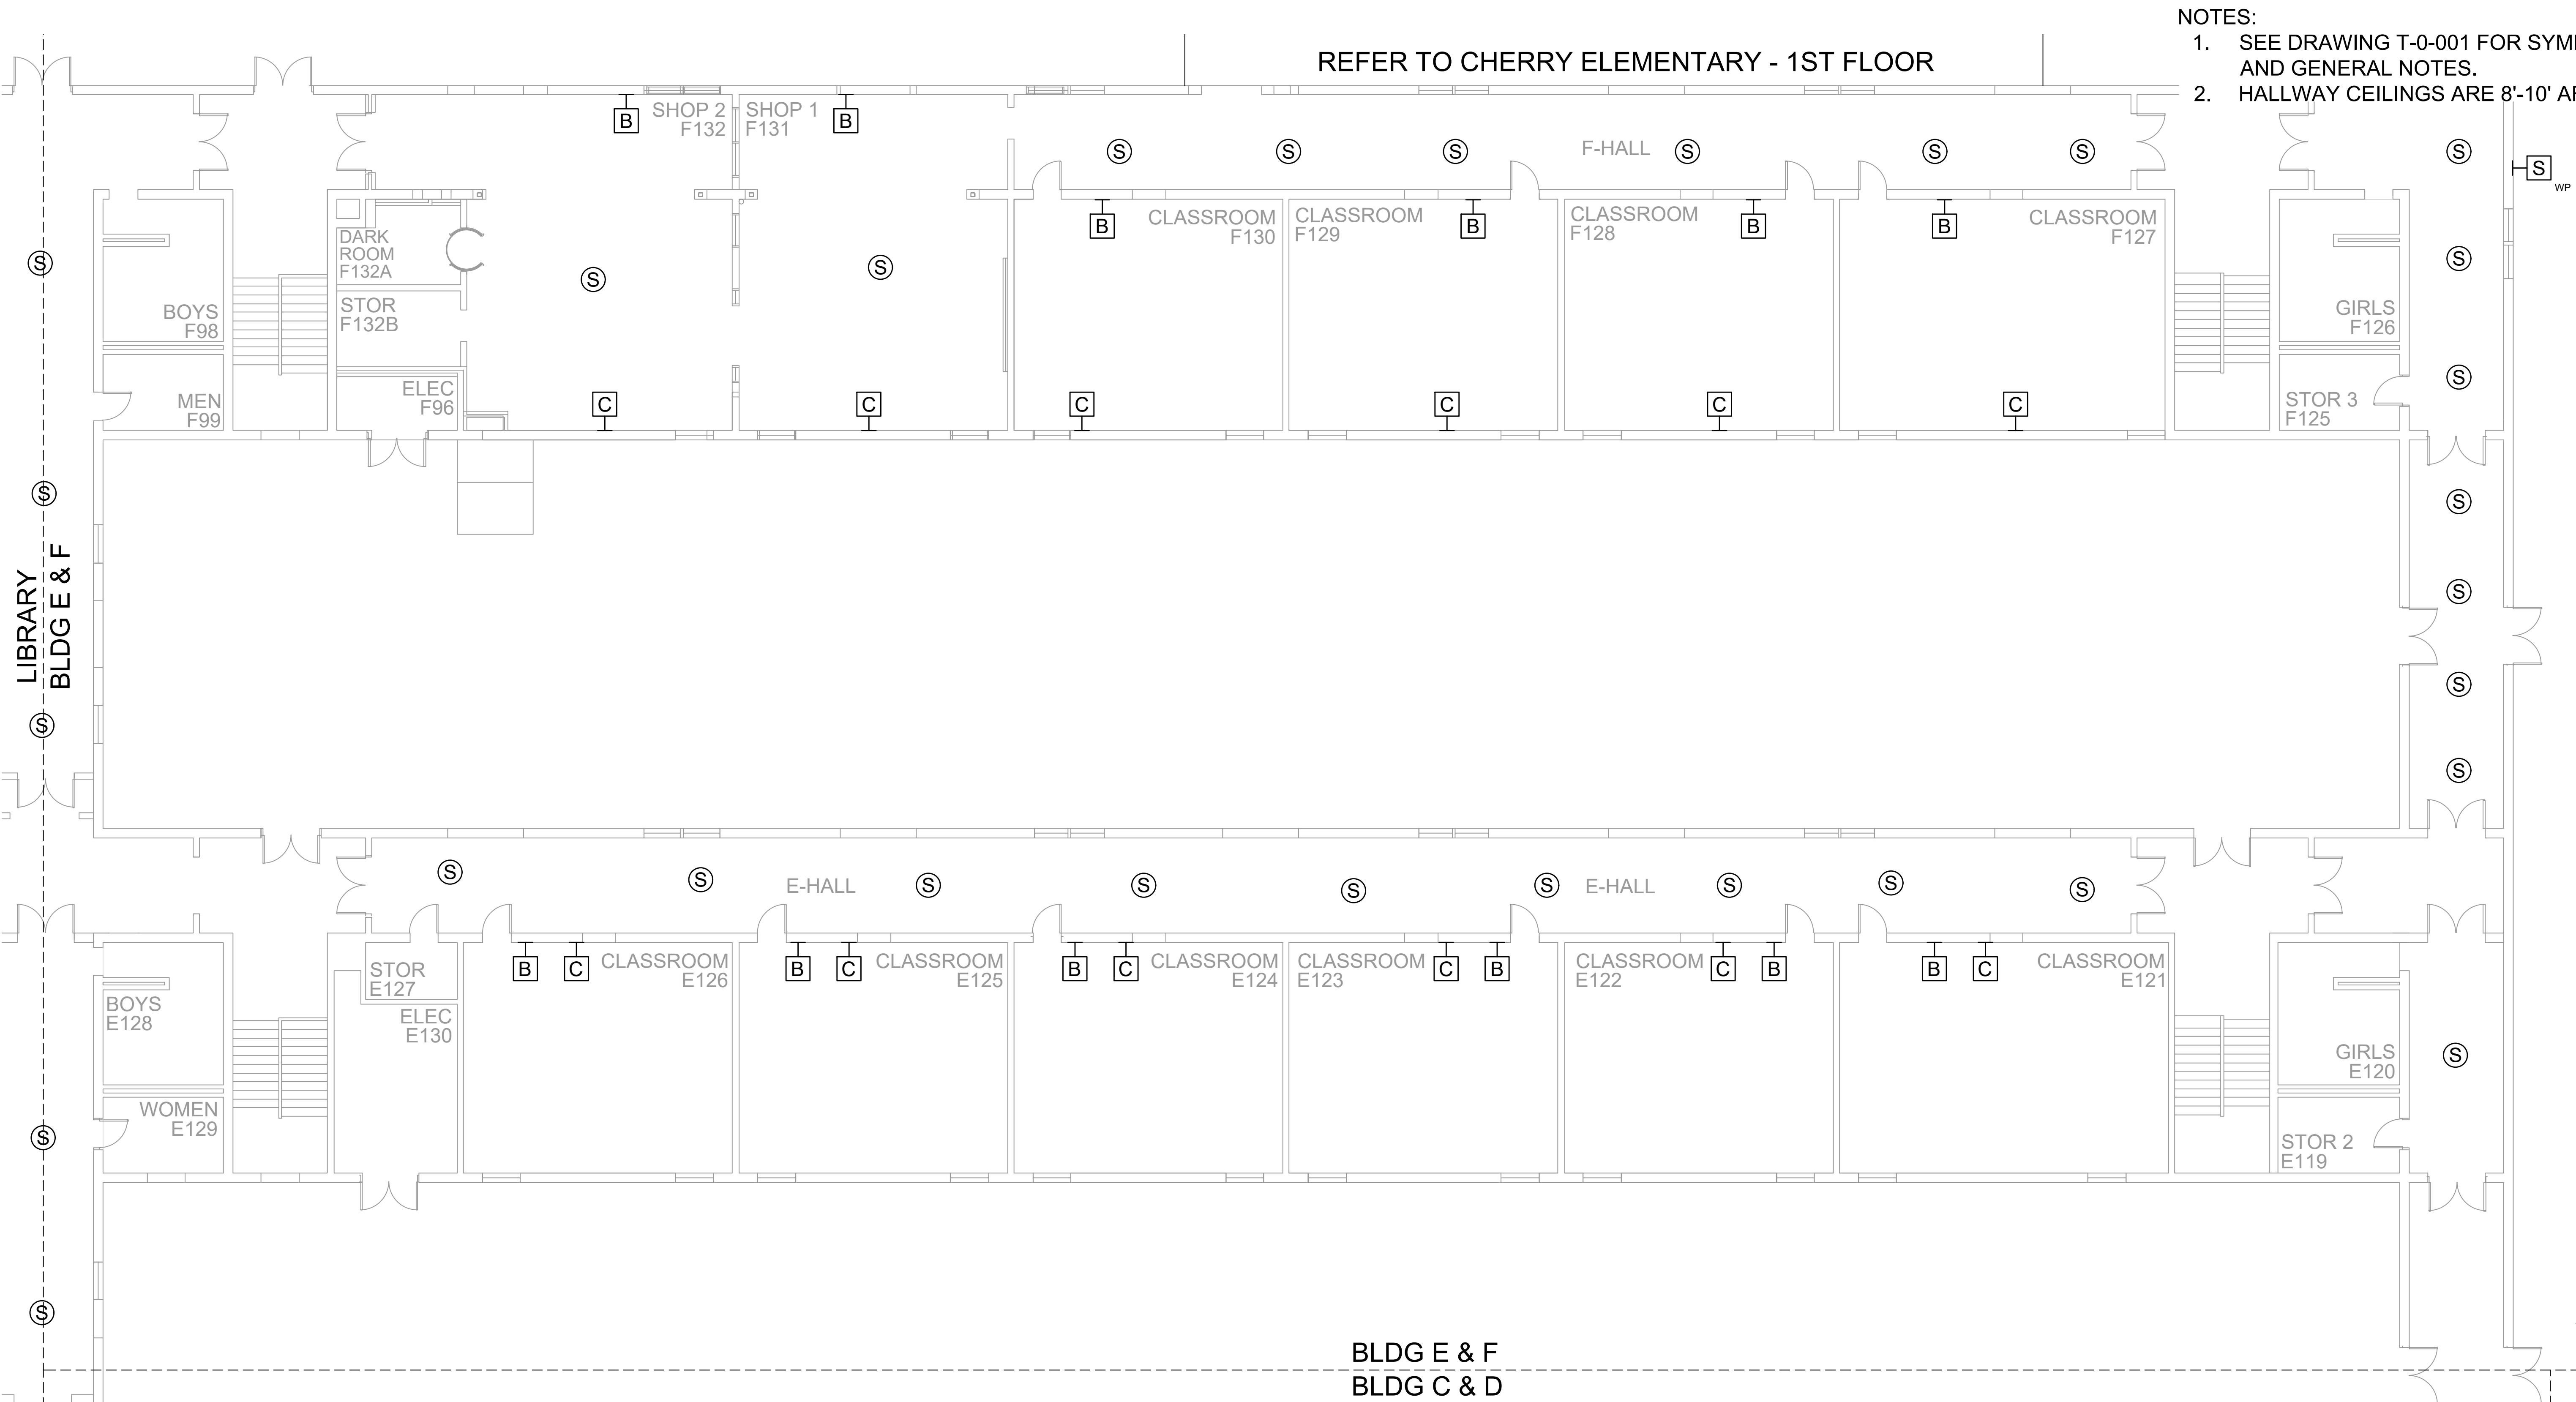

SCALE: NTS




REV.	DESCRIPTION	DATE	REVISIONS	
			ENGINEER APPROVAL	DRAWING NAME
				WM
				CAD
			AK	PROJECT NUMBER
				AR20245
			PROJECT MANAGER	APPROVED DRAWING DATE
			SD	07-23-2021
				RELEASE NUMBER
				1

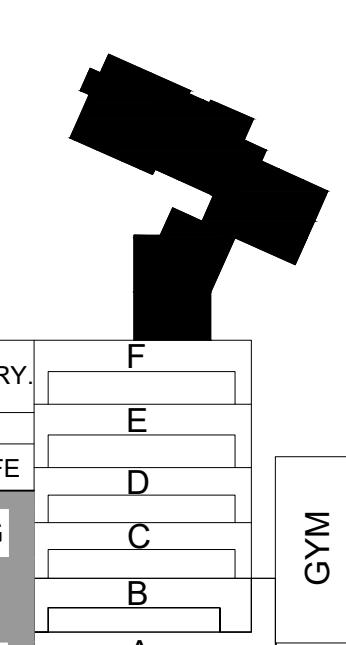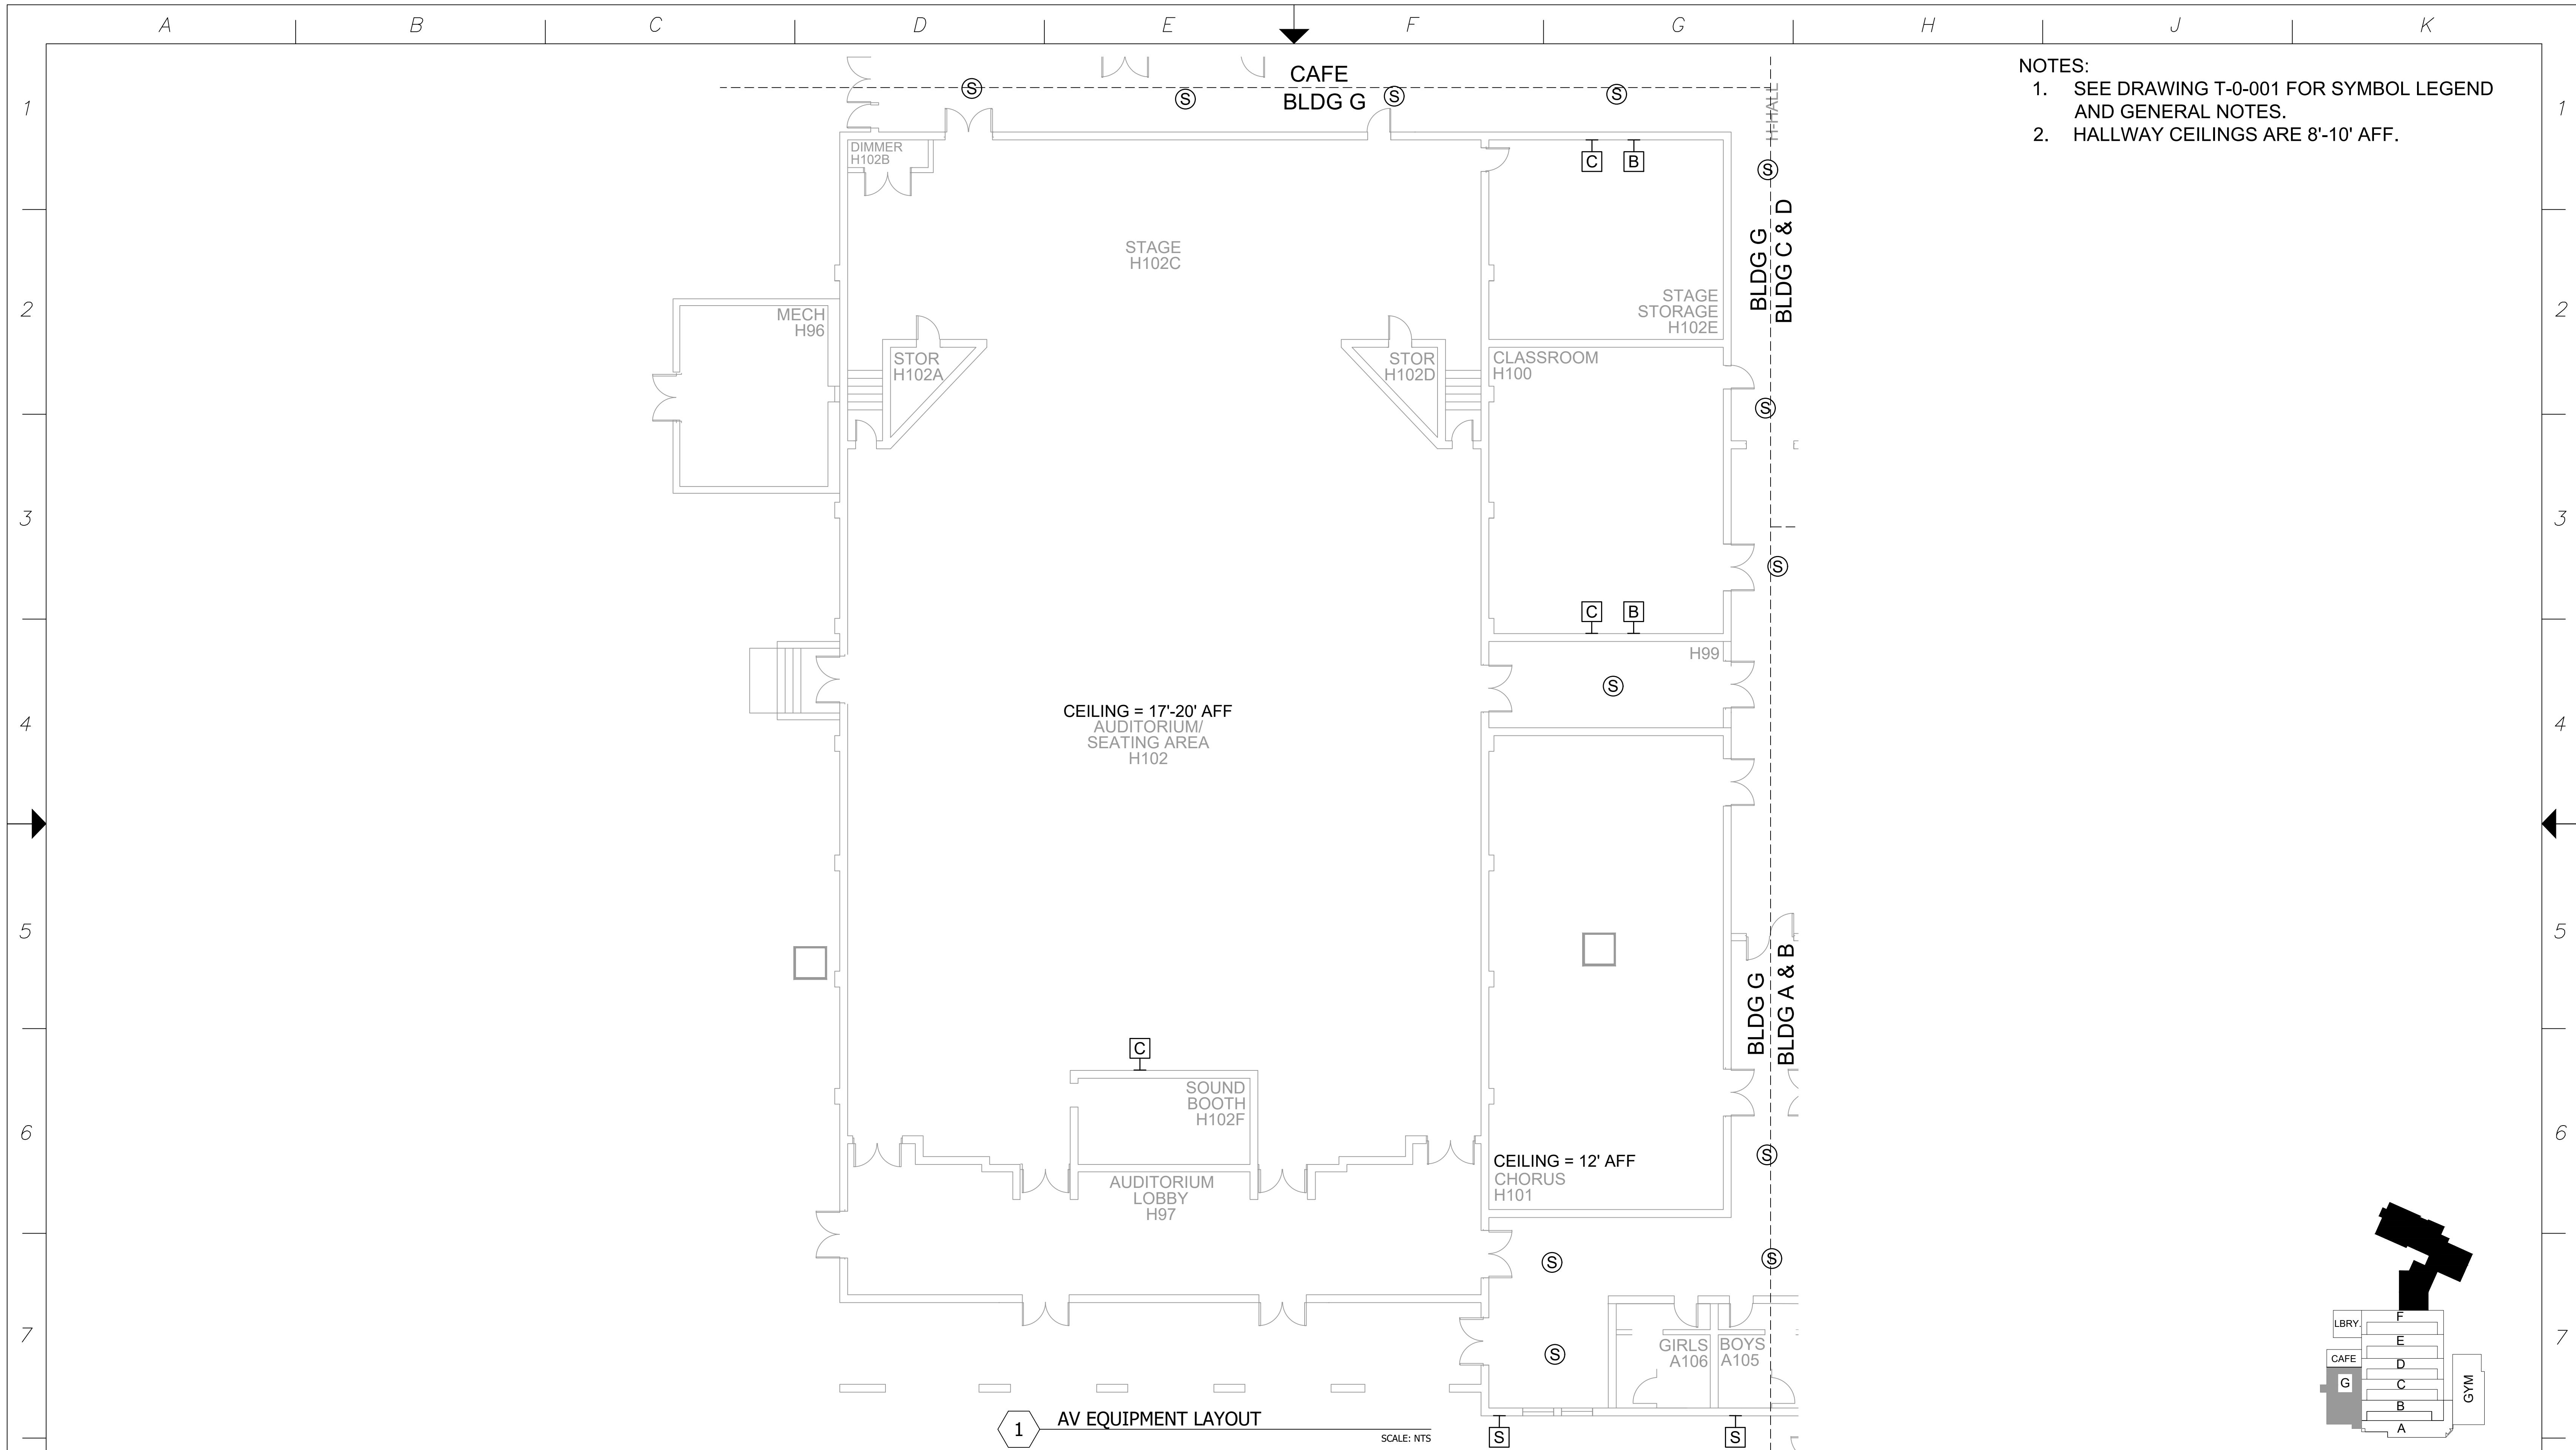

REVISIONS		
REV.	DESCRIPTION	DATE

ENGINEER APPROVAL	ENGINEER	DRAWING NAME
	WM	TA-1-31-104N
	AK	PROJECT NUMBER
SD	APPROVED DRAWING DATE 07-23-2021	RELEASE NUMBER 1

NOTES:
 1. SEE DRAWING T-0-001 FOR SYMBOL LEGEND AND GENERAL NOTES.
 2. HALLWAY CEILINGS ARE 8'-10' AFF.

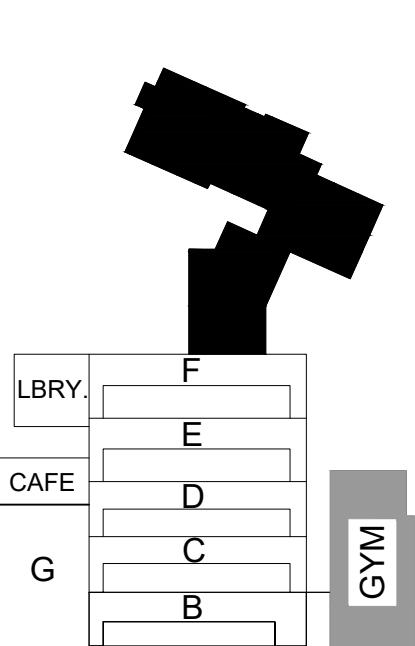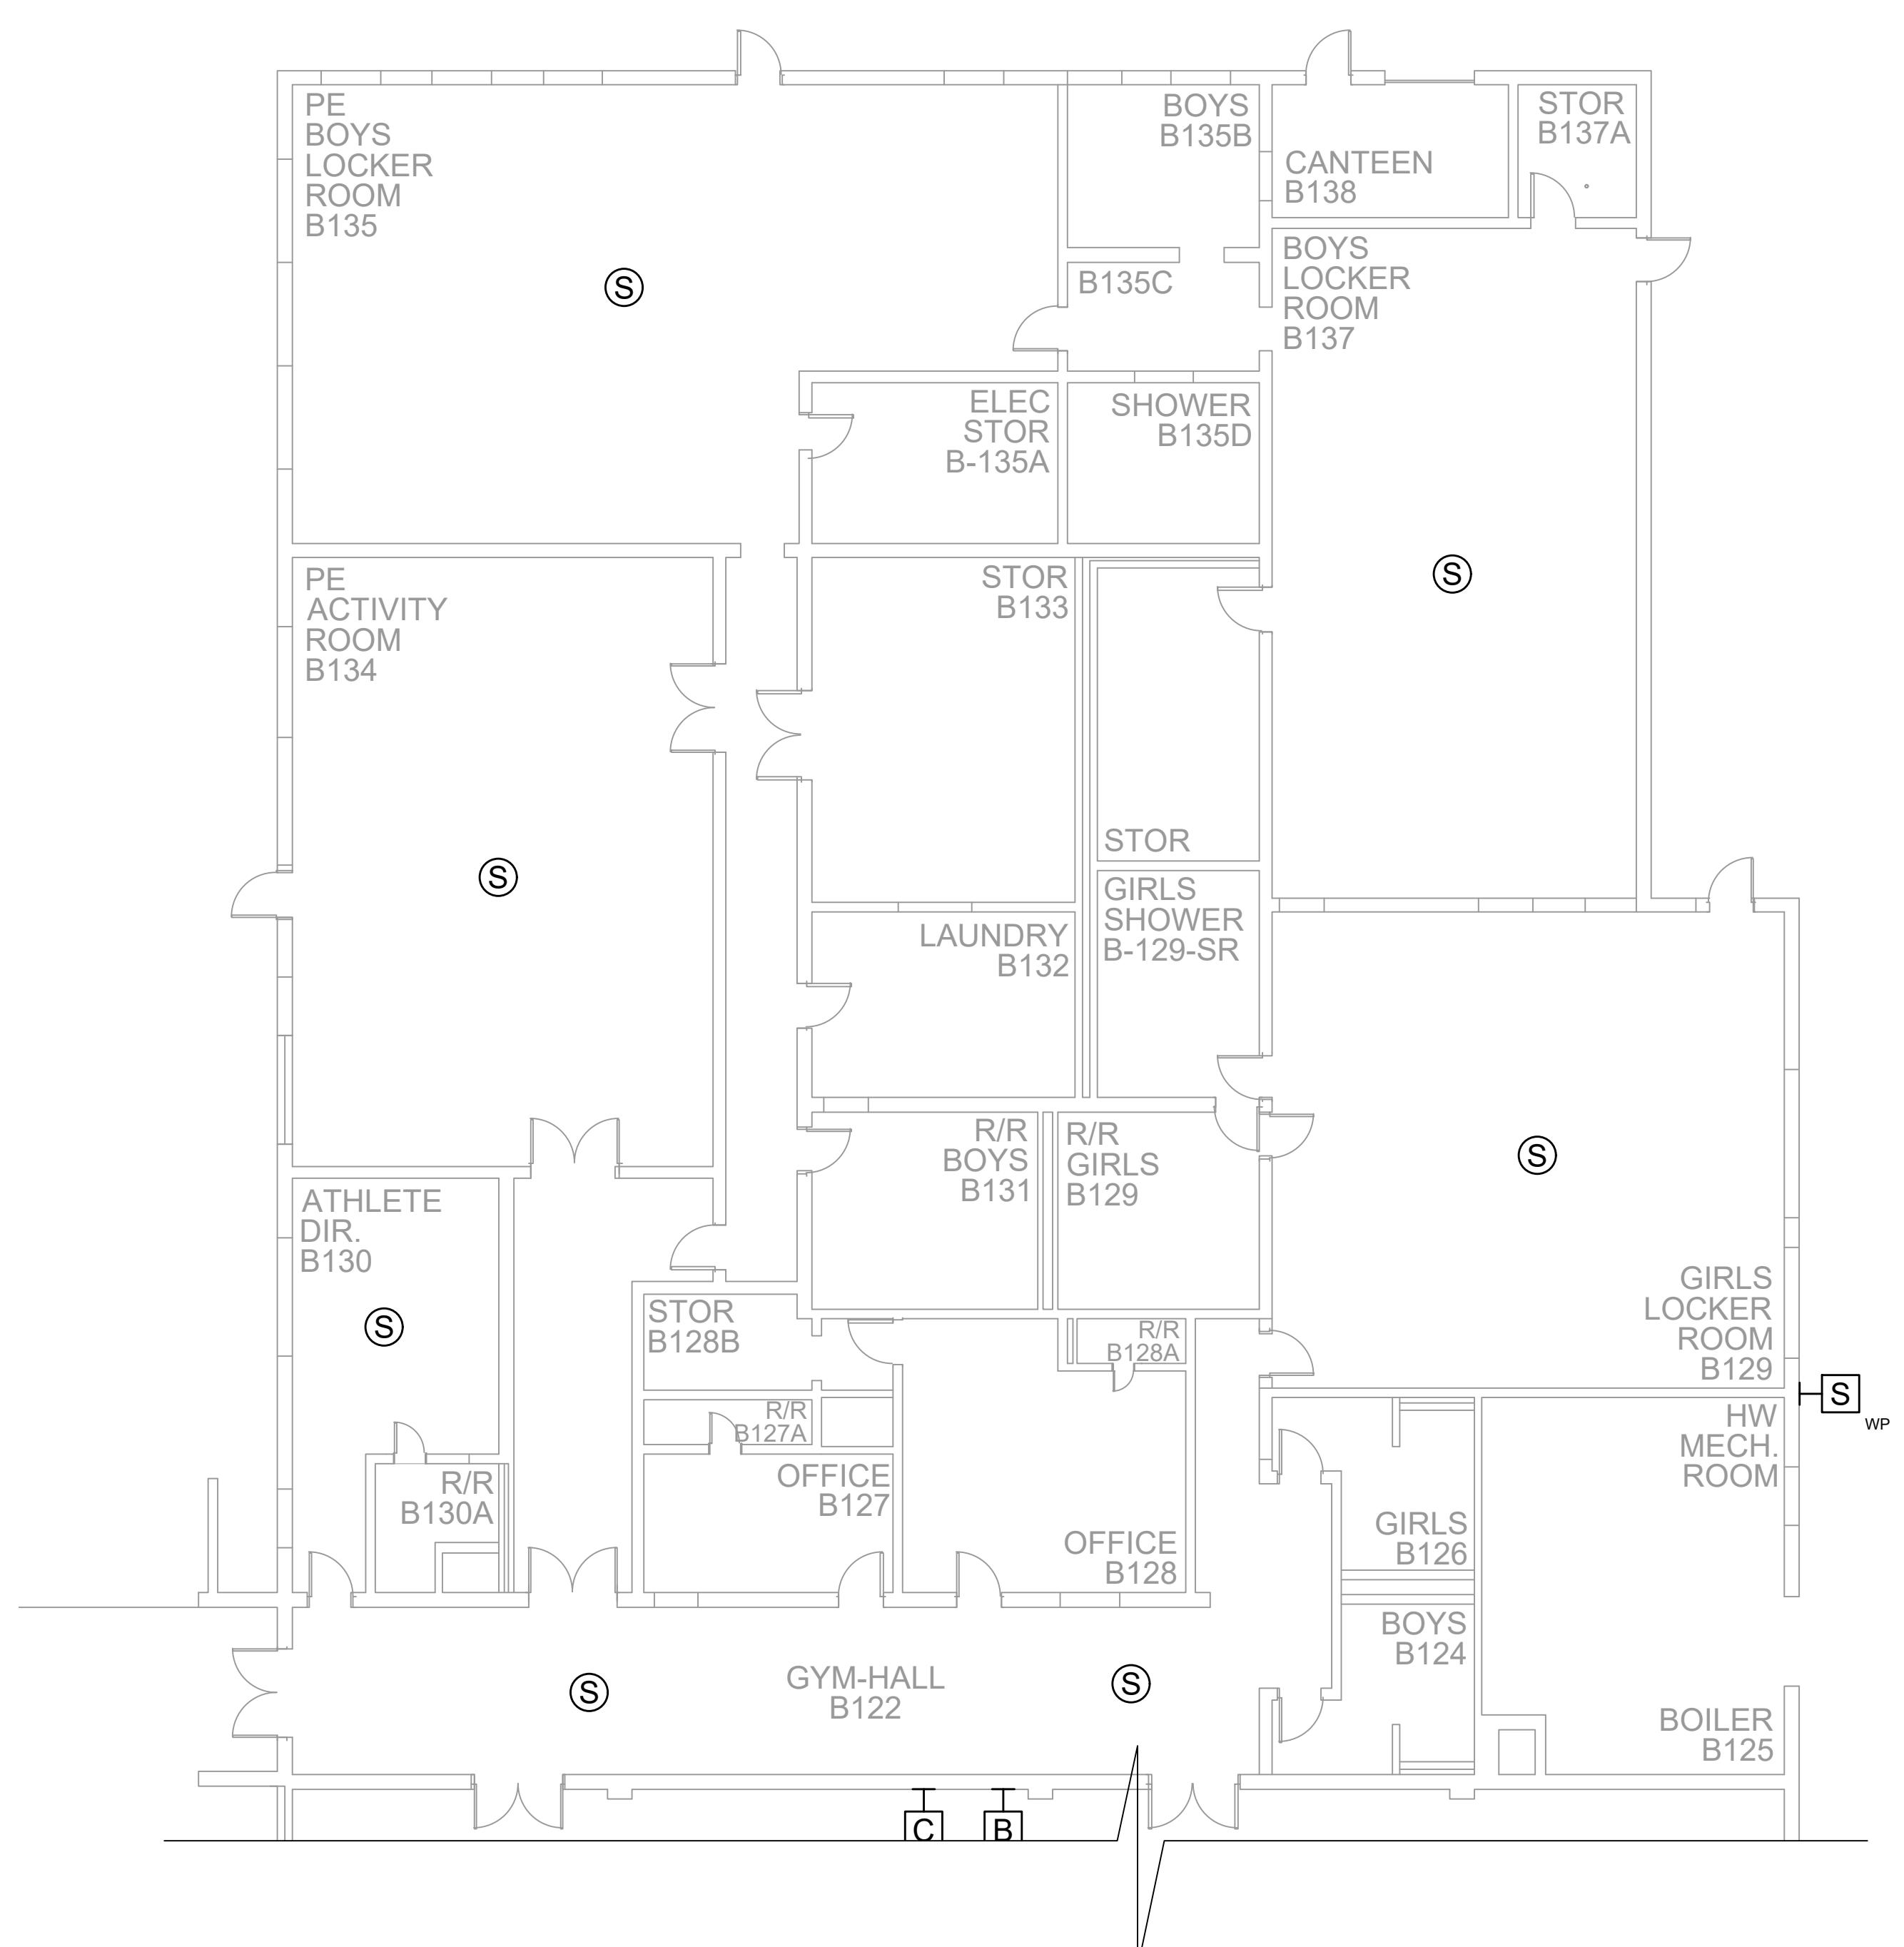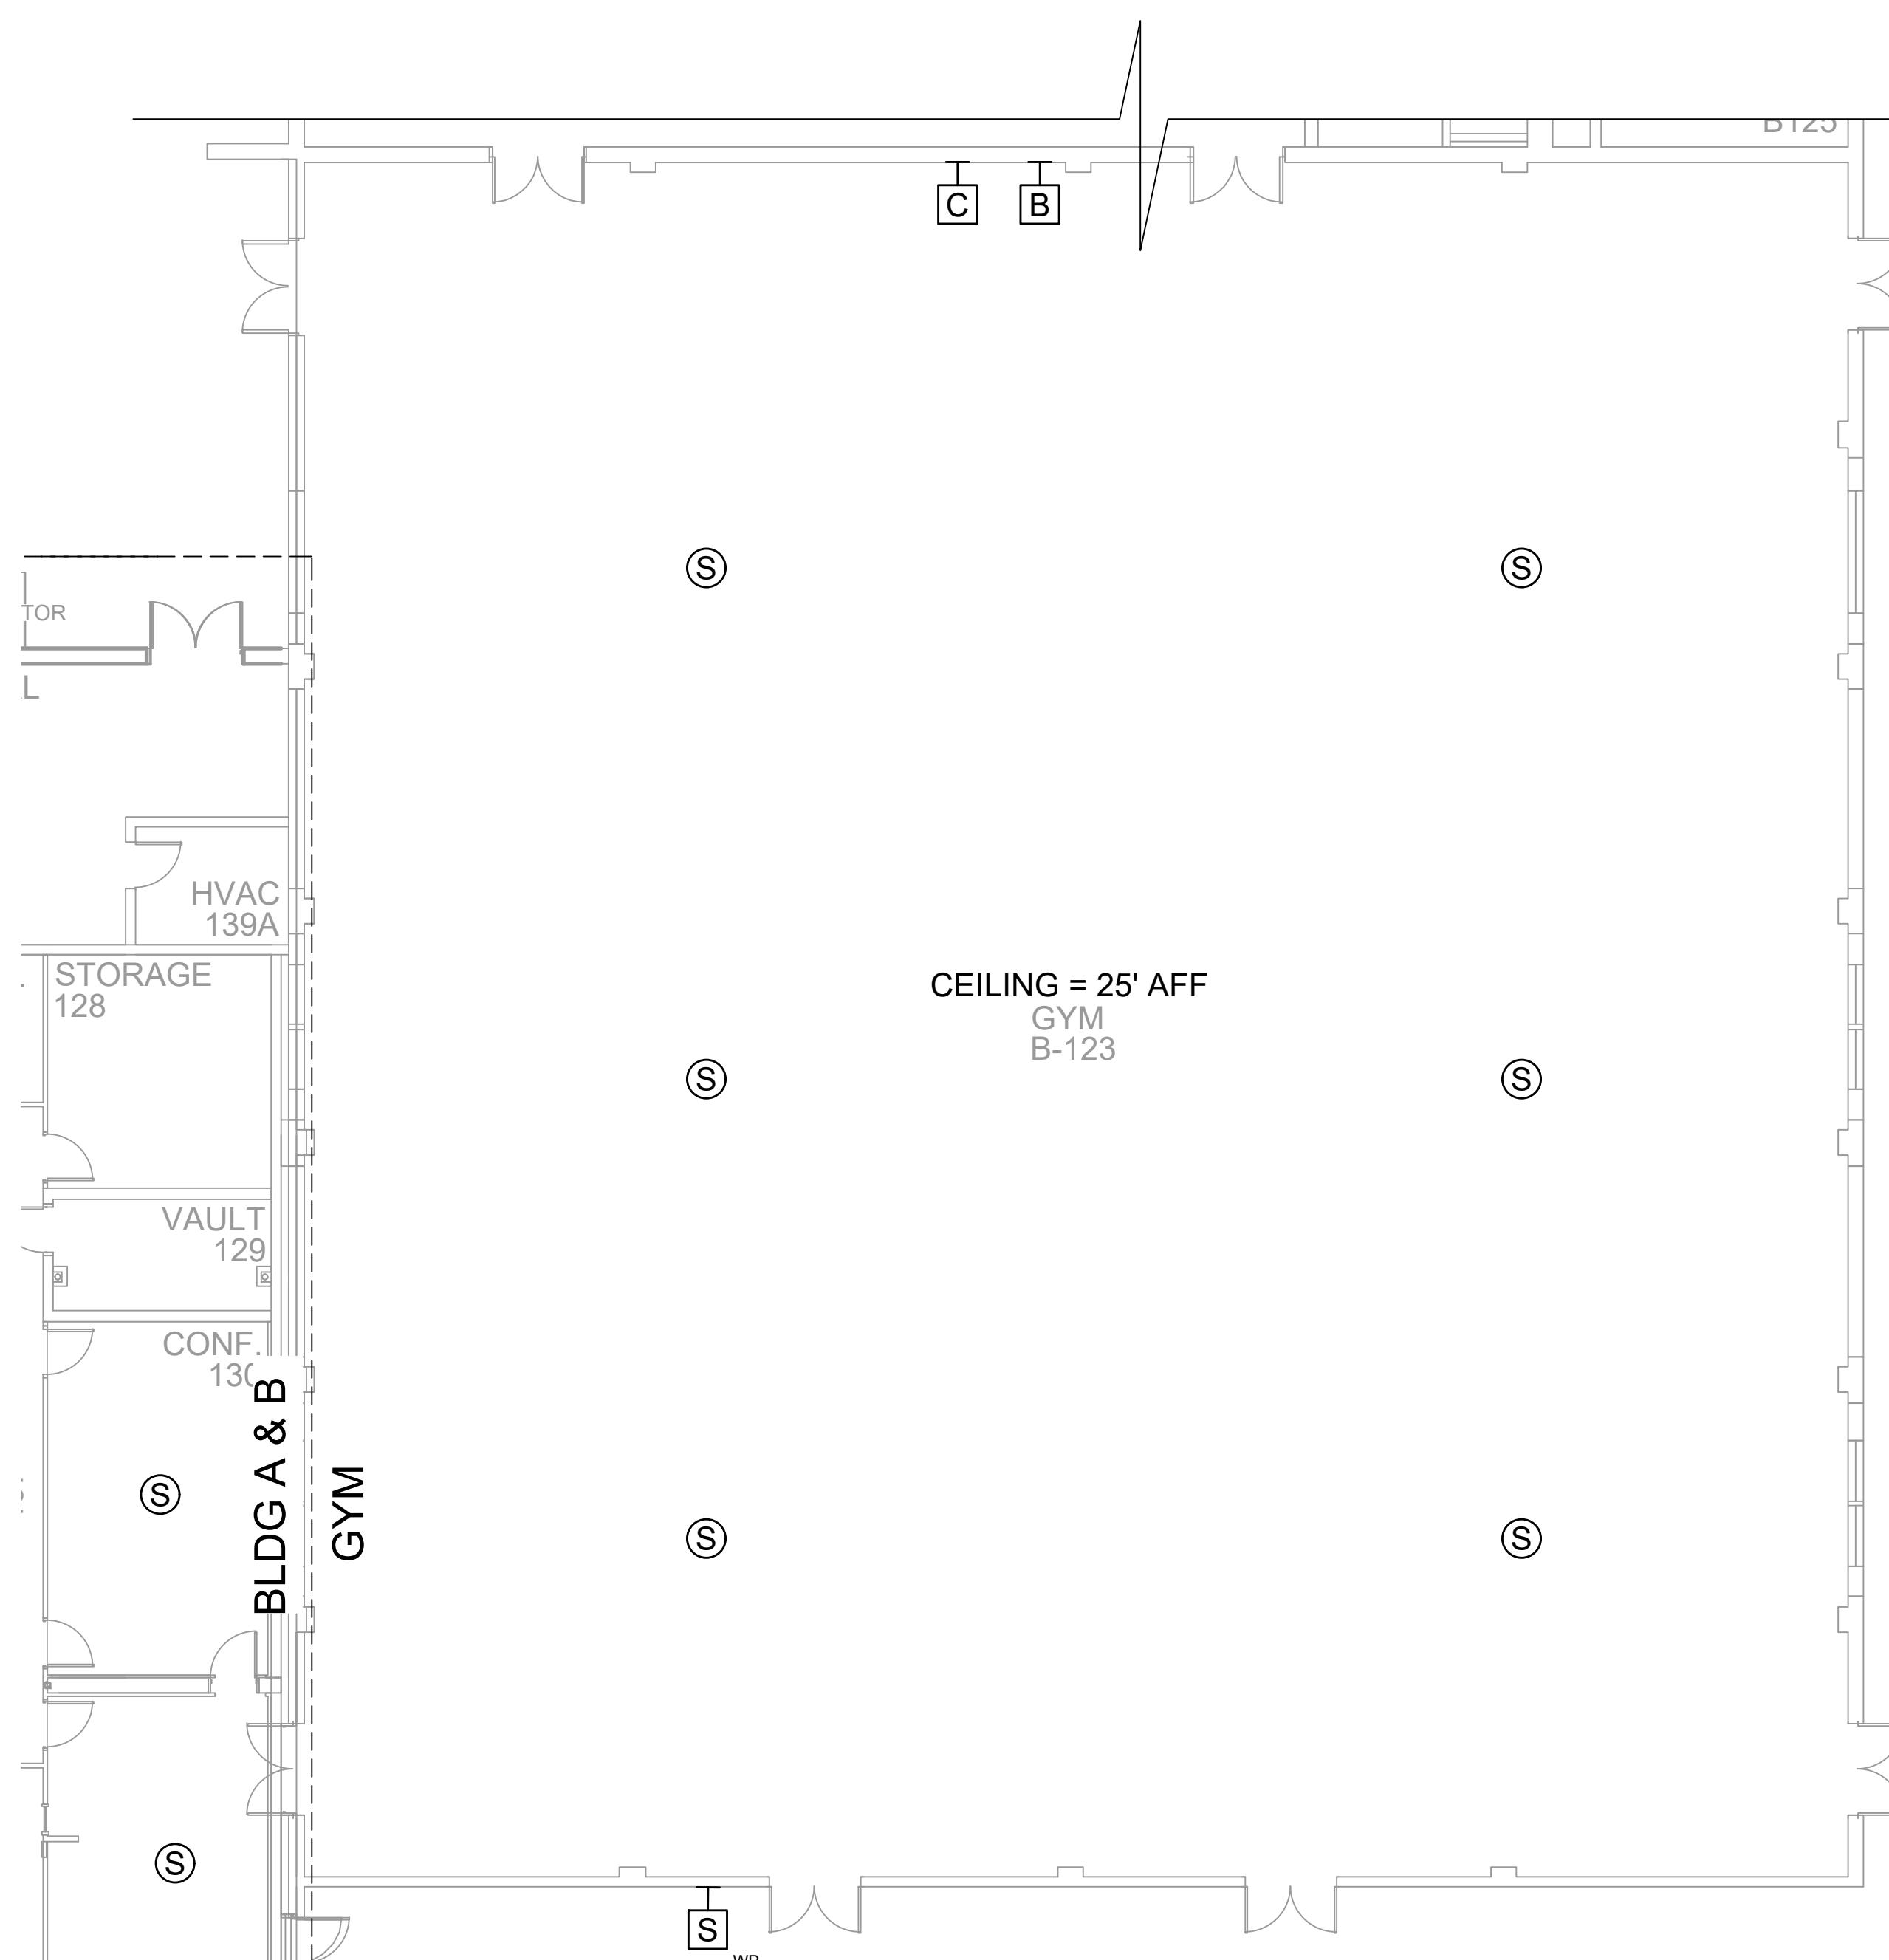

A

B

C

D

E

F

G


H

J

K


NOTES:

- SEE DRAWING T-0-001 FOR SYMBOL LEGEND AND GENERAL NOTES.
- HALLWAY CEILINGS ARE 8'-10' AFF.

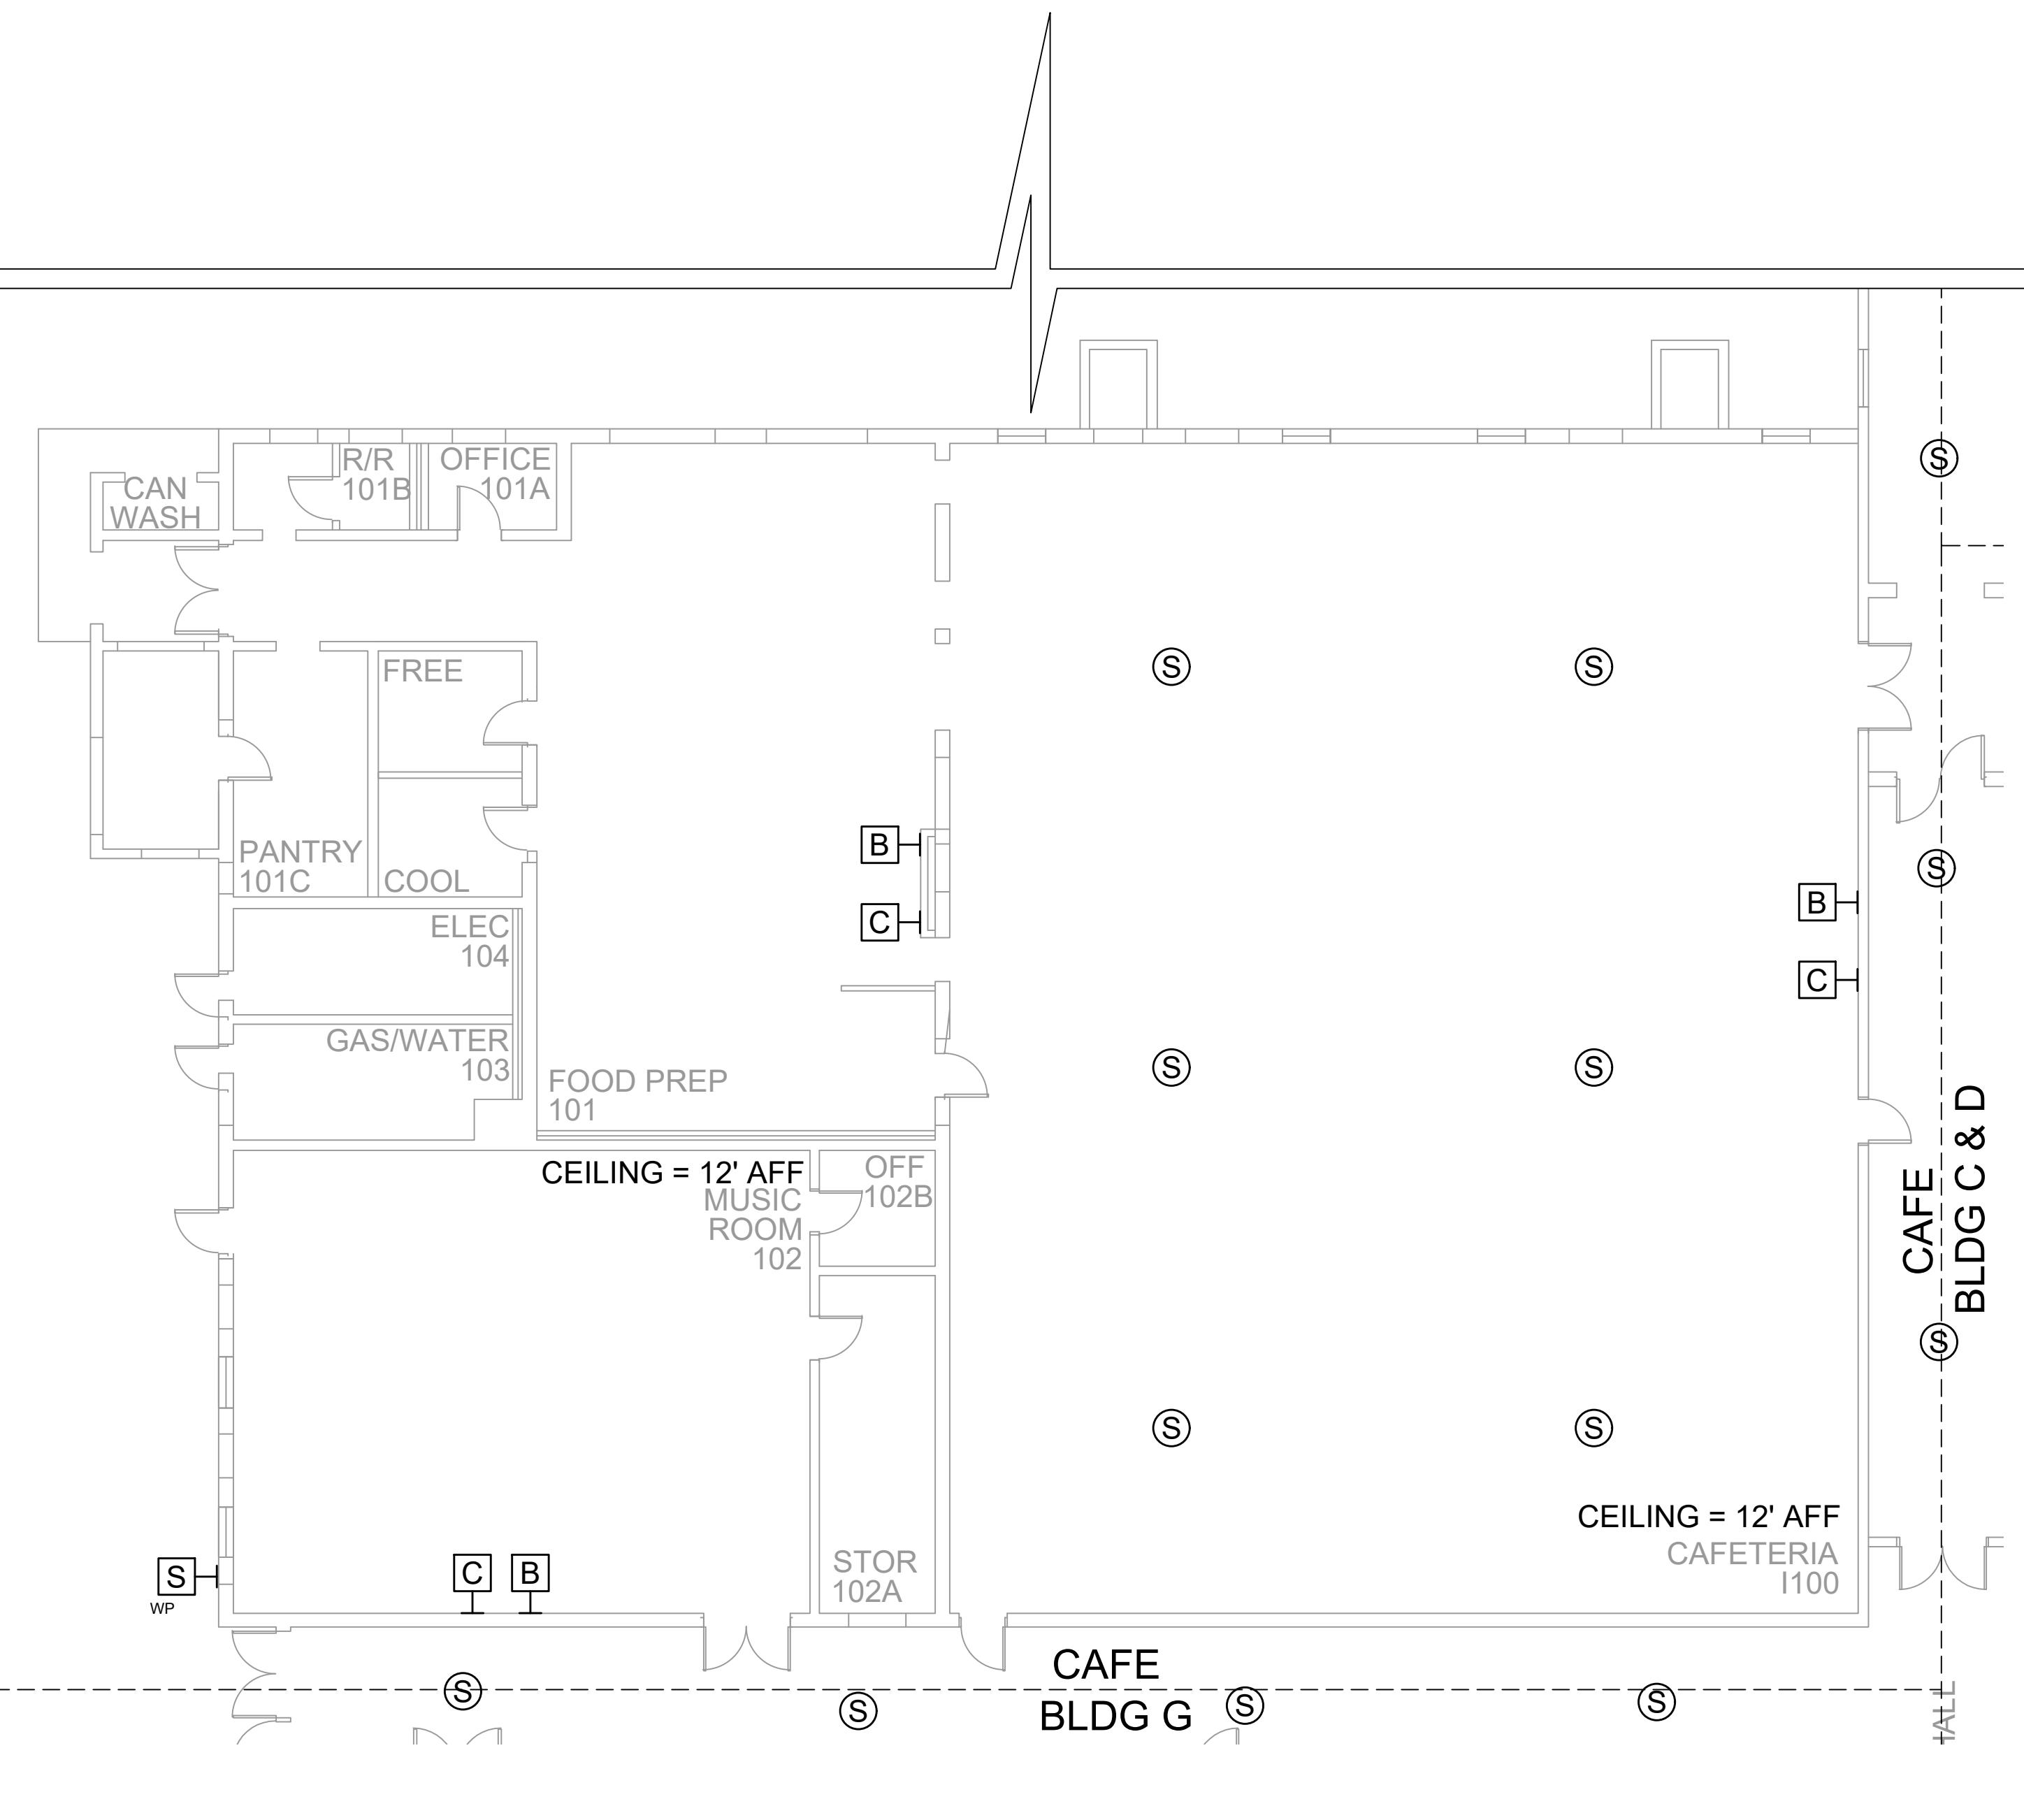


AV EQUIPMENT LAYOUT - CAFE

SCALE: NTS

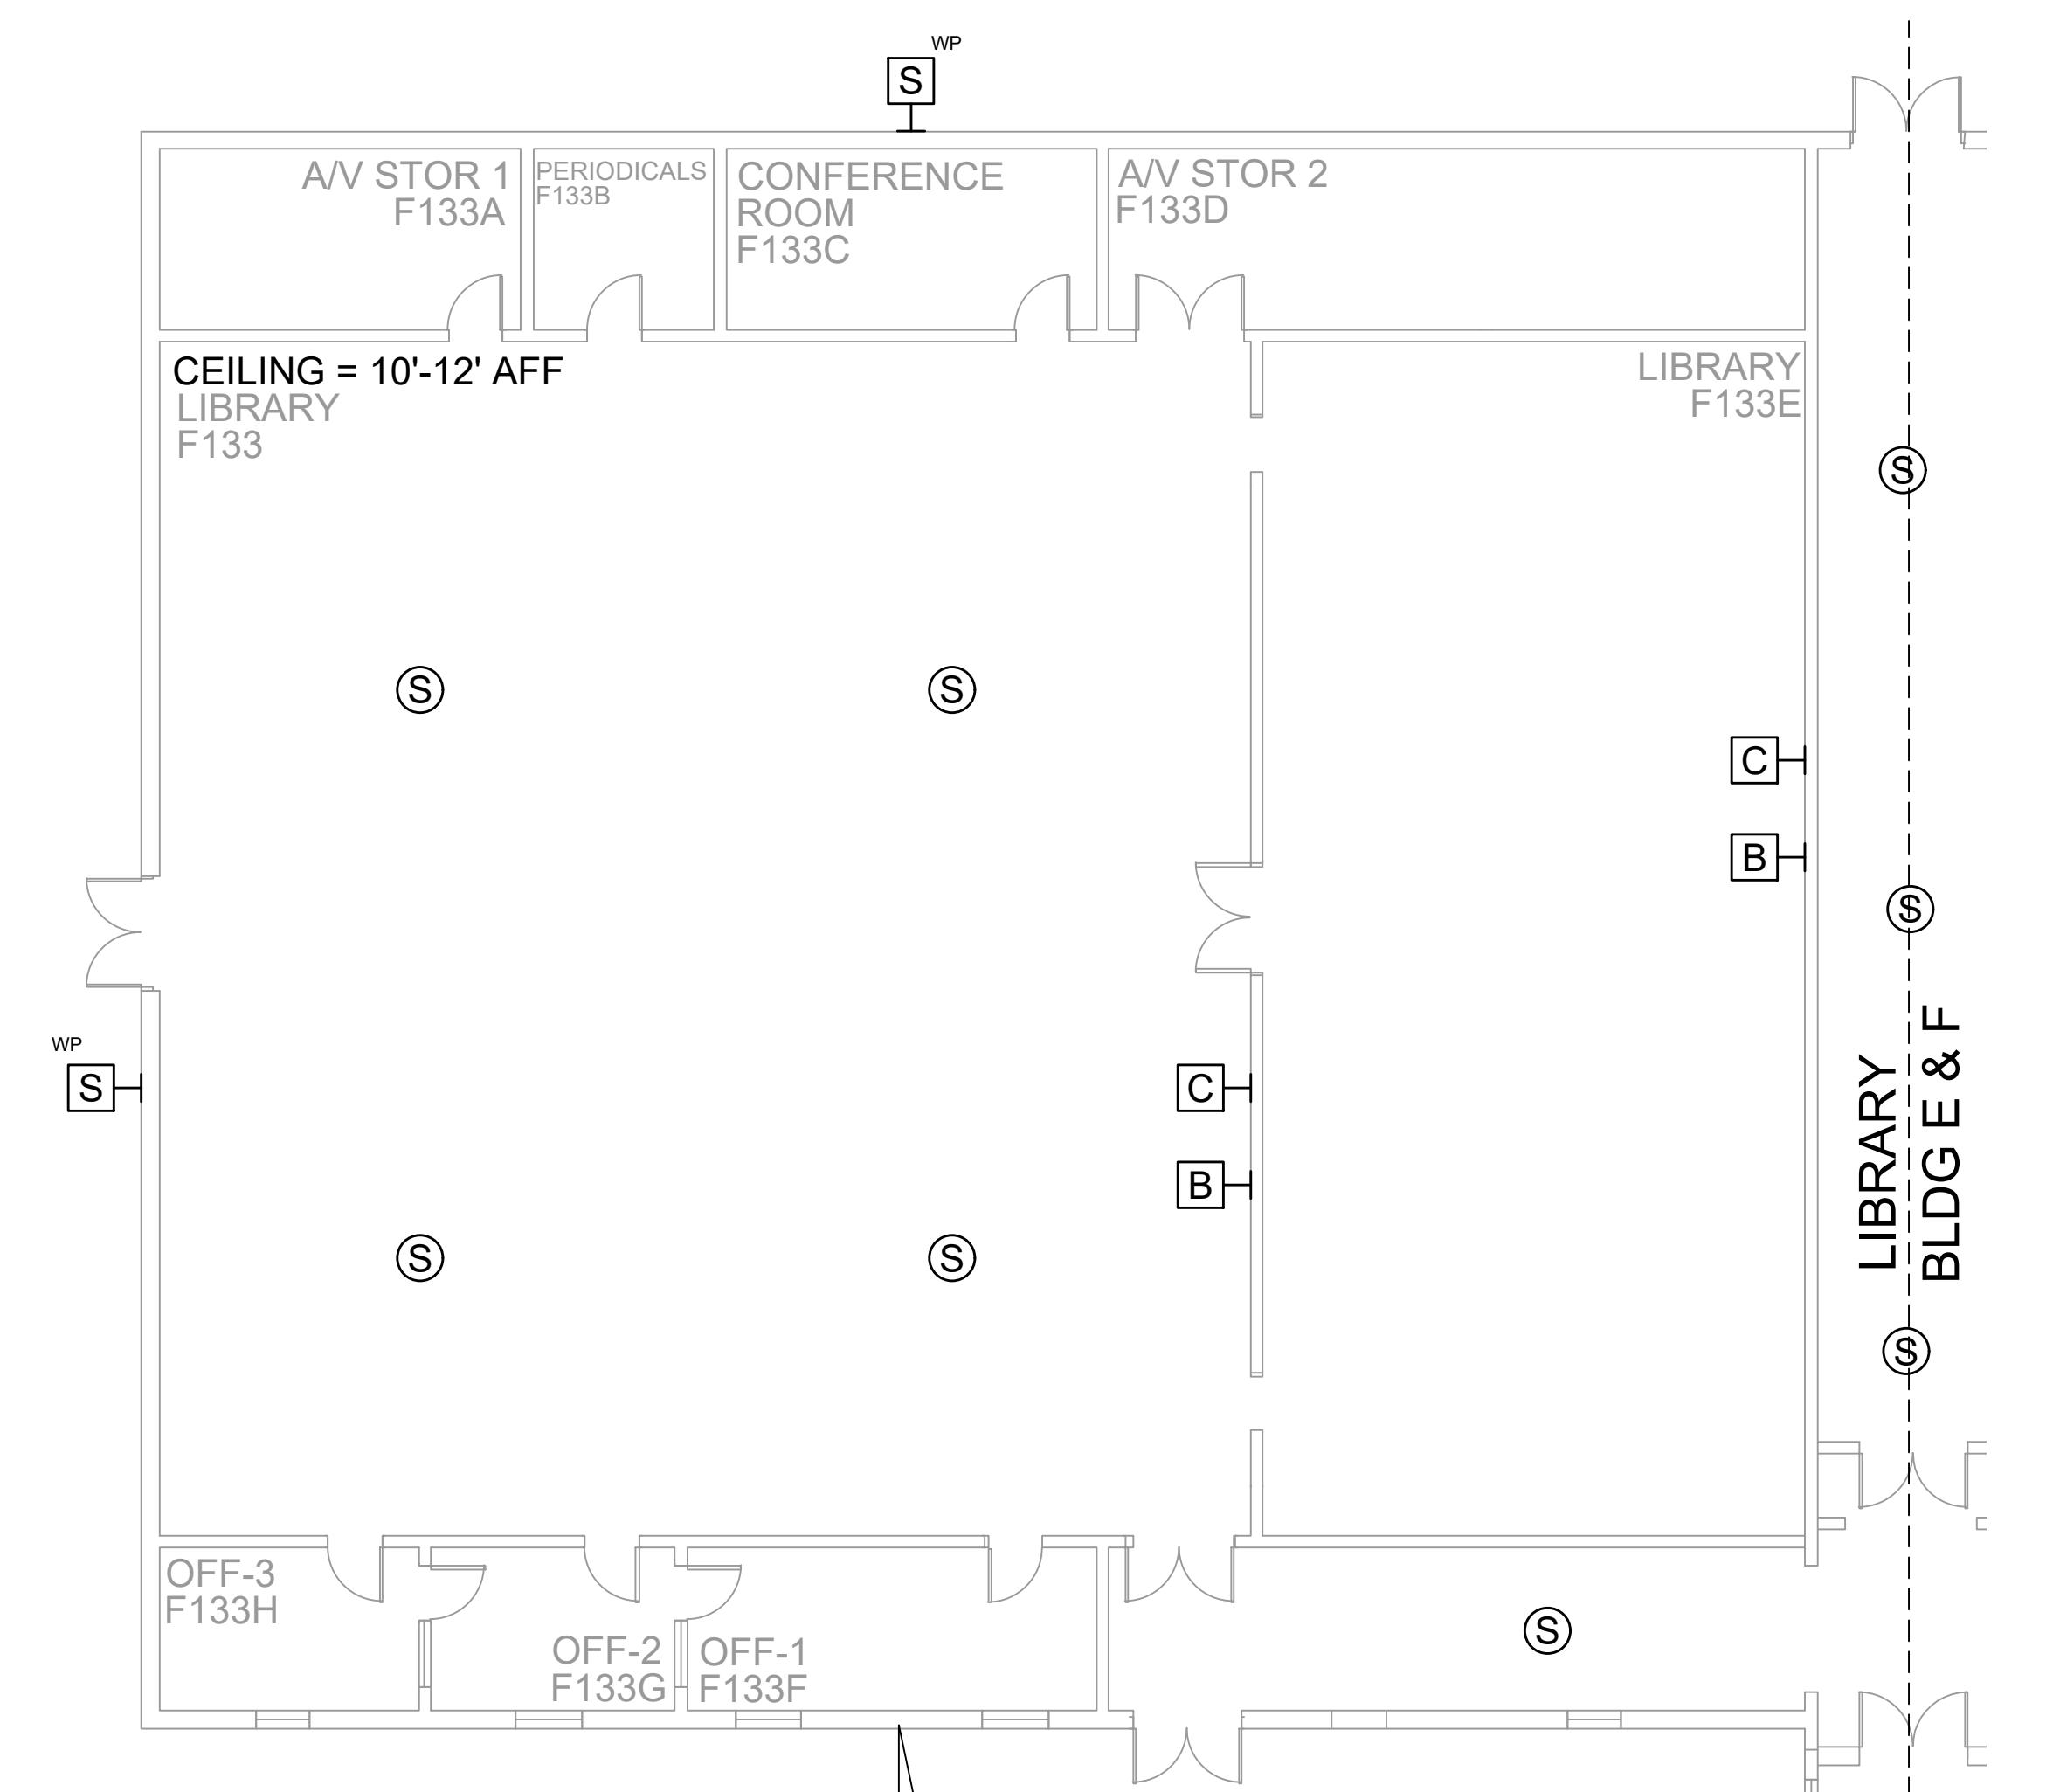


AV EQUIPMENT LAYOUT - LIBRARY

SCALE: NTS

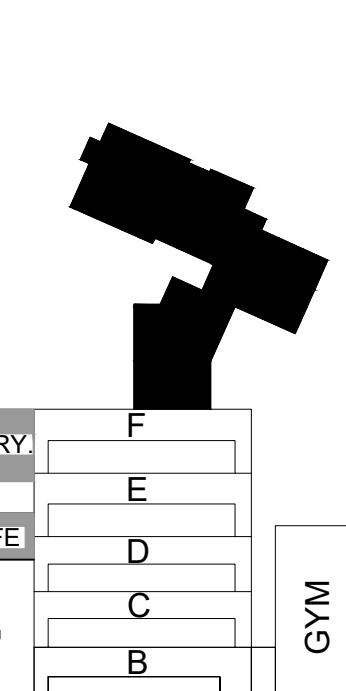


NOTES:
 1. SEE DRAWING T-0-001 FOR SYMBOL LEGEND AND GENERAL NOTES.
 2. HALLWAY CEILINGS ARE 8'-10' AFF.

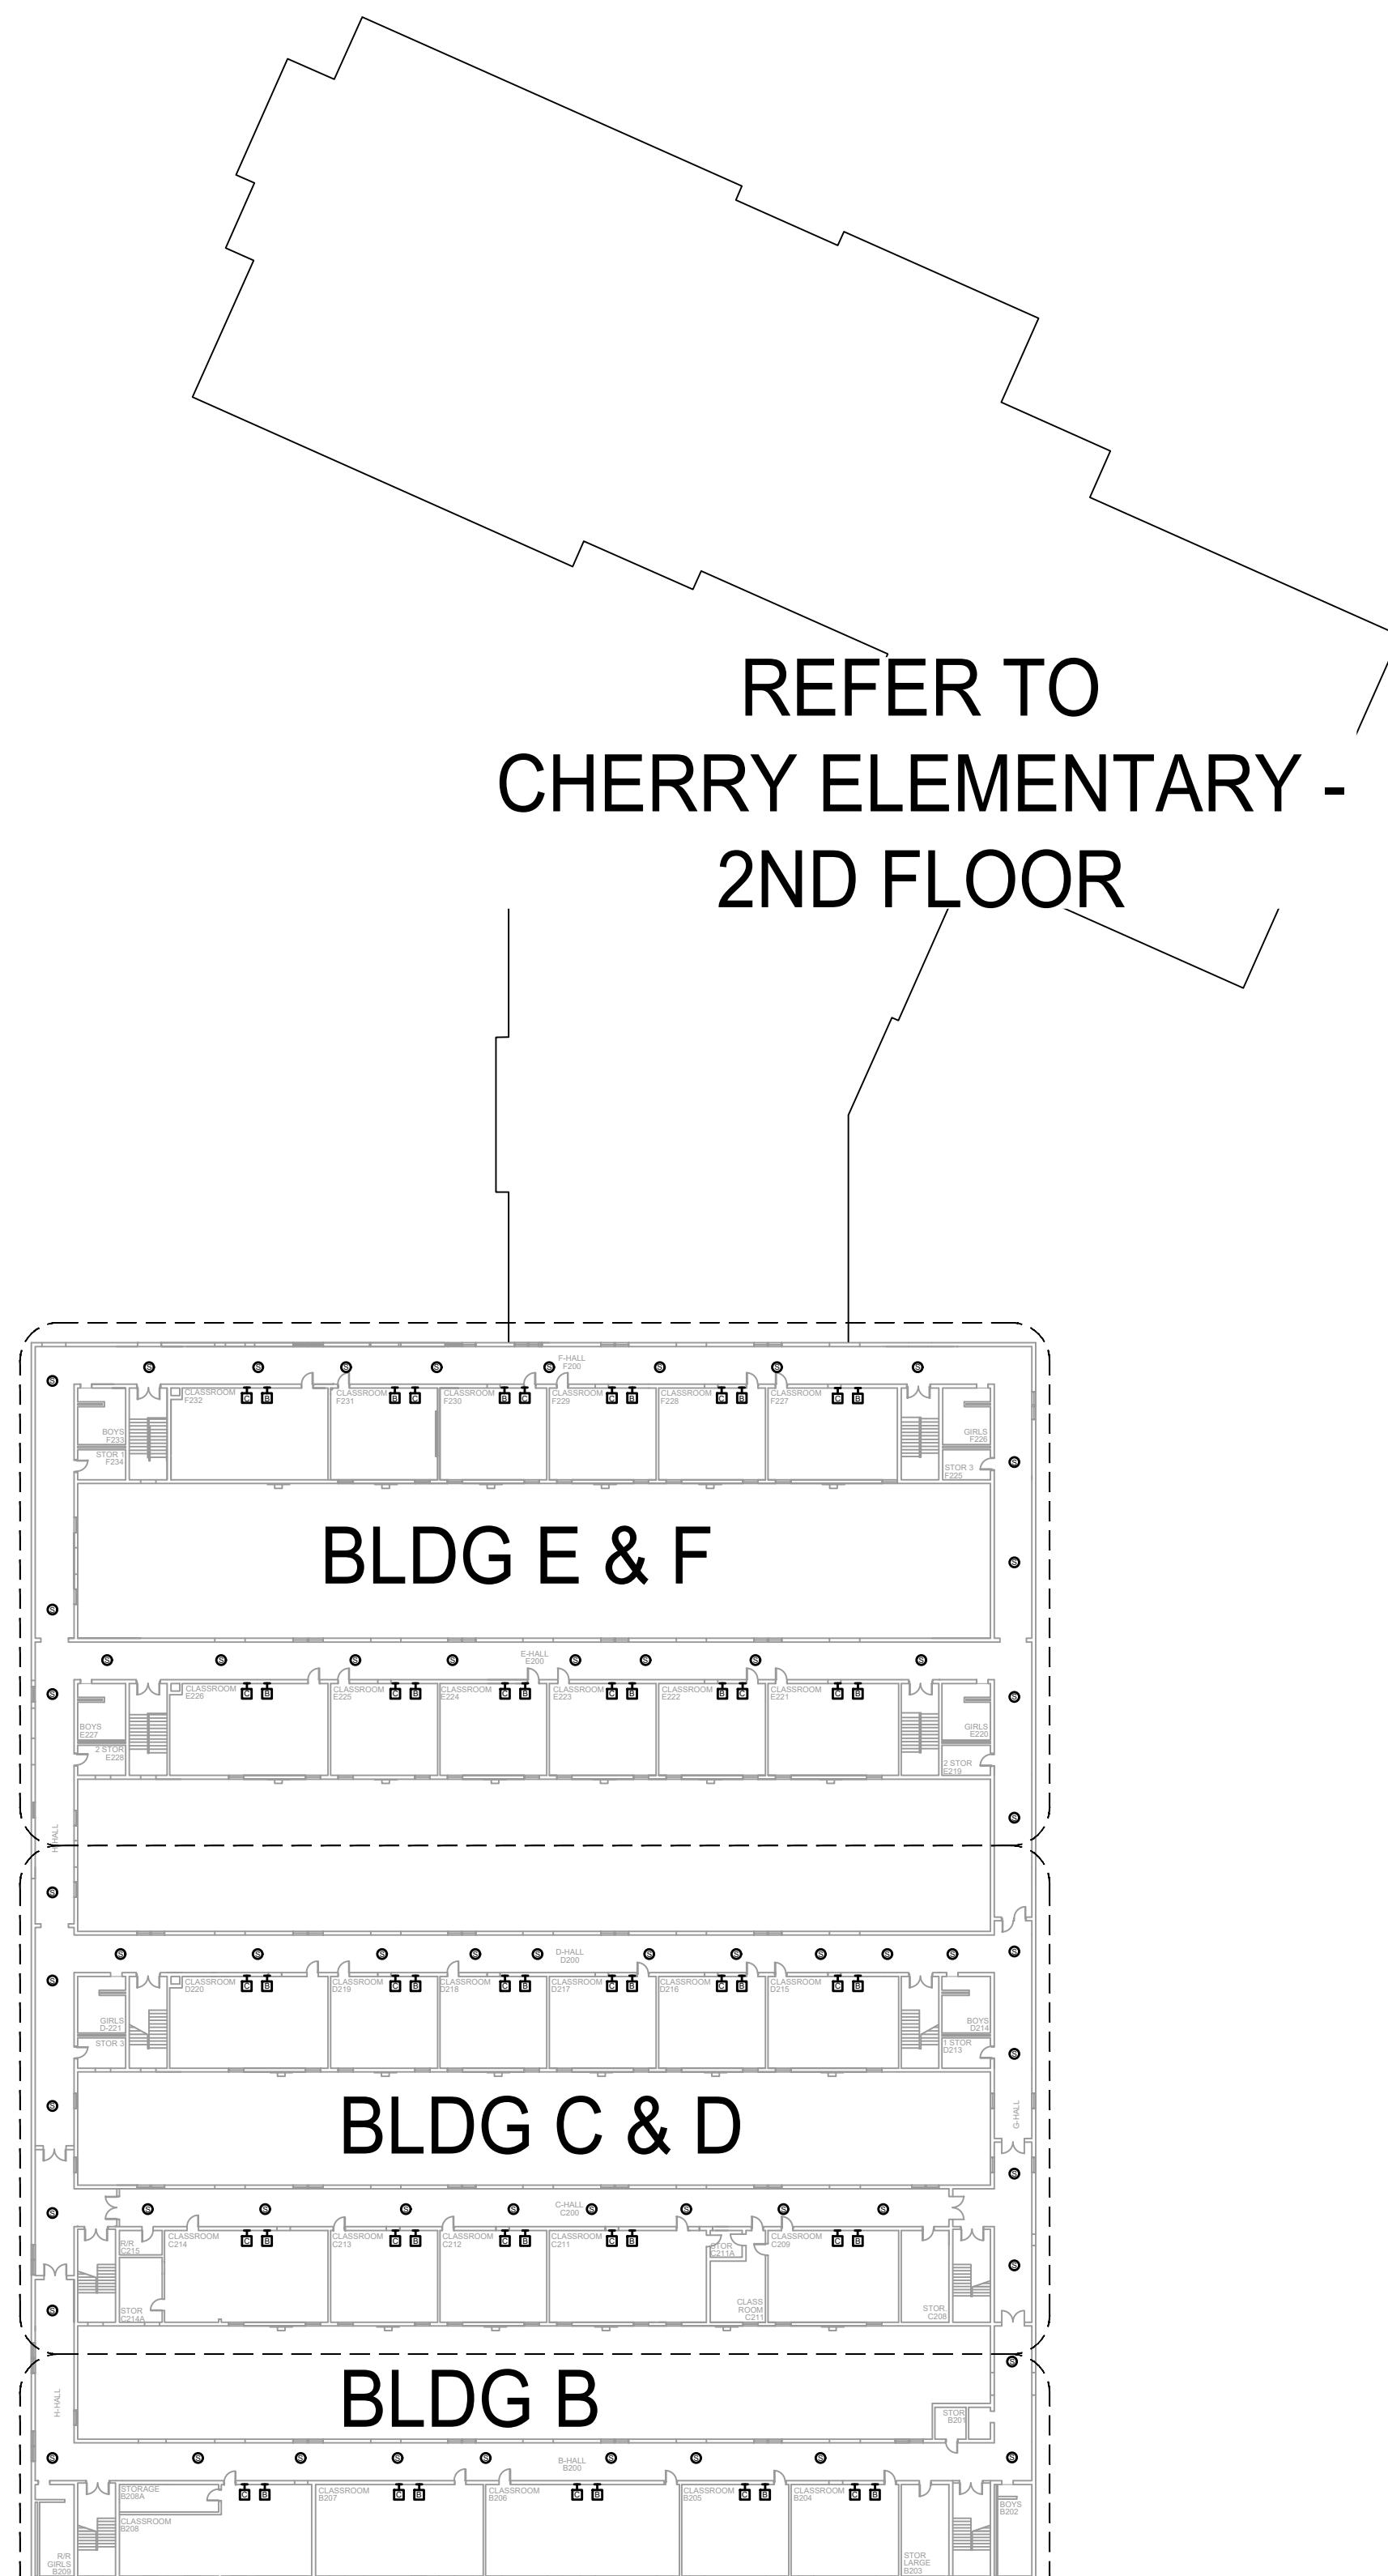

1 AV EQUIPMENT LAYOUT - OVERALL

SCALE: NTS

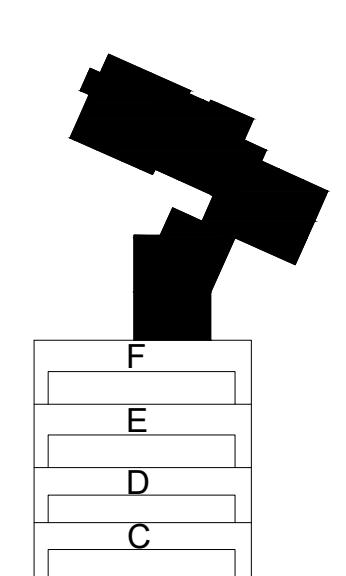


REV.	DESCRIPTION	DATE	REVISIONS	
			ENGINEER APPROVAL	PROJECT NUMBER

ENGINEER APPROVAL	DRAWING NAME
	TA-1-31-200N
	PROJECT NUMBER
AK	AR20245
	APPROVED DRAWING DATE
SD	RELEASE NUMBER

A B C D E F G H J K

NOTES:
 1. SEE DRAWING T-0-001 FOR SYMBOL LEGEND
 AND GENERAL NOTES.
 2. HALLWAY CEILINGS ARE 8'-10' AFF.

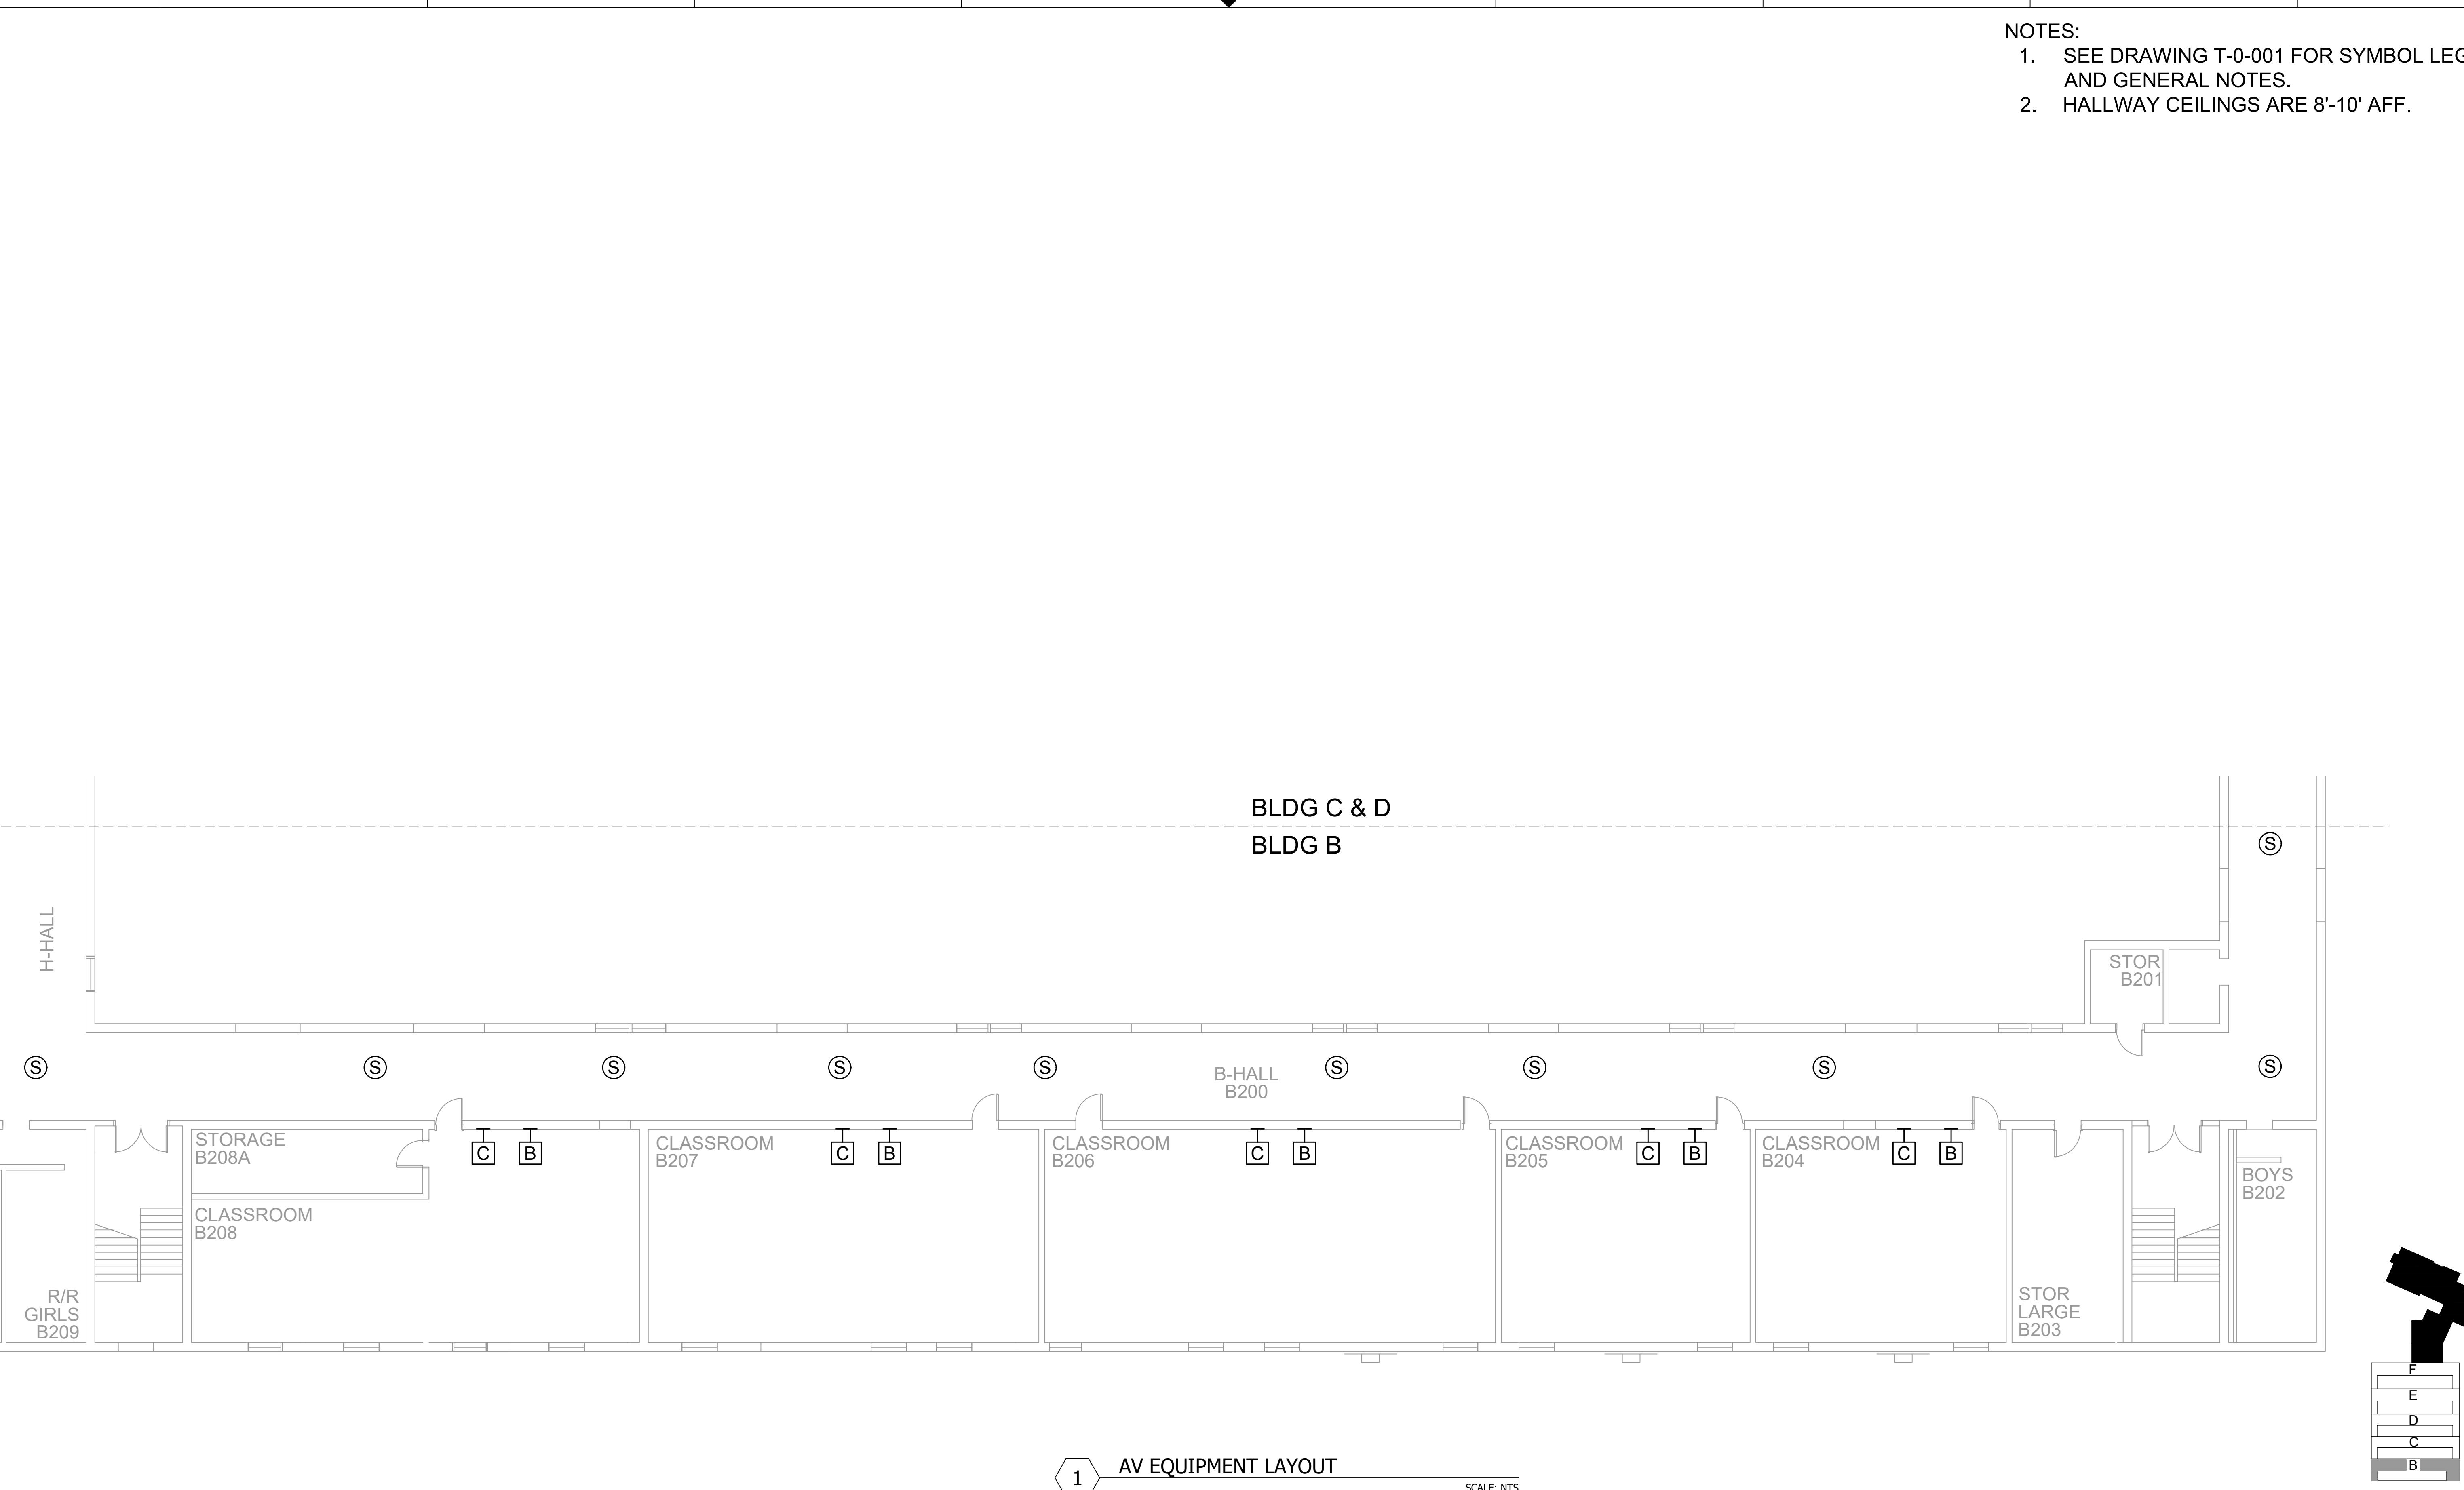

AV EQUIPMENT LAYOUT

SCALE: NTS



CLIENT LOGO


PROJECT INFO
ROCK HILL SCHOOLS
ROCK HILL, SC

SHEET INFO
INTERCOM & NOTIFICATIONS
SULLIVAN MS - 2ND FLR BLDG B -
NEW DEVICES

REV.	DESCRIPTION	DATE	REVISIONS	
			ENGINEER APPROVAL	PROJECT NUMBER

ENGINEER APPROVAL	ENGINEER WM	DRAWING NAME
	CAD AK	PROJECT NUMBER
	PROJECT MANAGER SD	APPROVED DRAWING DATE 07-23-2021


A B C D E F G H J K

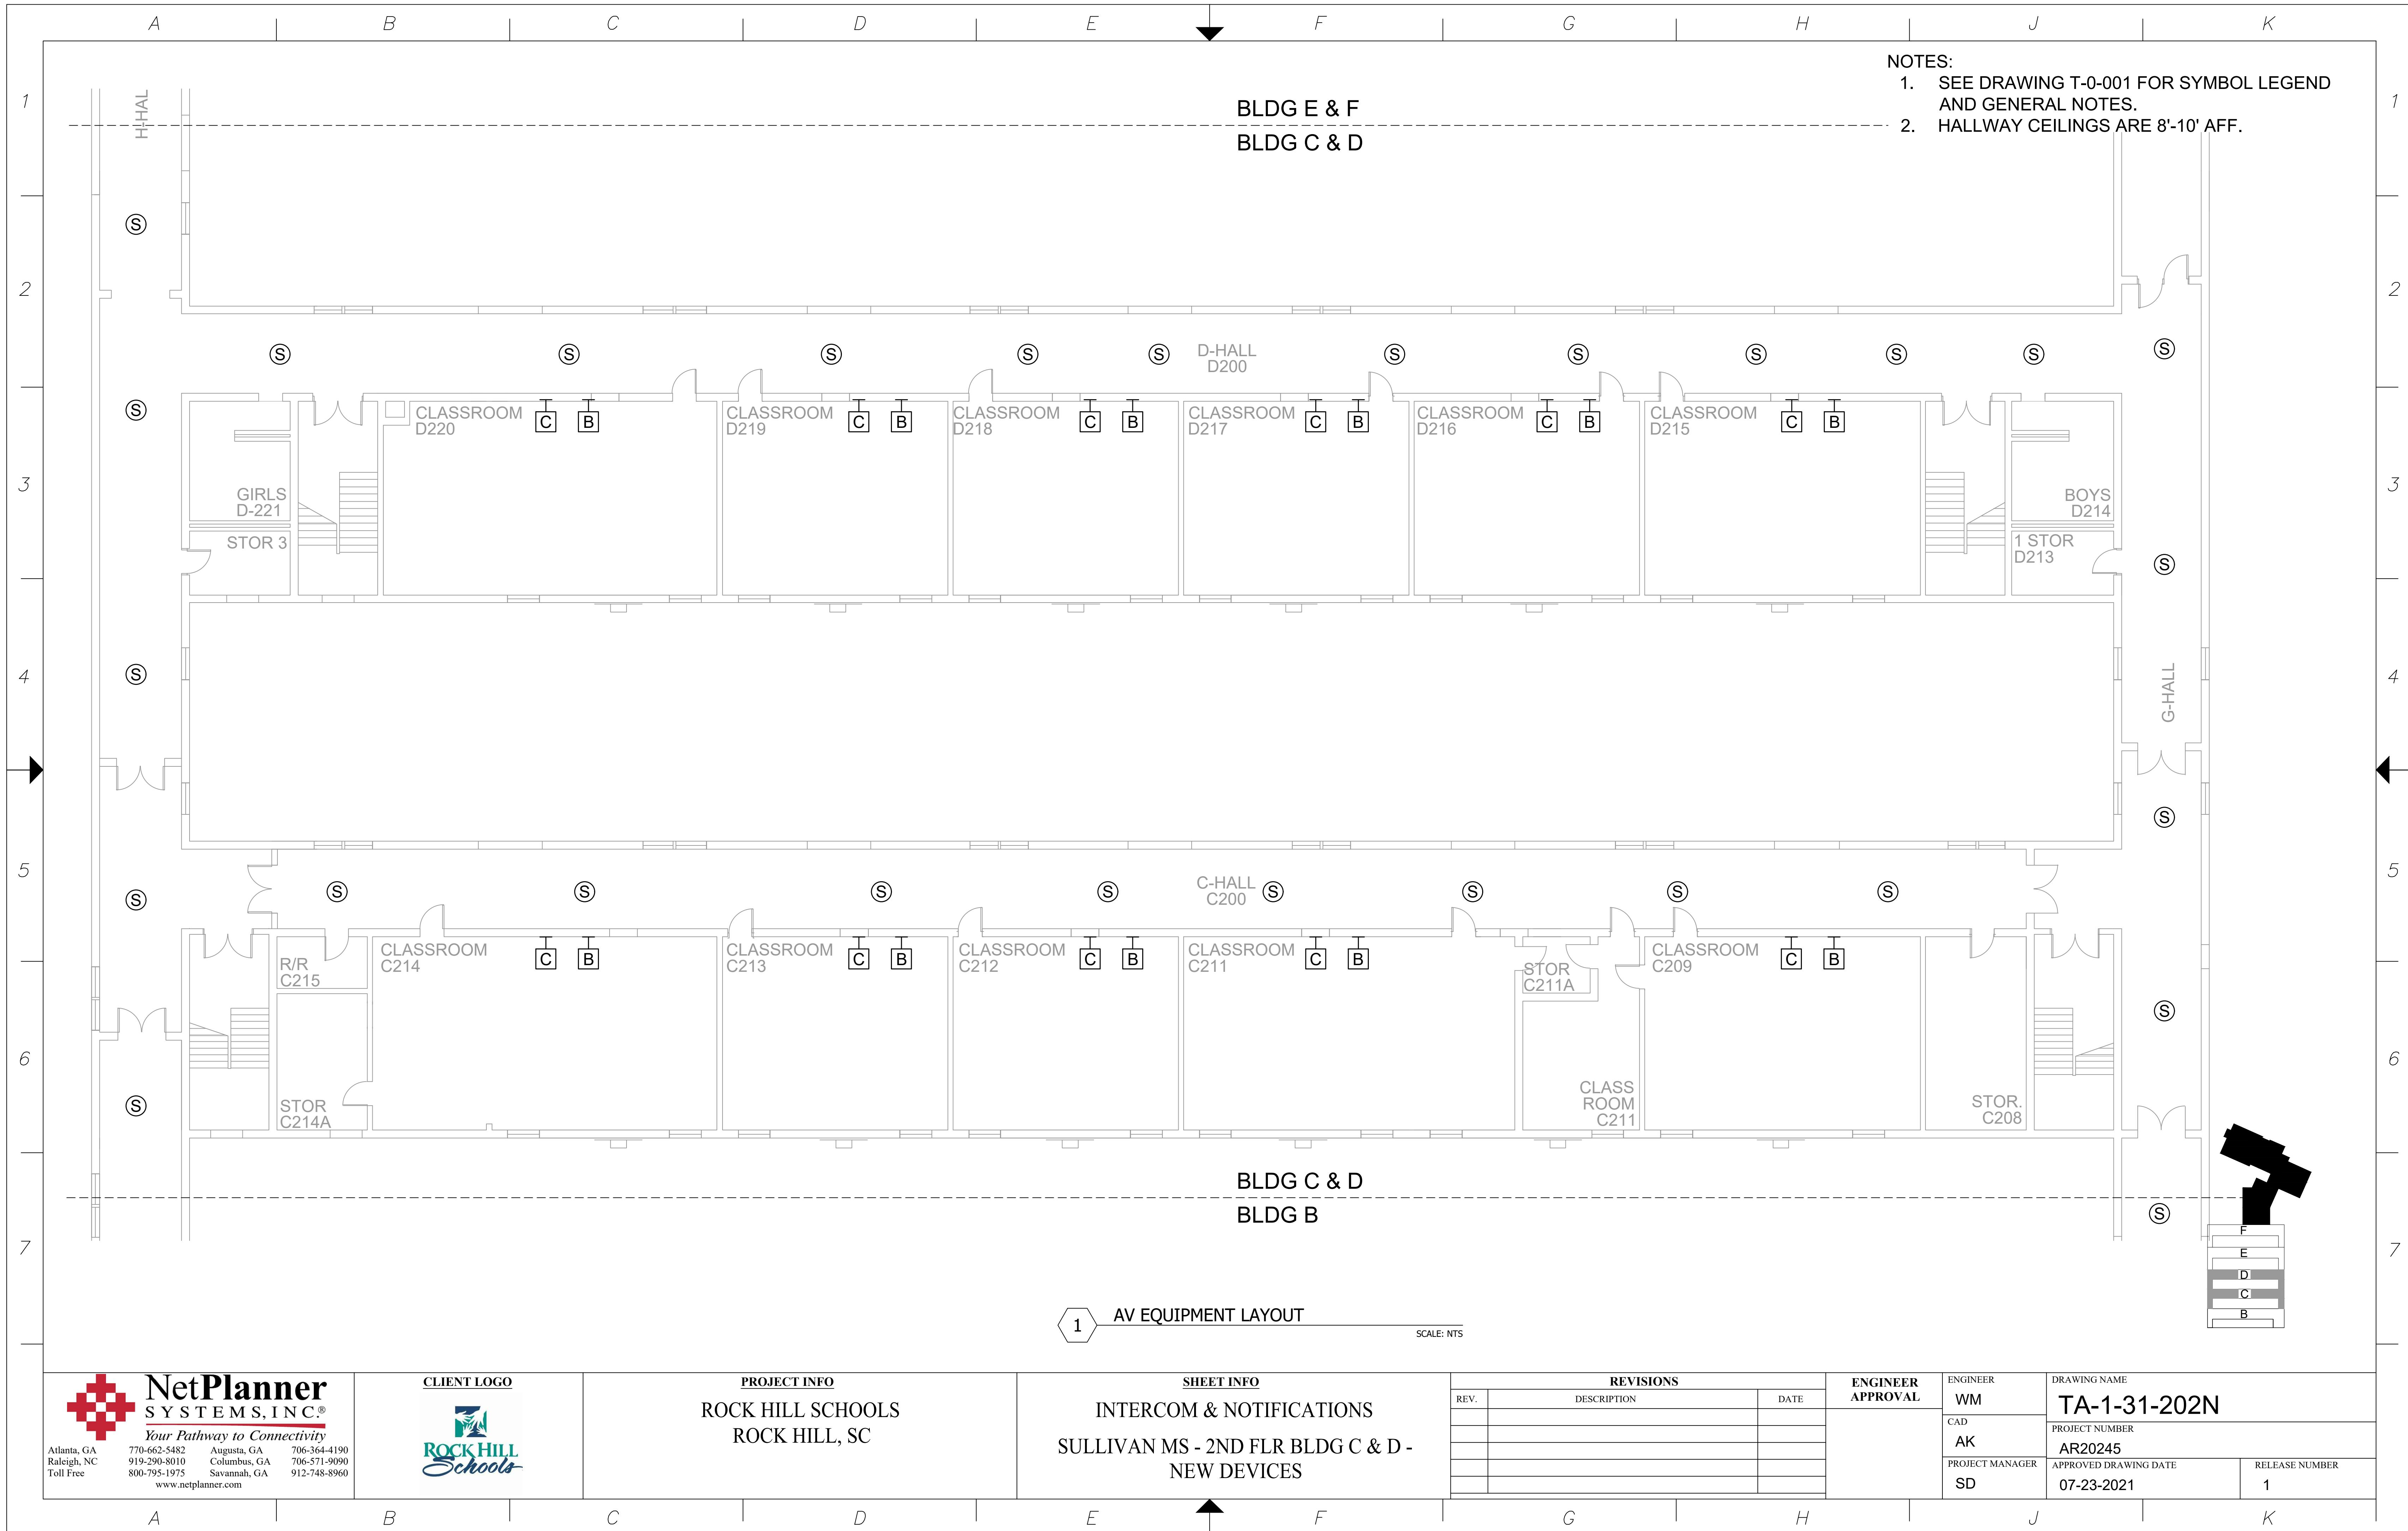

A B C D E F G H J K


REFER TO CHERRY ELEMENTARY - 2ND FLOOR

NOTES:
1. SEE DRAWING T-0-001 FOR SYMBOL LEGEND AND GENERAL NOTES.
2. HALLWAY CEILINGS ARE 8'-10' AFF.

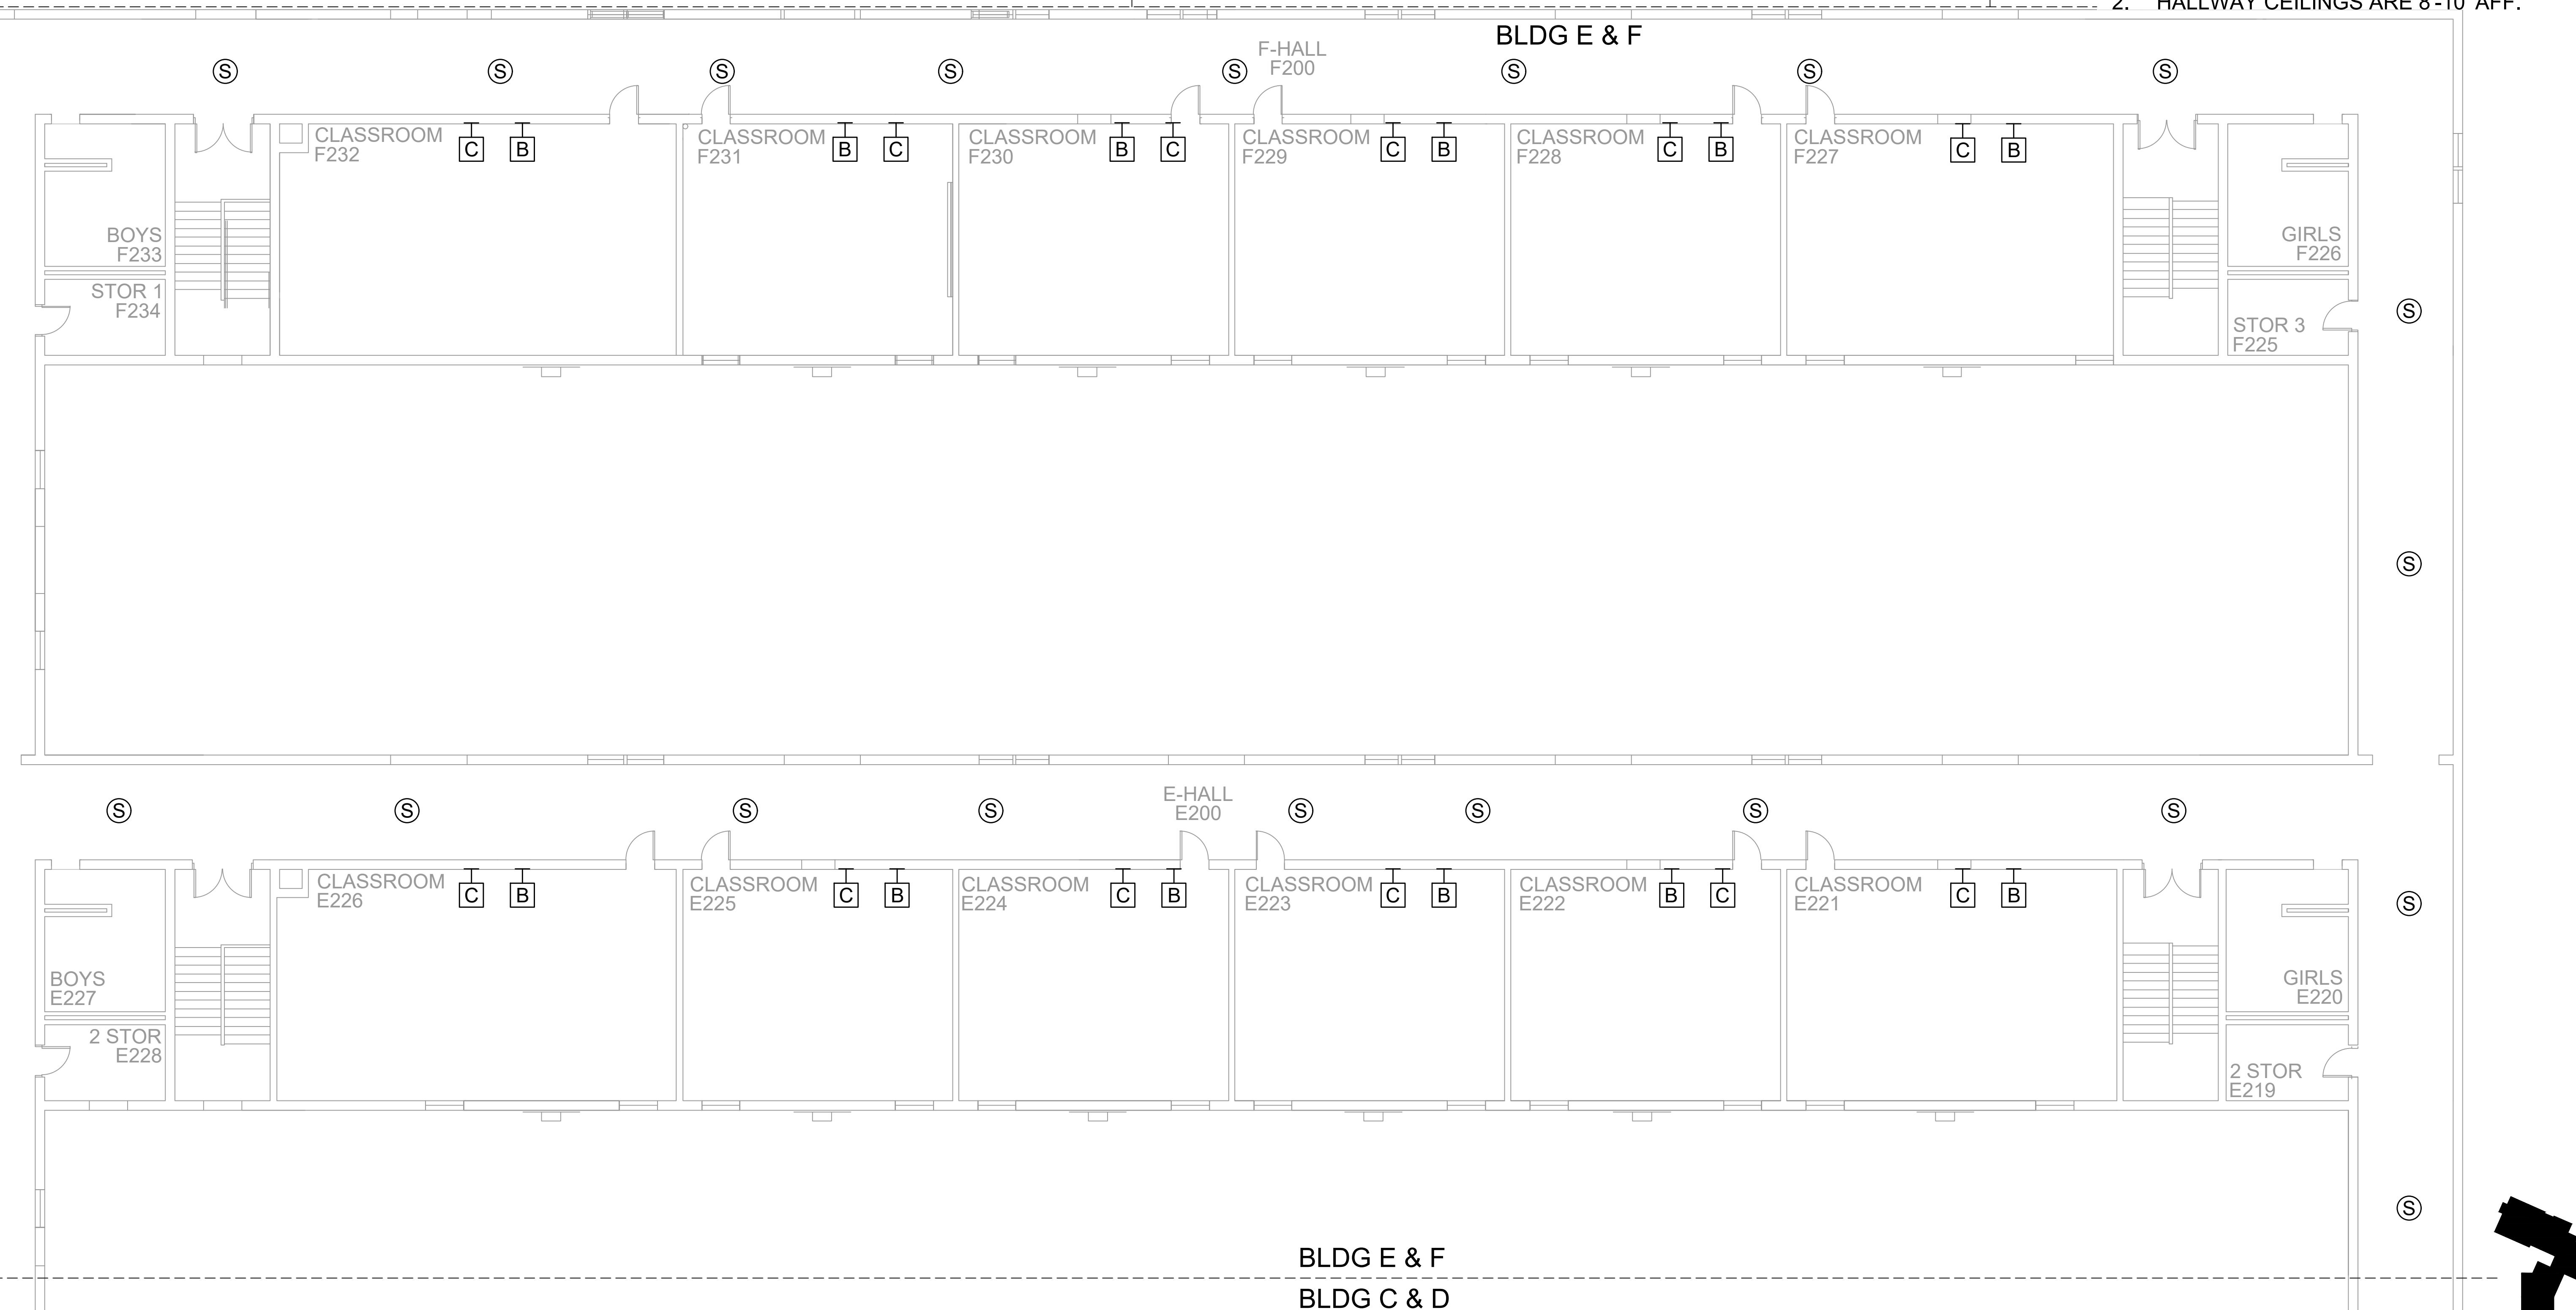

AV EQUIPMENT LAYOUT


SCALE: NTS

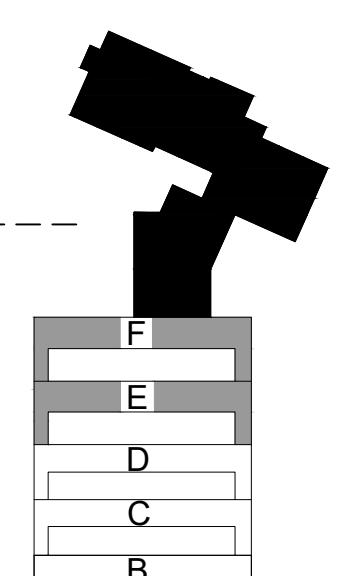

A B C D E F G H J K

A B C D E F G H J K

NOTES:
 1. SEE DRAWING T-0-001 FOR SYMBOL LEGEND AND GENERAL NOTES.
 2. HALLWAY CEILINGS ARE 8' AFF.

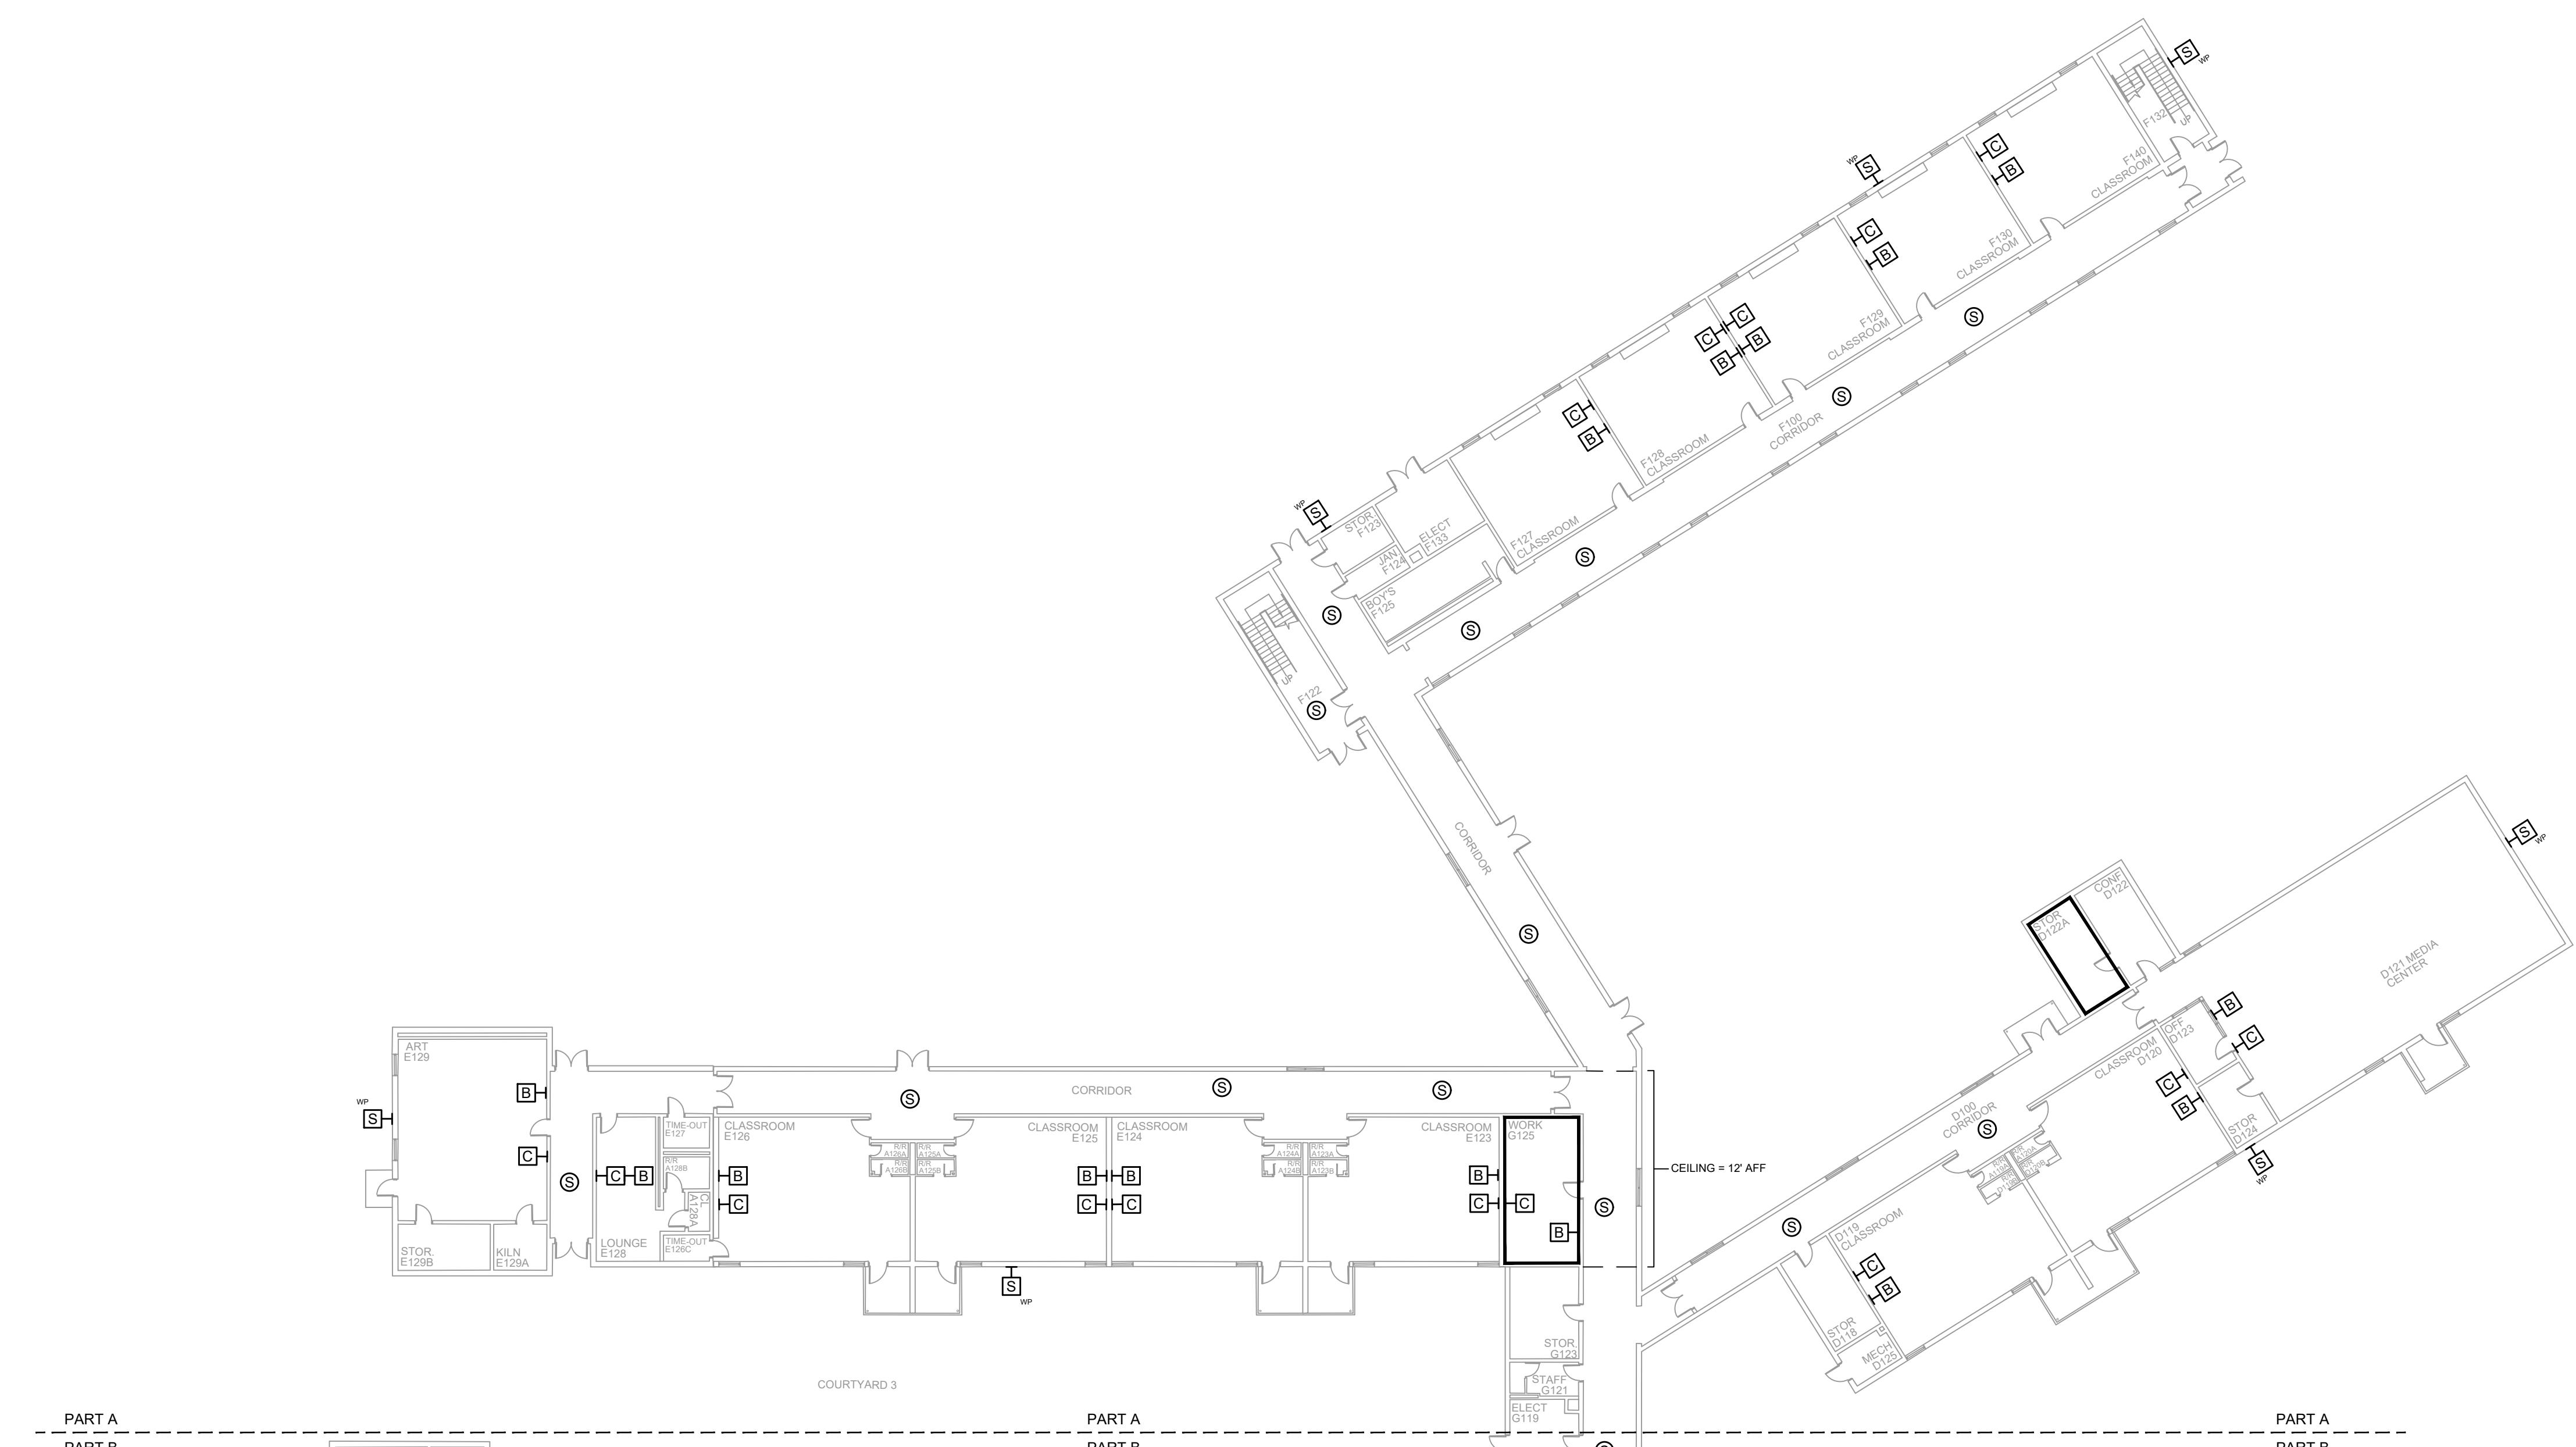

1 AV INFRASTRUCTURE LAYOUT - PART A

SCALE: NTS


REV.	DESCRIPTION	DATE

ENGINEER APPROVAL
WM
CAD
AK
PROJECT MANAGER

ENGINEER	DRAWING NAME
WM	TA-1-32-101N
CAD	PROJECT NUMBER
AK	AR20245
PROJECT MANAGER	APPROVED DRAWING DATE
SD	07-23-2021
	RELEASE NUMBER
	1

A B C D E F G H J K

- NOTES:
- SEE DRAWING T-0-001 FOR SYMBOL LEGEND AND GENERAL NOTES.
 - HALLWAY CEILINGS ARE 8' AFF.

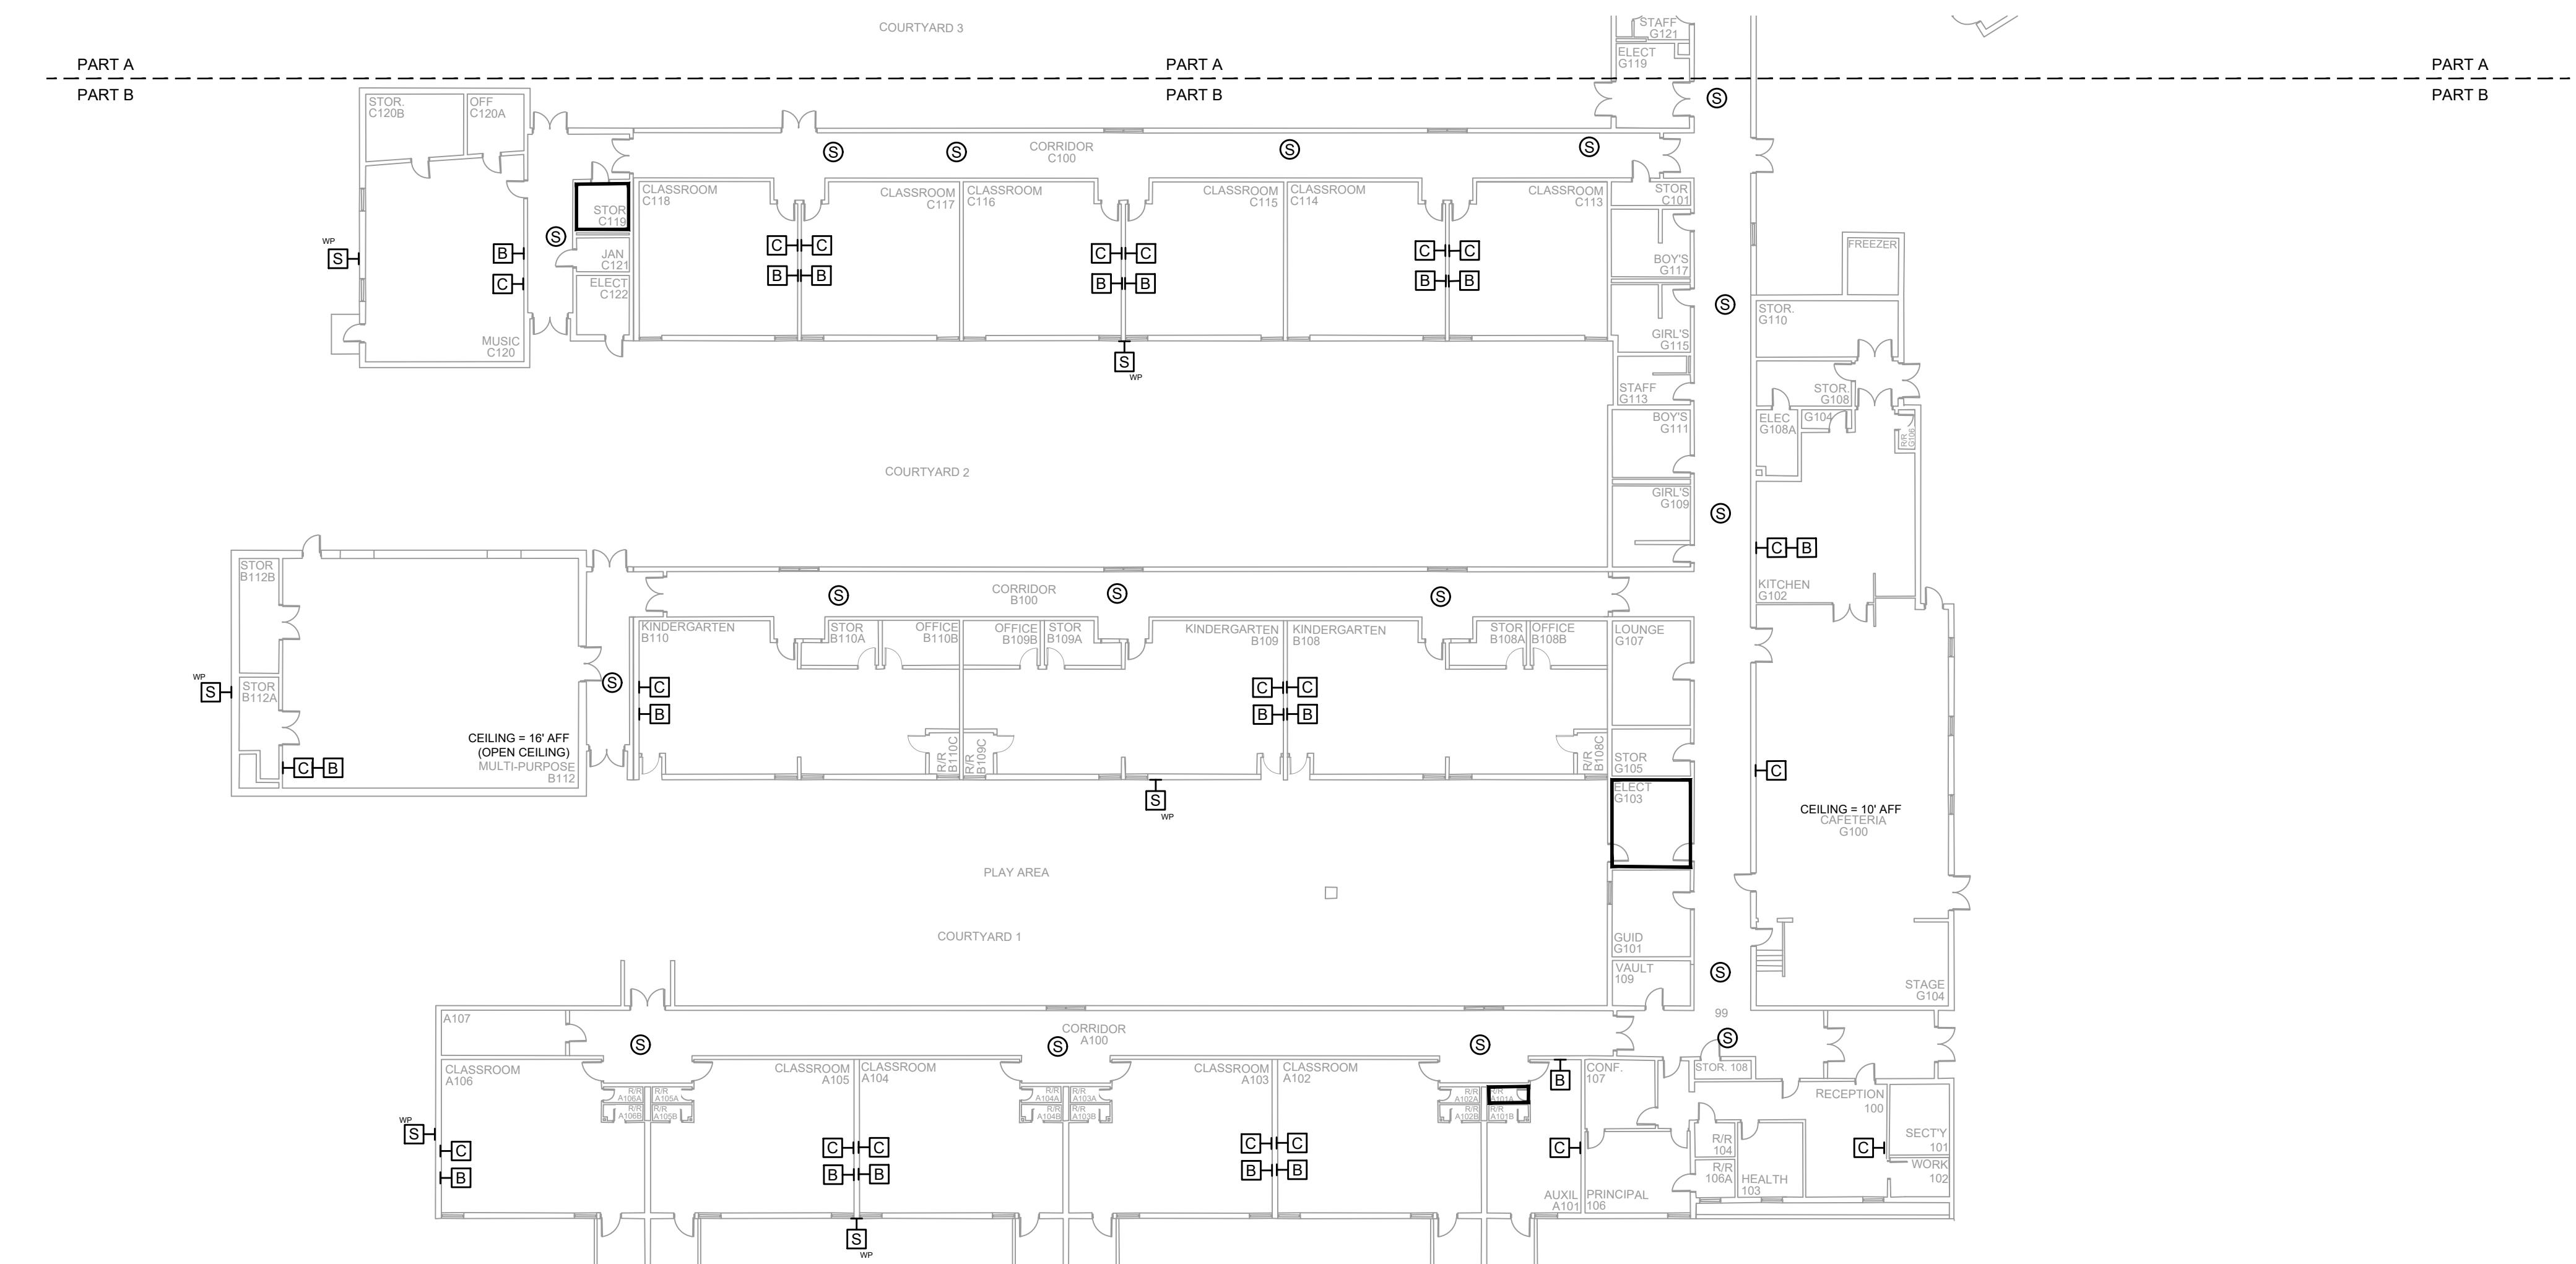


1 AV INFRASTRUCTURE LAYOUT - PART B

SCALE: NTS

REV.	DESCRIPTION	DATE	REVISIONS	
			ENGINEER APPROVAL	ENGINEER DRAWING NAME
			WM	TA-1-32-102N
			CAD	PROJECT NUMBER
			AK	AR20245
			PROJECT MANAGER	APPROVED DRAWING DATE
			SD	07-23-2021
				RELEASE NUMBER
				1


A B C D E F G H J K

 A B C D E F G H J K




A B C D E F G H J K

NOTES:
1. SEE DRAWING T-0-001 FOR SYMBOL LEGEND
AND GENERAL NOTES.

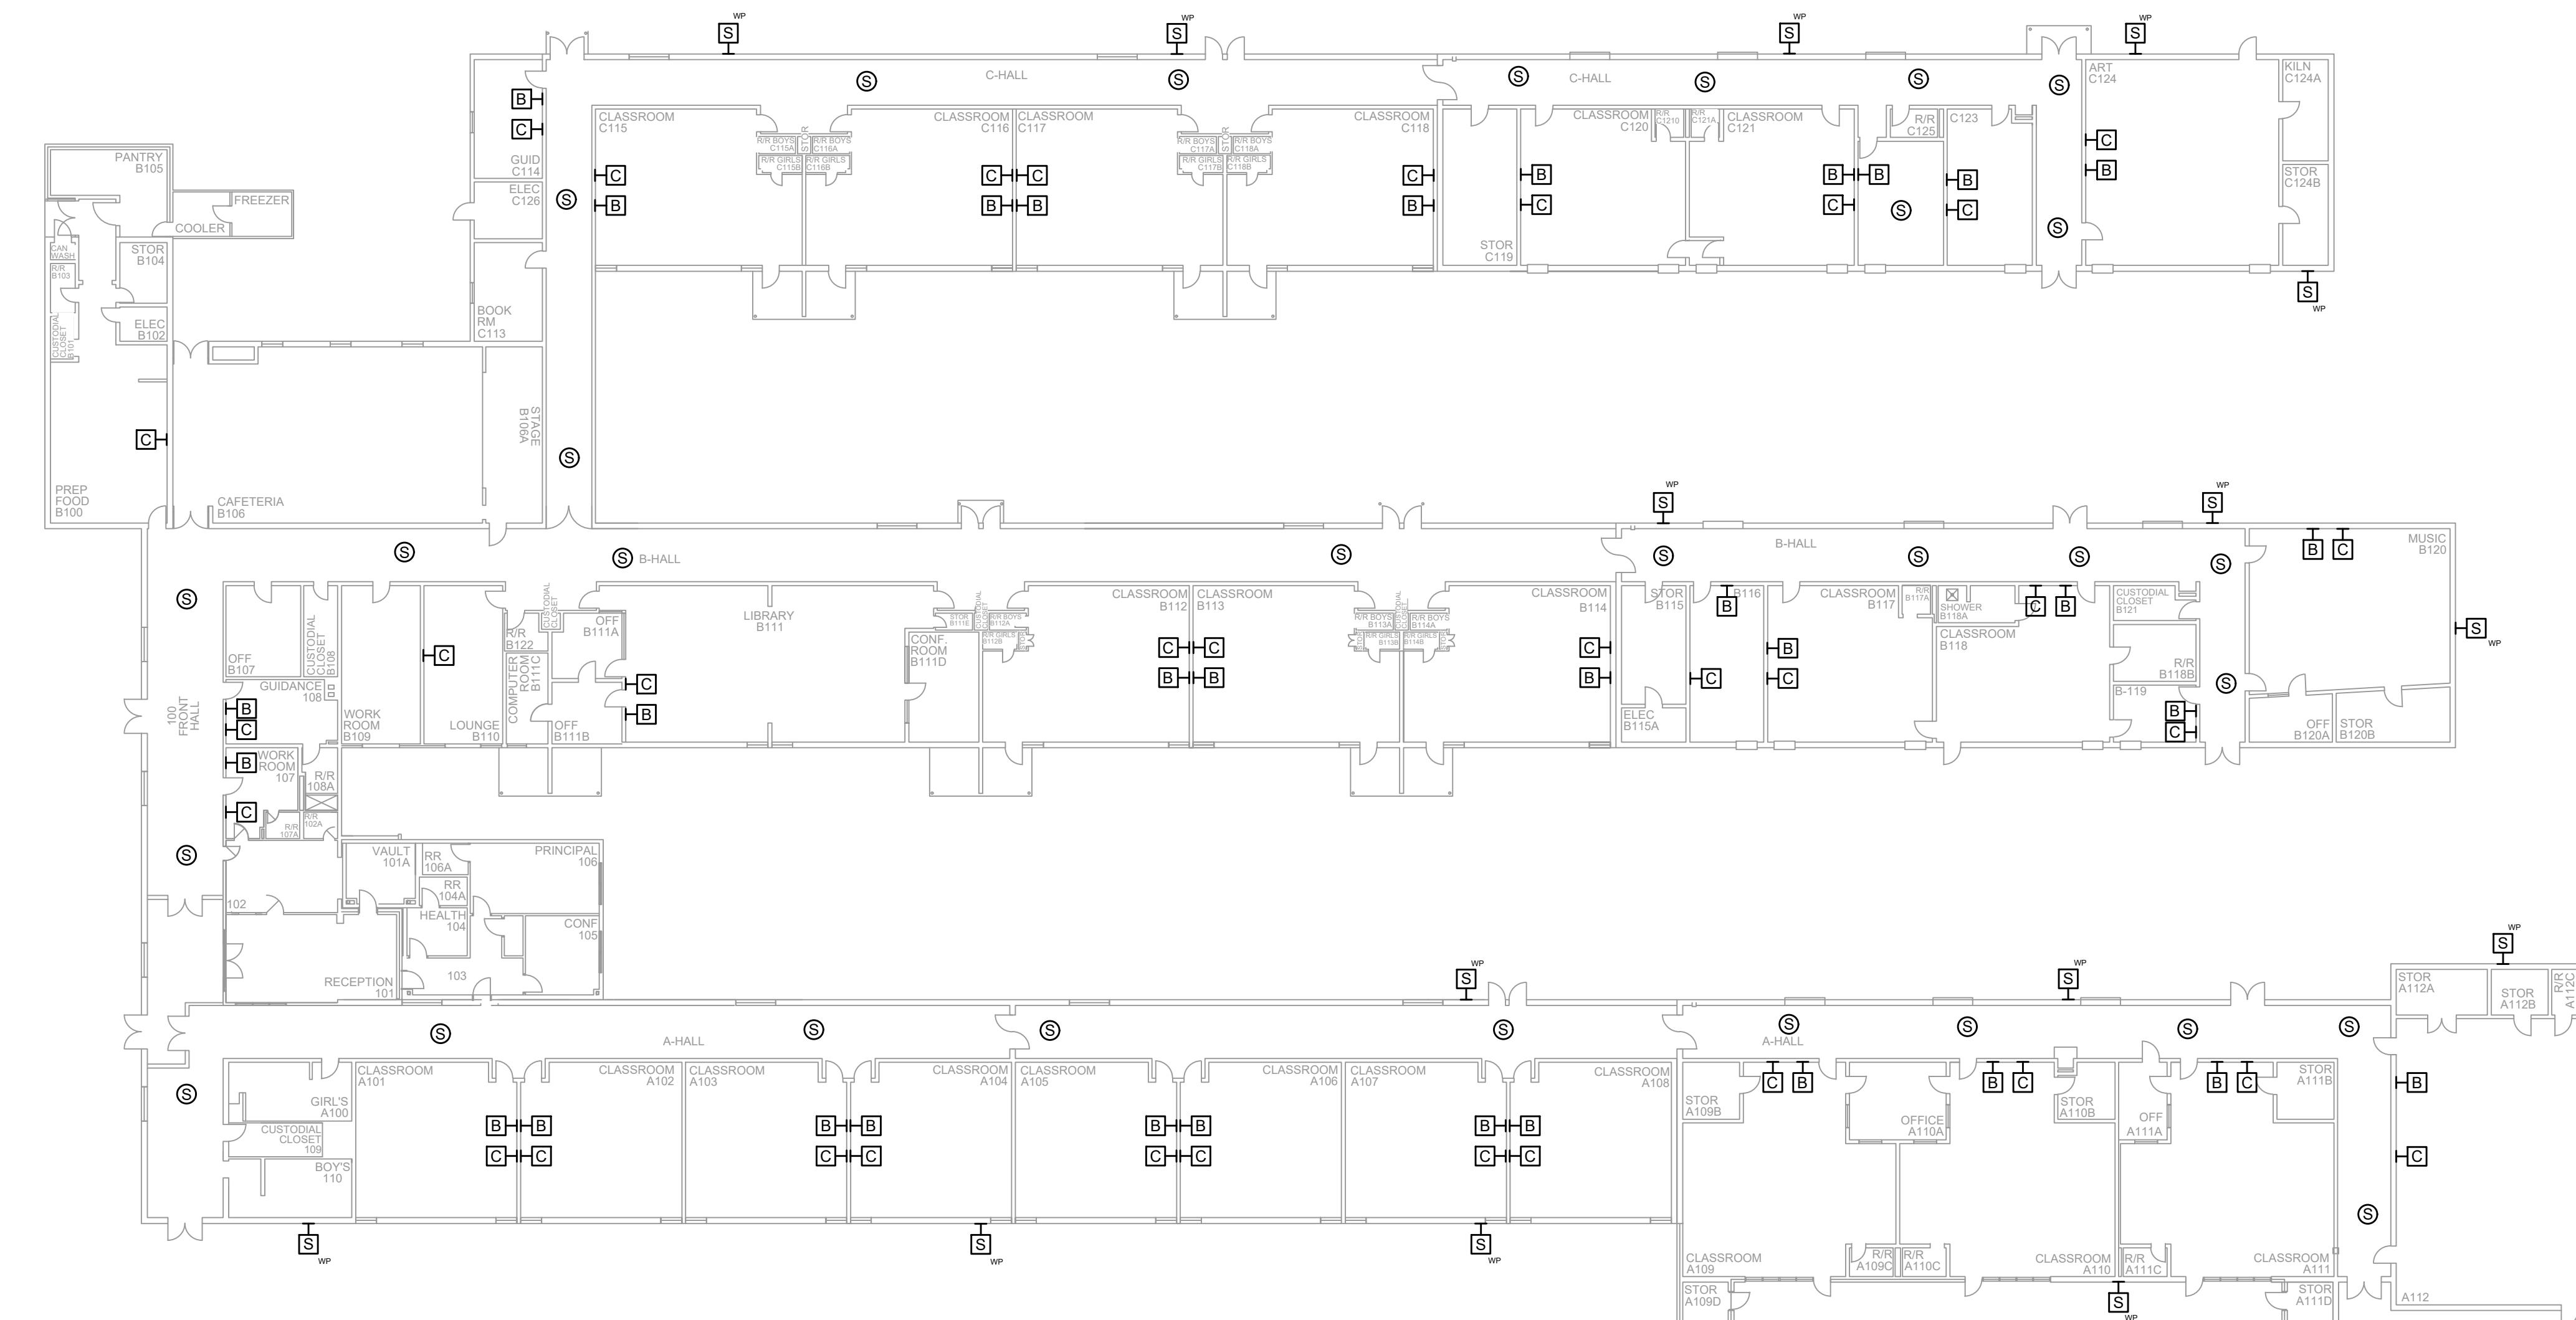

1 AV EQUIPMENT LAYOUT

SCALE: NTS

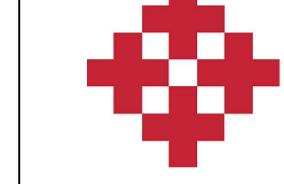

REV.	DESCRIPTION	DATE	REVISIONS	
			ENGINEER APPROVAL	DRAWING NAME
			WM	TA-1-33-101N
			AK	PROJECT NUMBER
				AR20245
			SD	PROJECT MANAGER
				APPROVED DRAWING DATE
				07-23-2021
				RELEASE NUMBER
				1

A

B

C

D

E

F

G

H

J

K

A B C D E F G H J K

NOTES:
1. SEE DRAWING T-0-001 FOR SYMBOL LEGEND
AND GENERAL NOTES.



1 AV EQUIPMENT LAYOUT

SCALE: NTS




PROJECT INFO
ROCK HILL SCHOOLS
ROCK HILL, SC

INTERCOM & NOTIFICATIONS
TRANSPORTATION - NEW
DEVICES

REV.	DESCRIPTION	DATE	REVISIONS	
			ENGINEER APPROVAL	ENGINEER DRAWING NAME
			WM	TA-1-34-101N
			AK	PROJECT NUMBER AR20245
			SD	PROJECT MANAGER APPROVED DRAWING DATE 07-23-2021 RELEASE NUMBER 1

A B C D E F G H J K

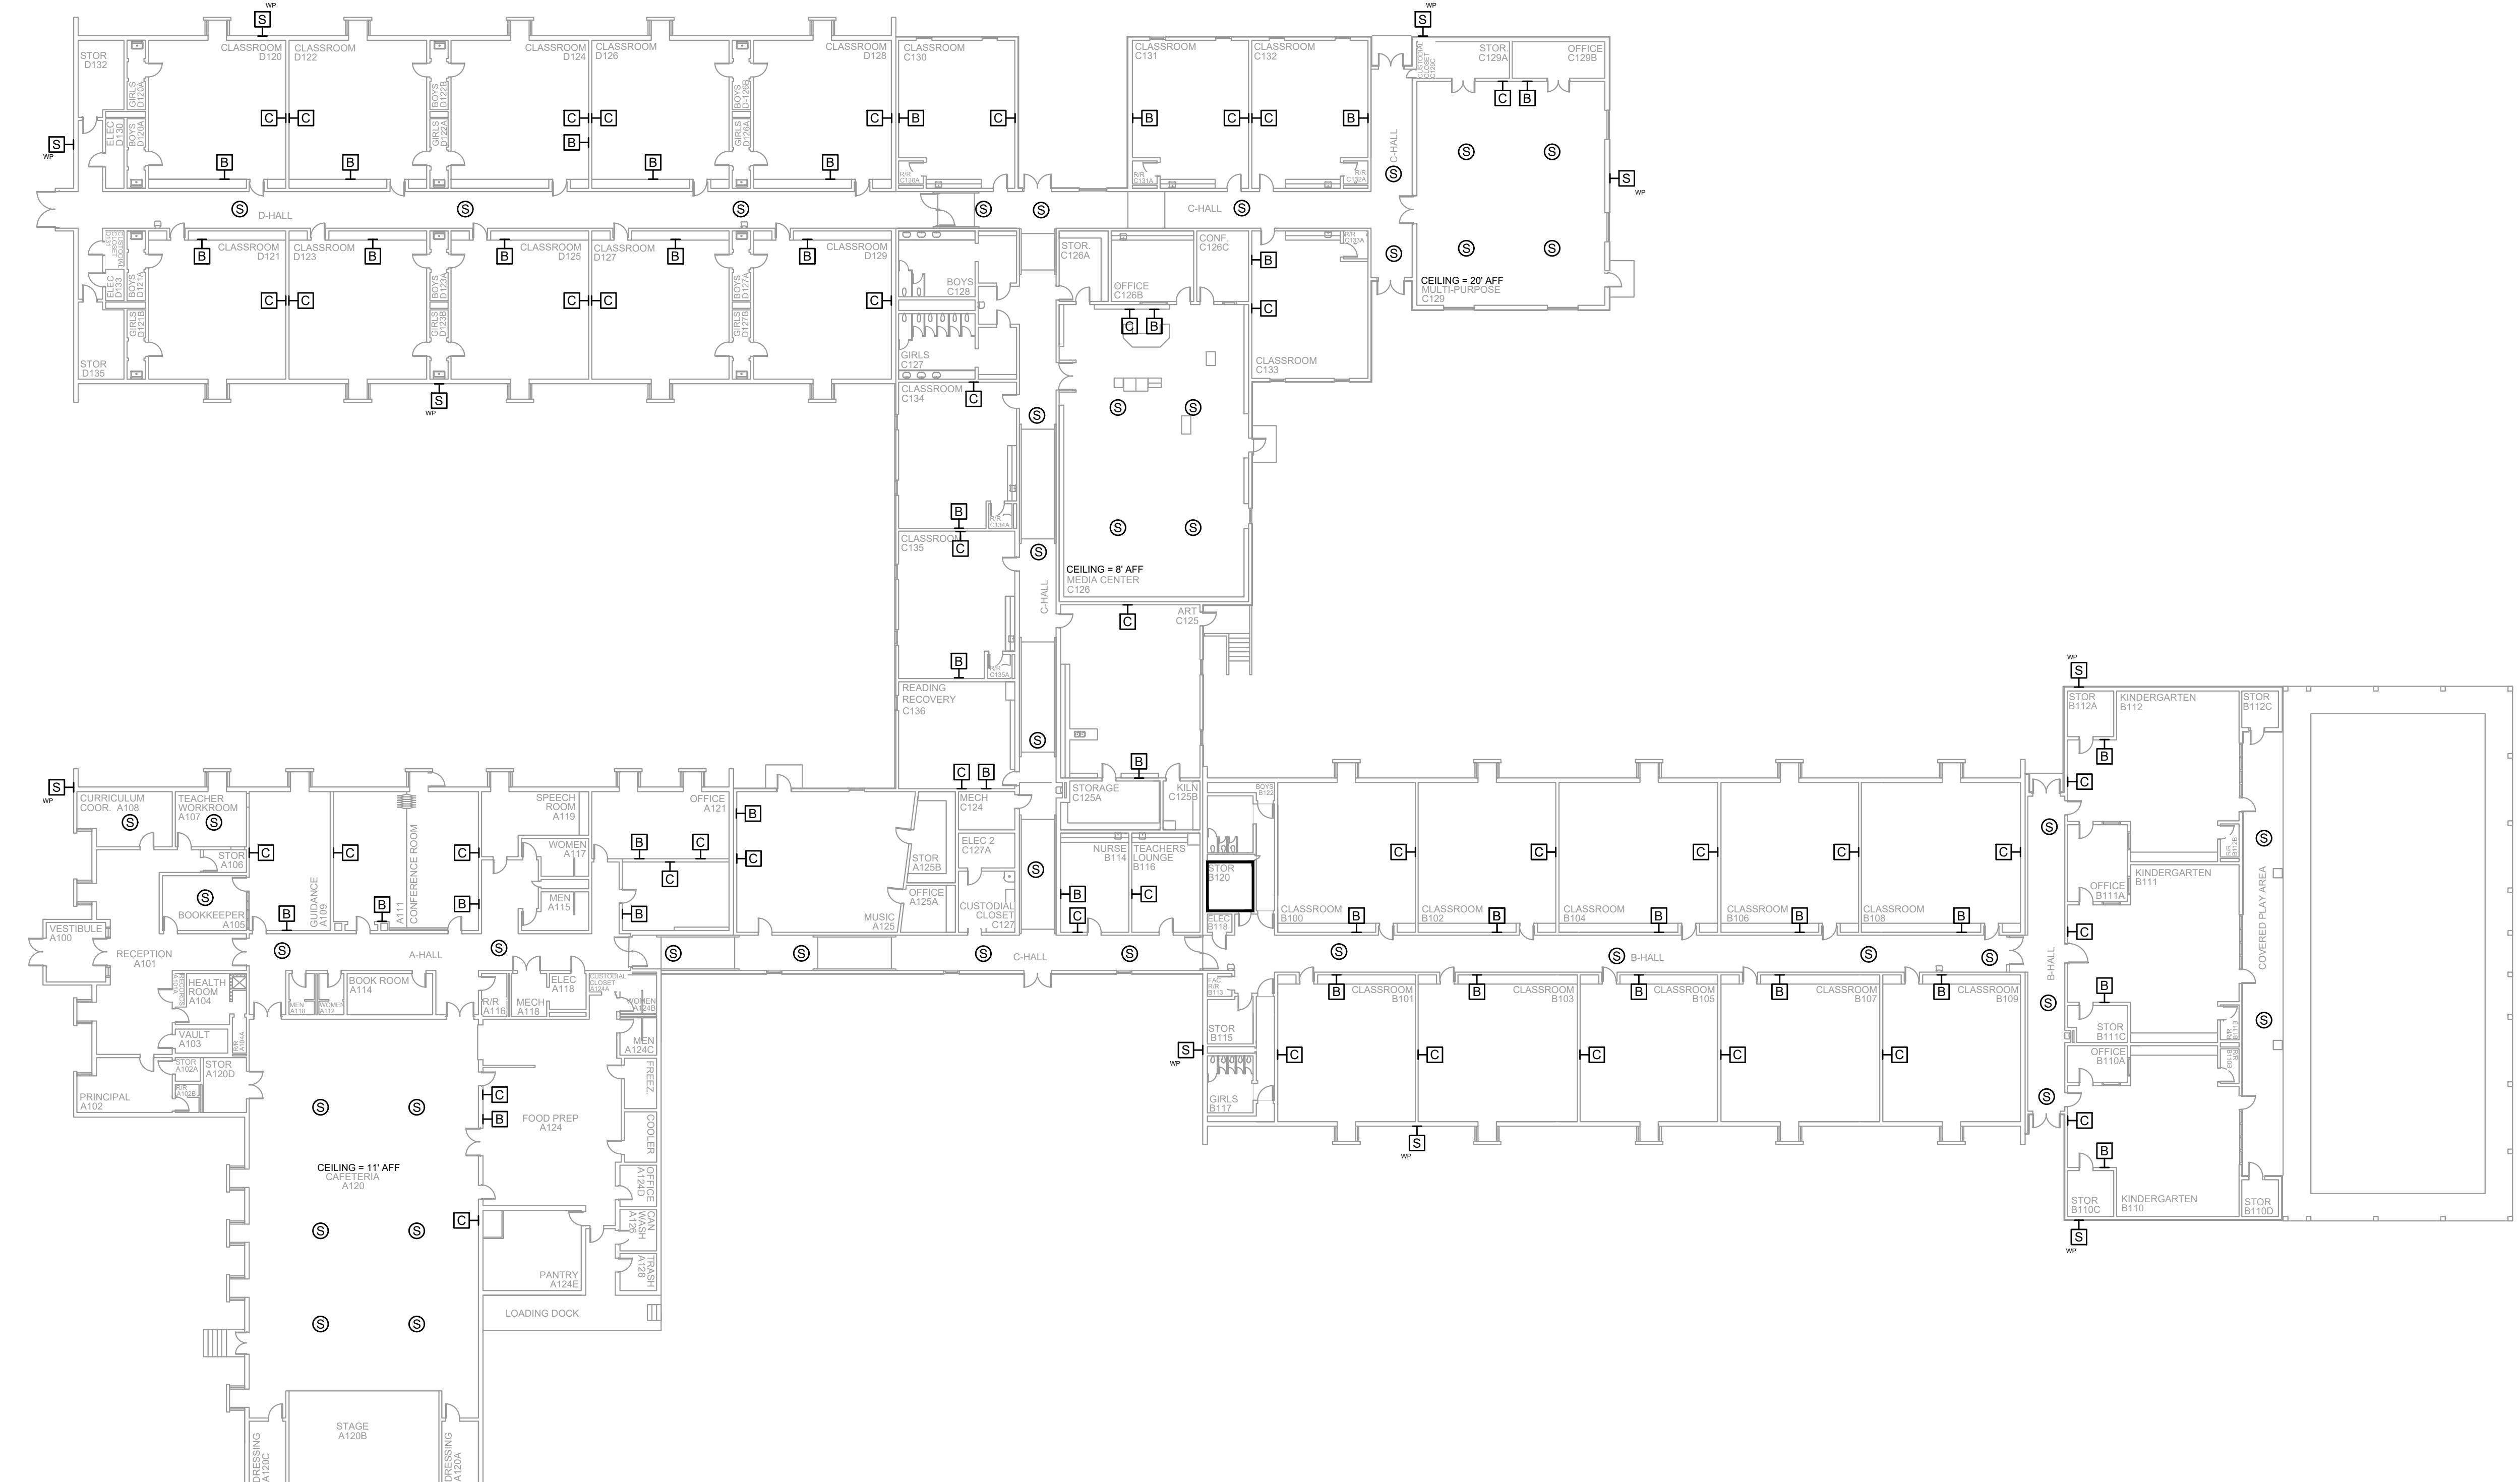


NOTES:

1. SEE DRAWING T-0-001 FOR SYMBOL LEGEND AND GENERAL NOTES.
2. HALLWAY CEILINGS ARE 8' AFF.

AV INFRASTRUCTURE LAYOUT

SCALE: NTS

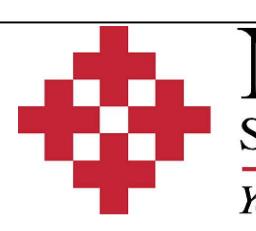

NetPlanner

S Y S T E M S, I N C.®

Your Pathway to Connectivity

662-5482	Augusta, GA	706-364-
90-8010	Columbus, GA	706-571-
95-1975	Savannah, GA	912-748-

CLIENT LOGO

PROJECT INFO

ROCK HILL SCHOOLS ROCK HILL, SC

SHEET INFO

INTERCOM & NOTIFICATIONS

YORK ELEMENTARY - NEW DEVICES

REVISIONS			ENGINEER APPROVAL	ENGINEER WM	DRAWING NAME
REV.	DESCRIPTION	DATE			TA-1-35-101N
				CAD AK	PROJECT NUMBER AR20245
				PROJECT MANAGER SD	APPROVED DRAWING DATE 07-23-2021
					RELEASE NUMBER 1